



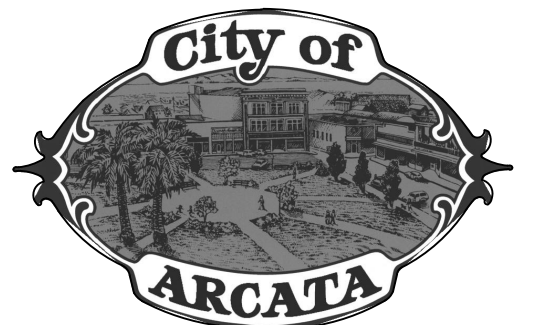

PROJECT NOTES	
OWNER	CITY OF ARCATA
ZONING	INLAND: ARCATA LAND USE CODE (LUC)
GENERAL PLAN DESIGNATION	PUBLIC FACILITY

BASIS OF BEARINGS FOR SURVEY	
HORIZONTAL BASIS	CA STATE PLANE COORDINATE SYSTEM (CCS83),
VERTICAL BASIS	CA STATE PLANE COORDINATE SYSTEM (CCS83),
FOR ADDITIONAL INFORMATION PLEASE CONTACT CITY PERSONNEL.	

SHEET INDEX	
G-001	COVER SHEET
G-002-G-004	SHEET LAYOUT(S)
G-005	NOTES
C-101 - C-120	IMPROVEMENT PLANS
C-501 - C-505	DETAILS

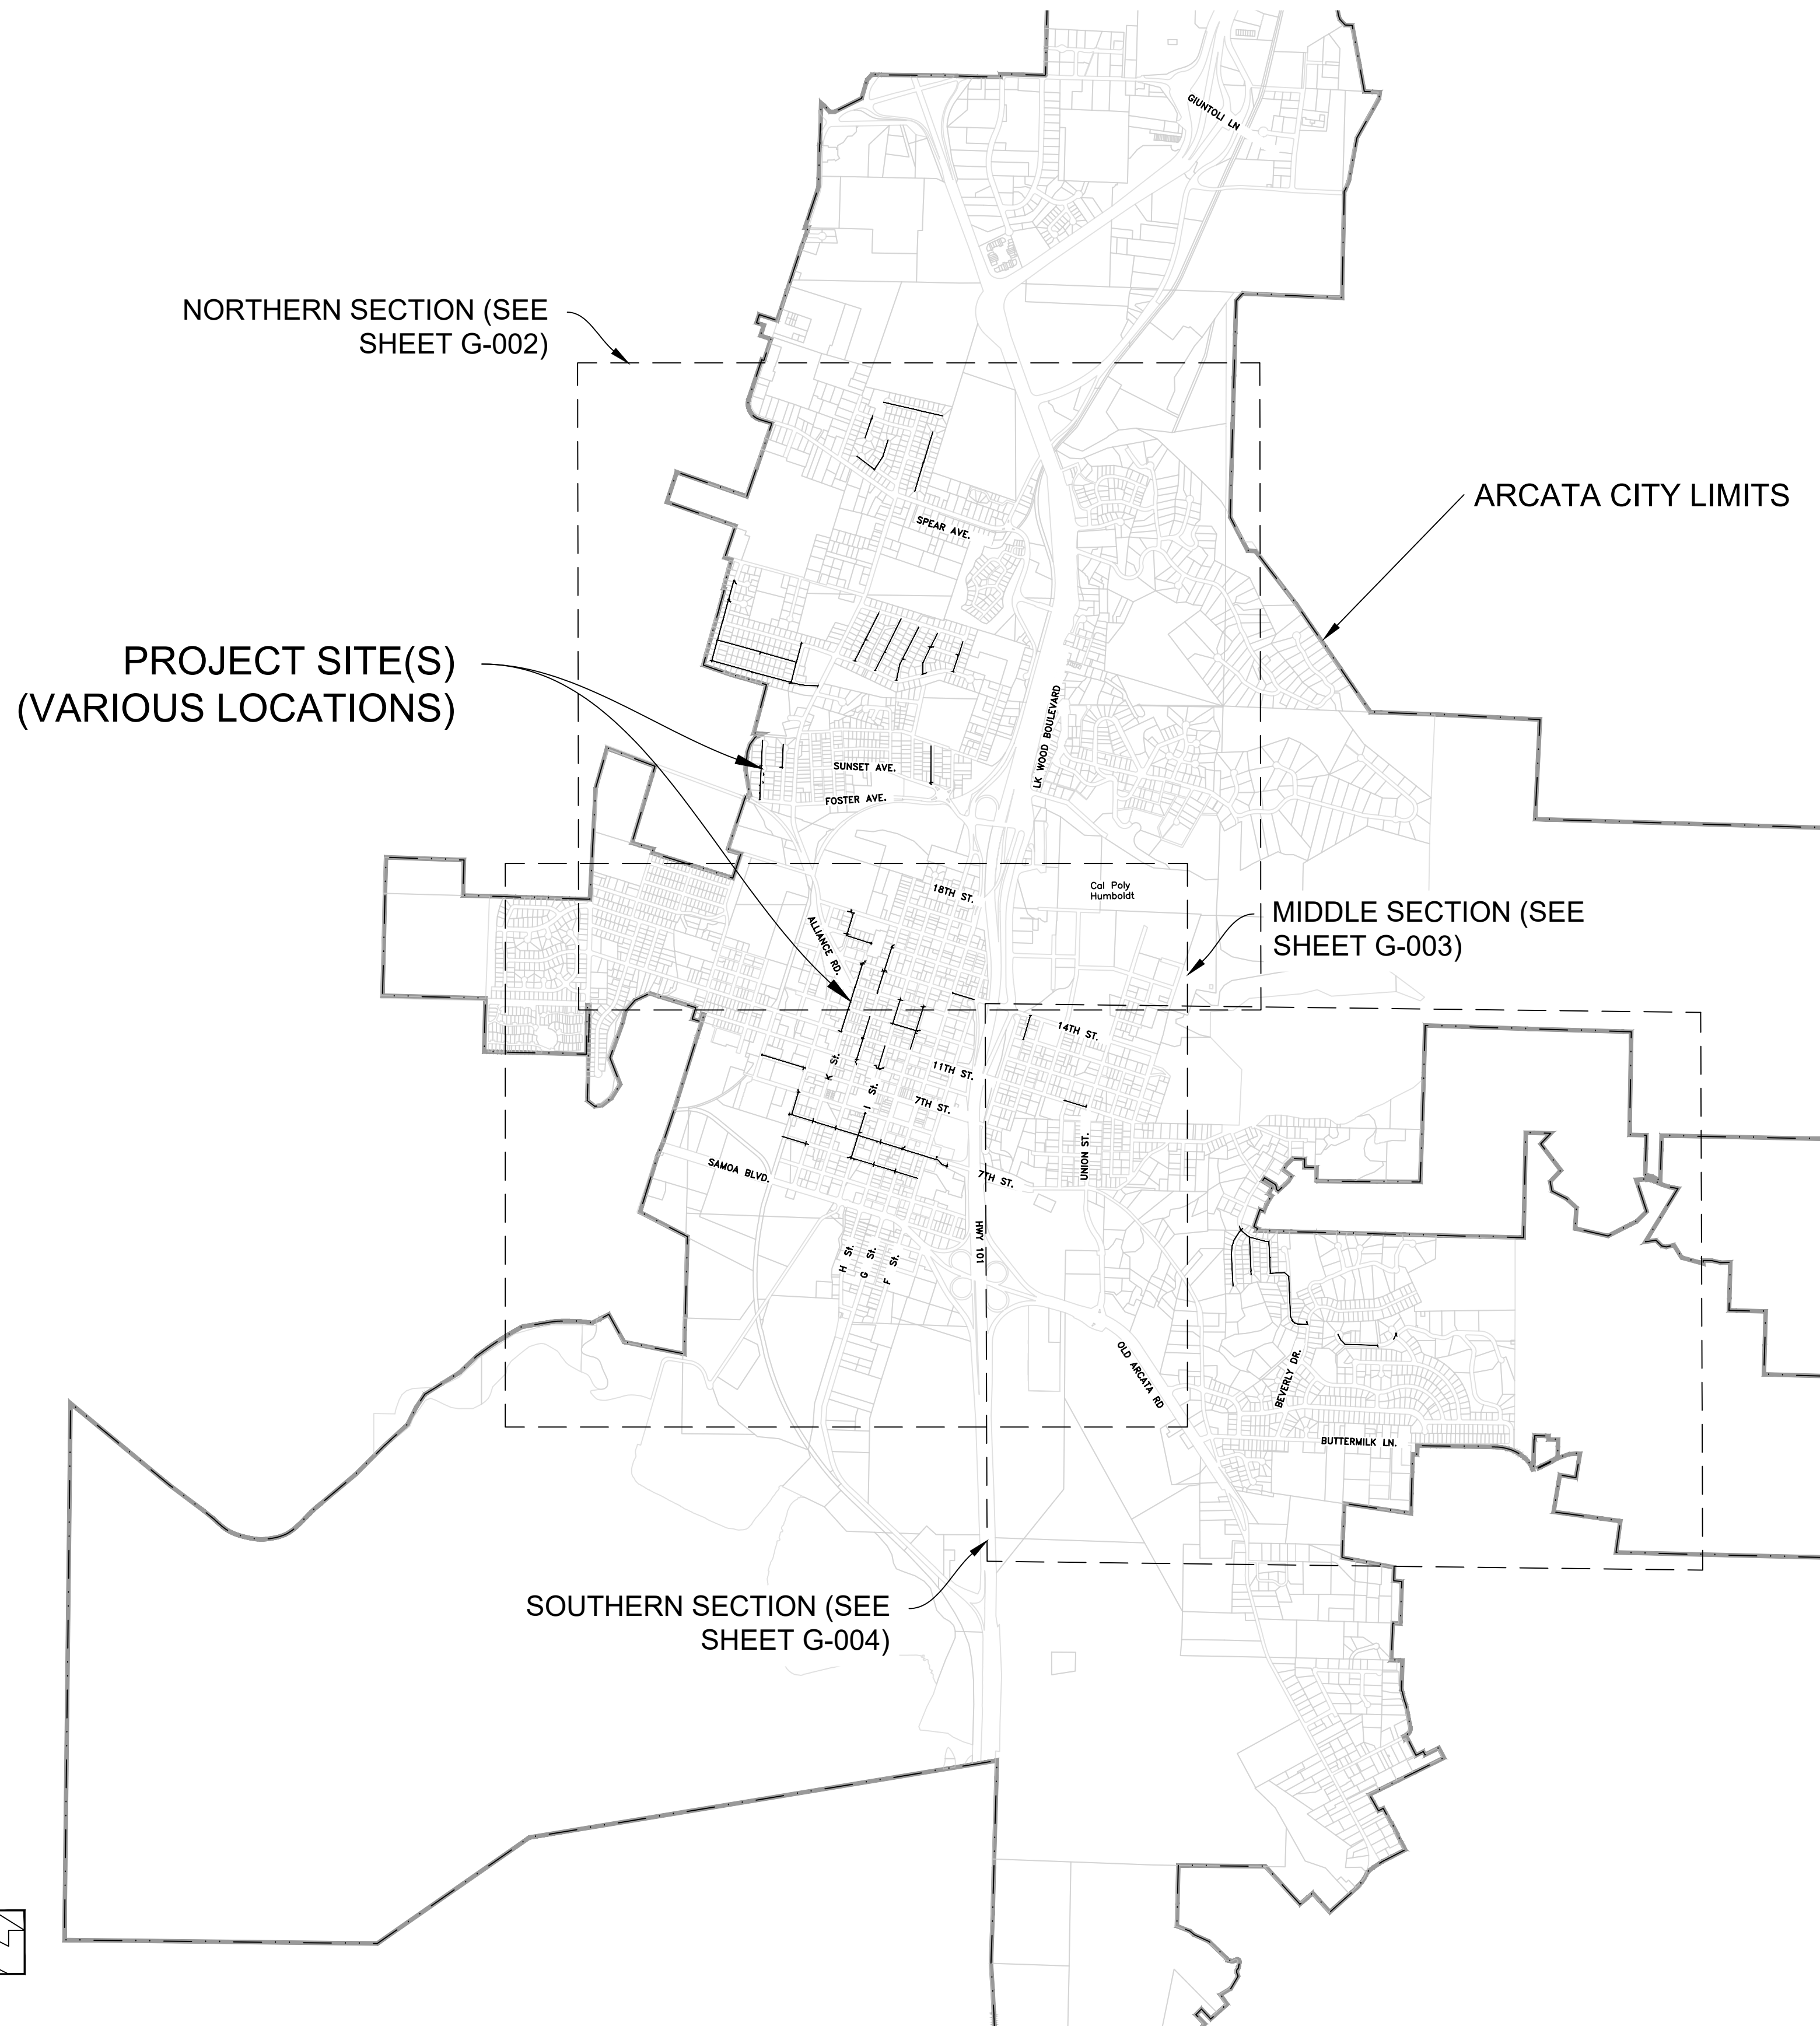

COVER SHEET

STEEL WATERLINE REPLACEMENT PROJECT

Project Address

VARIOUS LOCATIONS

Designed By

Designed By
JONATHAN A. KIRCHUBEL

Drawn By _____

By
JONATHAN A. KIRCHUBEL

Checked By

DAVID CAISSE

Approved By

NETRA B. KHATRI

Date _____

JANUARY 2025

Sheet


G-001

Scale

$$1'' = 750'$$

Page

1

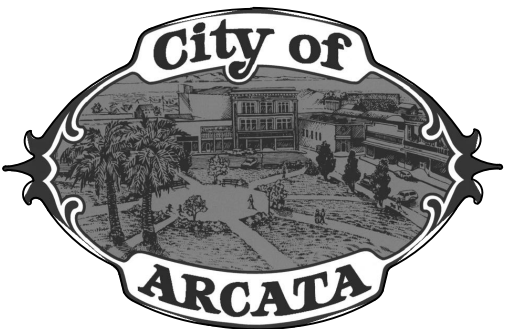

SHEET LAYOUT – NORTHERN SECTION

STEEL WATERLINE REPLACEMENT PROJECT

Project Address
VARIOUS LOCATIONS

Designed By
JONATHAN A. KIRCHUBEL

Drawn By
JONATHAN A. KIRCHUBEL

Checked By
DAVID CAISSE

Approved By
NETRA B. KHATRI

Date
JANUARY 2025

Sheet
G-002

Scale
1"=500'

Page
2





SHEET LAYOUT – MIDDLE SECTION	STEEL WATERLINE REPLACEMENT PROJECT
Sheet Title	Project Name

Project Address
VARIOUS LOCATIONS

Designed By JONATHAN A. KIRCHUBEL
Drawn By JONATHAN A. KIRCHUBEL
Checked By DAVID CAISSE
Approved By NETRA B. KHATRI

Date JANUARY 2025	Sheet G-003
Scale 1"=300'	Page 3

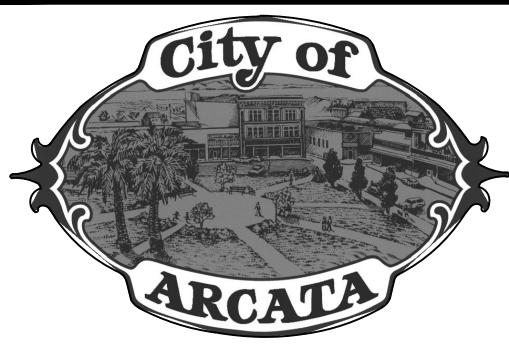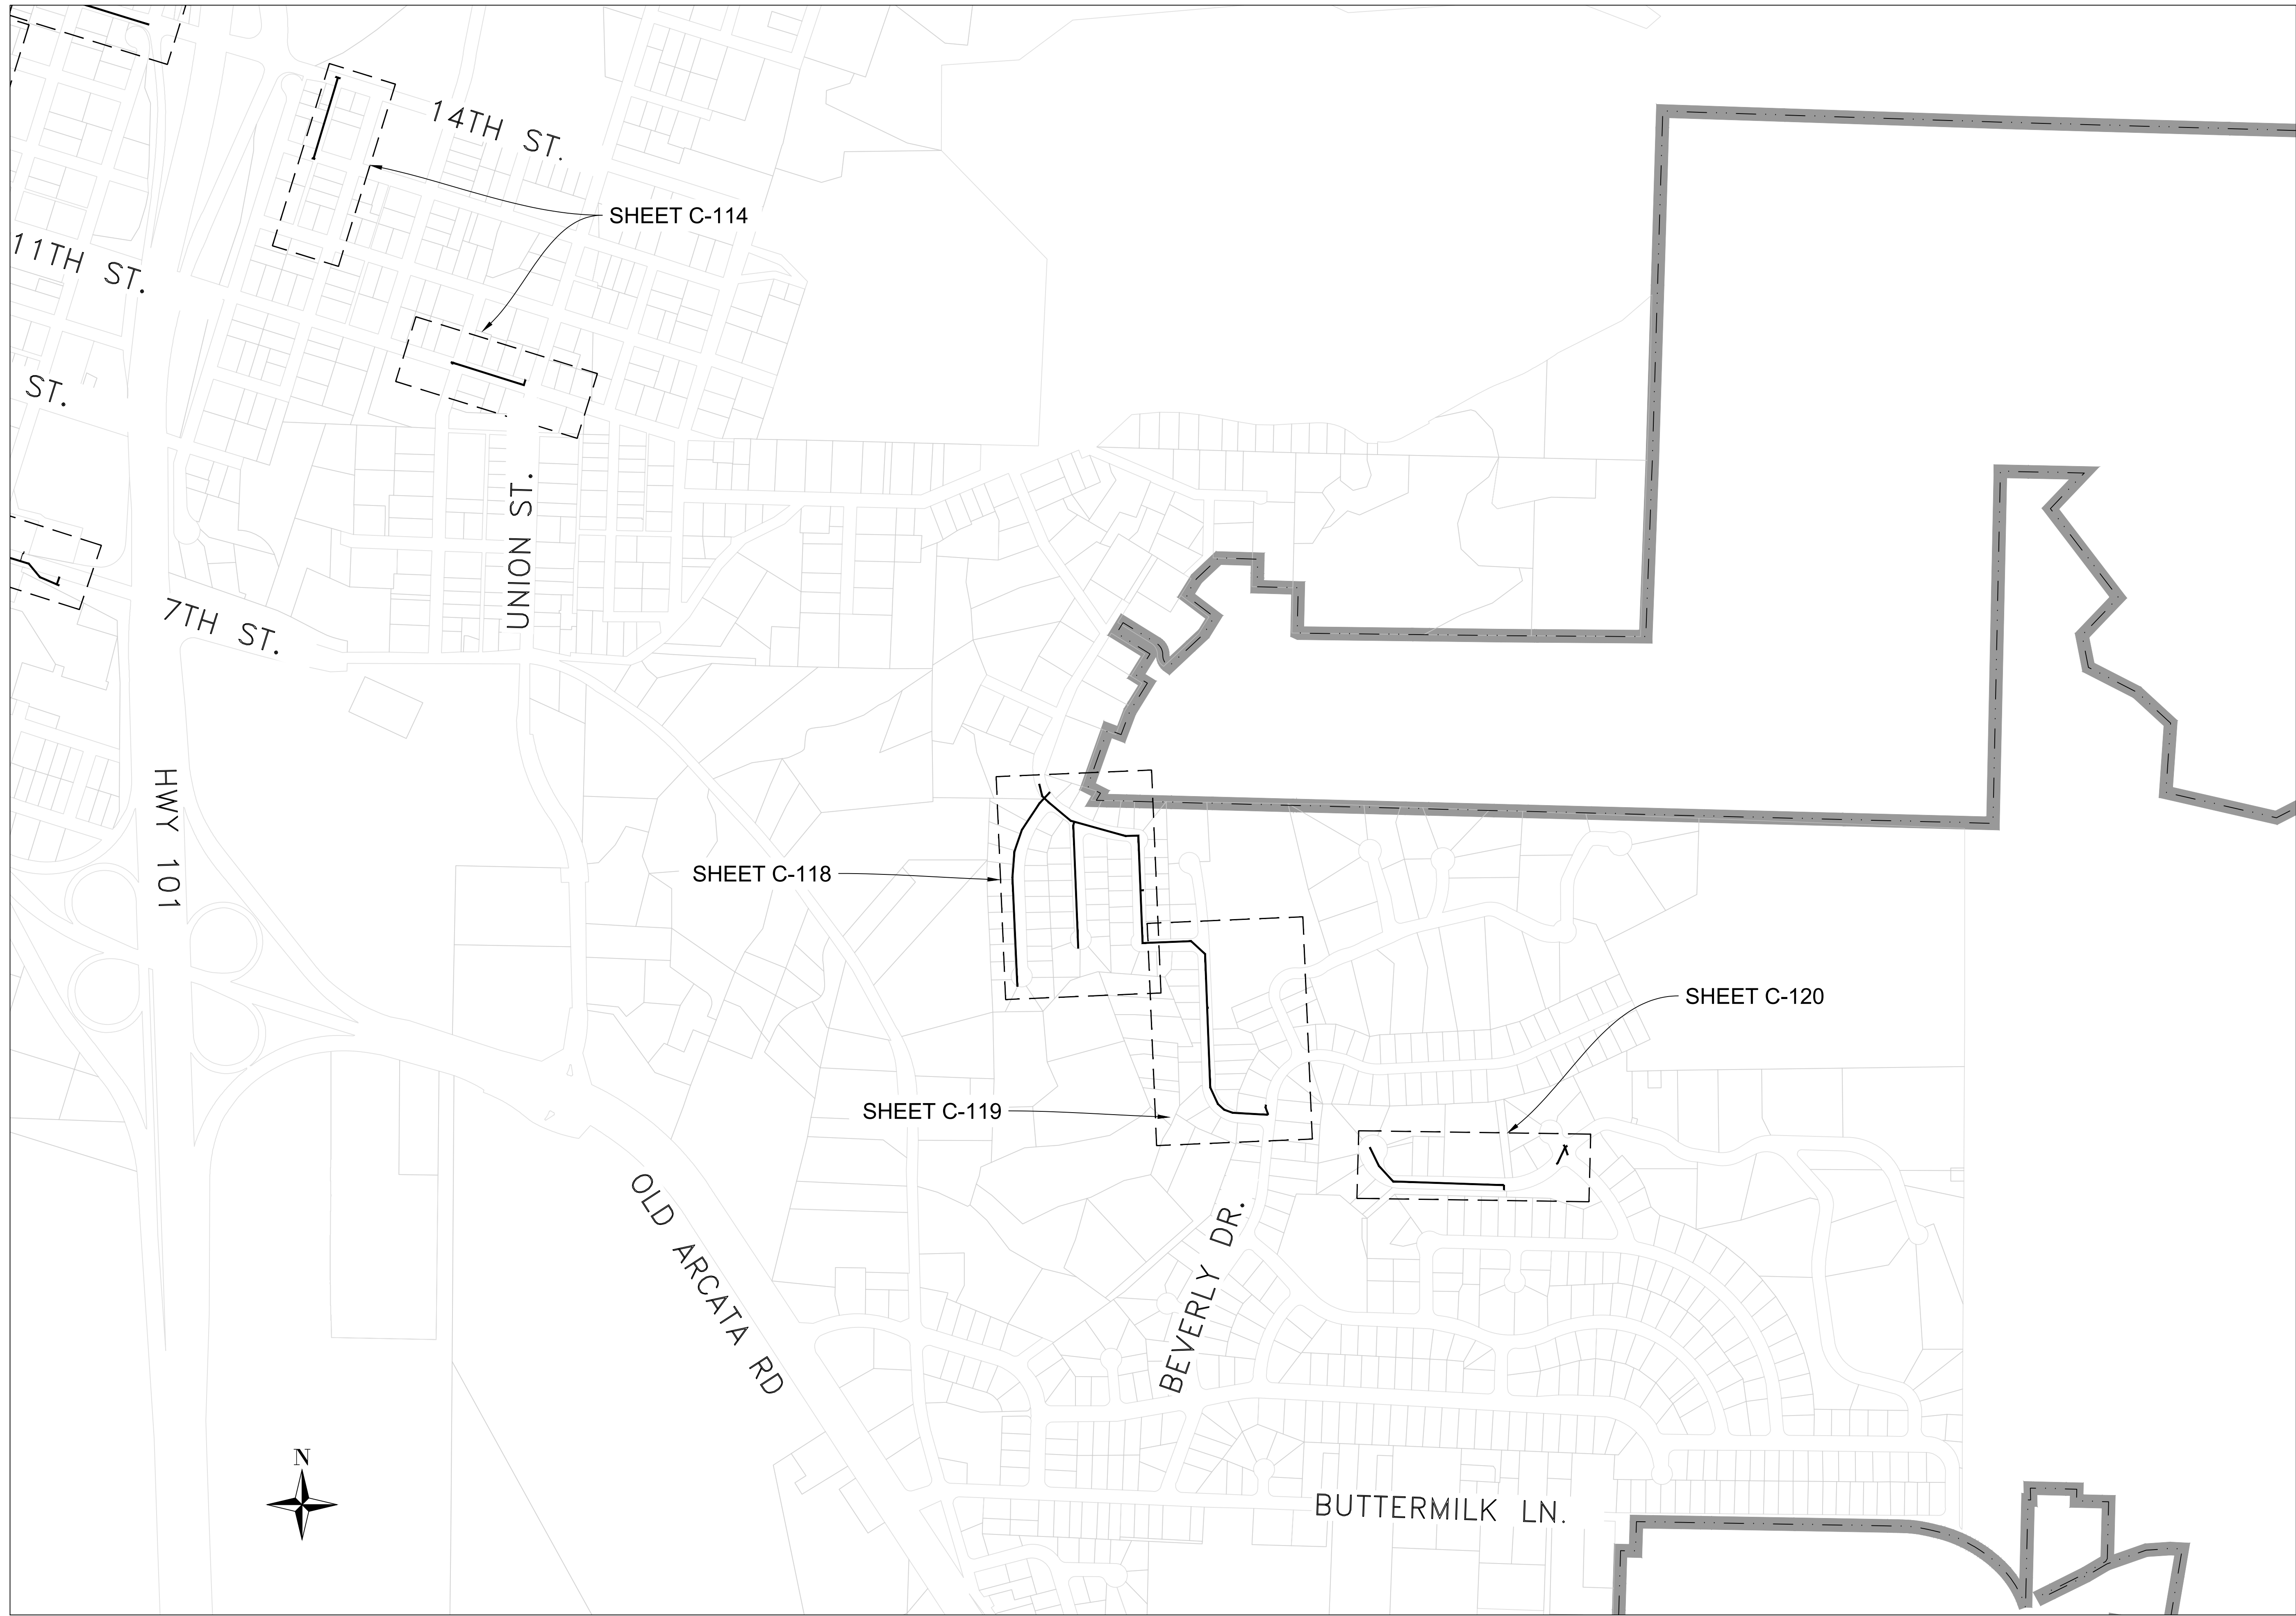

Sheet Title	SHEET LAYOUT – SOUTHERN SECTION
	STEEL WATERLINE REPLACEMENT PROJECT
Project Name	

Project Address	
VARIOUS LOCATIONS	

Designed By	JONATHAN A. KIRCHUBEL
Drawn By	JONATHAN A. KIRCHUBEL
Checked By	DAVID CAISSE
Approved By	NETRA B. KHATRI

Date	JANUARY 2025	Sheet	G-004
Scale	1"=300'	Page	4

PROJECT INFORMATION:

THIS PROJECT CONSISTS OF REMOVAL AND REPLACEMENT OF WATER MAINLINES AND SERVICES AS SHOWN ON THESE PLANS AND CALLED:

STEEL WATERLINE REPLACEMENT PROJECT

THE CONTRACTOR IS HEREBY NOTIFIED THAT HISTORICAL INFORMATION REGARDING THE PROJECT SITE EXISTS AND IS AVAILABLE FOR PUBLIC INSPECTION IN THE CITY OF ARCATA'S ENGINEERING DEPARTMENT OFFICES. THIS HISTORICAL INFORMATION MAY INCLUDE THE FOLLOWING:

- MISCELLANEOUS UTILITY MAPS AND PLANS
- CITY OF ARCATA BLOCK MAPS
- CITY OF ARCATA WATER MAPS
- CITY OF ARCATA DRAINAGE MAPS

THE ANTICIPATED ORDER OF CONSTRUCTION FOR THIS PROJECT IS AS FOLLOWS:

- NOTIFY ALL RESIDENTS AND BUSINESS OWNERS OF ANY WORK ADJACENT TO PROPERTIES WITHIN 48 HOURS OF WORK OCCURRING.
- PROVIDE TEMPORARY WATER SERVICE TO THOSE INTERRUPTED BY WORK OCCURRING TO FACILITATE THIS PROJECT.
- REMOVE AND REPLACE WATER MAINLINES AND SERVICES.
- SUCCESSFUL CHLORINATION AND BACTERIAL TESTING PER AMERICAN WATERWORKS ASSOCIATION (AWWA) STANDARDS.

ABBREVIATIONS

AB	— AGGREGATE BASE	O.C.	— ON CENTER
AC	— ASPHALT CONCRETE	OD	— OUTSIDE DIAMETER
ACP	— ASBESTOS CEMENT PIPE	PCC	— PORTLAND CEMENT CONCRETE
BOT	— BOTTOM	PL	— PROPERTY LINE
BOTW	— BOTTOM WALL	PP	— POWER POLE
BW	— BACK OF WALK	PSF	— POUNDS PER SQUARE FOOT
C&G	— CURB AND GUTTER	PSI	— POUNDS PER SQUARE INCH
CL	— CENTER LINE	PSIG	— POUNDS PER SQUARE INCH GAGE
CO	— CLEANOUT	PVC	— POLYVINYL CHLORIDE PLASTIC
CONC	— CONCRETE	PVMT	— PAVEMENT
CY	— CUBIC YARD	PVT	— PRIVATE
DI	— DRAIN INLET	QTY	— QUANTITY
DIAM	— DIAMETER	R	— RADIUS
DIM	— DIMENSION	RC	— RELATIVE COMPACTION
DTL	— DETAIL	RCP	— REINFORCED CONCRETE PIPE
(E)	— EXISTING	REQD	— REQUIRED
ELEC	— ELECTRICAL	R.O.W.	— RIGHT OF WAY
ELEV	— ELEVATION	RT	— RIGHT
ENGR	— ENGINEER	SD	— STORM DRAIN
EP	— EDGE OF PAVEMENT	SDMH	— STORM DRAIN MANHOLE
FG	— FACE OF CURB	SECT	— SECTION
FG	— FINISHED GRADE	SL	— SLOPE
FH	— FIRE HYDRANT	SHT	— SHEET
FL	— FLOWLINE	SPEC	— SPECIFICATION
G	— GAS	SO	— SQUARE
GPM	— GALLONS PER MINUTE	SQFT	— SQUARE FEET
GV	— GATE VALVE	SS	— SANITARY SEWER
HDPE	— HIGH DENSITY POLYETHYLENE PIPE	SSMH	— SANITARY SEWER MANHOLE
HT	— HEIGHT	STA	— STATION
HZ	— HORIZONTAL	STD	— STANDARD
ID	— INNER DIAMETER	STL	— STEEL
IN	— INCH	SW	— SIDEWALK
JP	— JUNCTION POLE	SYMM	— SYMMETRICAL
KW	— KILOWATT	TEMP	— TEMPORARY
LB	— POUND	TG	— TOP OF GRATE
LF	— LINEAR FEET	TOW	— TOP OF WALL
MATL	— MATERIAL	(TYP)	— TYPICAL
MAX	— MAXIMUM	US	— UNDERGROUND
MECH	— MECHANICAL	UP	— UTILITY POLE
MH	— MANHOLE	UTIL	— UTILITY
MIN	— MINIMUM	V	— VOLT
MISC	— MISCELLANEOUS	VCP	— VITRIFIED CLAY PIPE
MJ	— MECHANICAL JOINT	W	— WATERLINE
(N)	— NEW	WM	— WATER METER
NO.	— NUMBER	WV	— WATER VALVE
NTS	— NOT TO SCALE	YD	— YARD

LEGEND

	STATION LINE		MANHOLE
	<E> EDGE OF PAVEMENT & DIRT		STORM DRAIN INLETS
	SANITARY SEWER LINE		UTILITY POLE
	STORM DRAIN LINE		SIGN & POST
	WATER LINE		SEWER CLEANOUT
	GAS LINE		WATER METER BOX
	WATER LINE TO BE ABANDONED		WATER VALVE
	WATER LINE TO BE REMOVED		FIRE HYDRANT
	SURFACE DRAINAGE DIRECTION		MONUMENT
	ADA RAMP SLOPE MARKING		FLANGE
	STREET LIGHT		ELBOW
	(N - NEW, R - REMOVE, A - ABANDON)		45 DEGREE BEND
	LENGTH OF PIPE, LINEAR-FOOT		TEE
	PIPE DIAMETER, INCHES		CROSS
	MATERIAL TYPE		REDUCER
			GATE VALVE WITH MECHANICAL JOINT
			CAP LINE

GENERAL NOTES:

- IT IS THE RESPONSIBILITY OF THE CONTRACTOR TO THOROUGHLY EXAMINE THE JOB SITE, THE CONTRACT SPECIFICATIONS, AND THESE PLANS PRIOR TO SUBMITTING THEIR BID. NO ADDITIONAL PAYMENT SHALL BE MADE BY THE CITY FOR ANY EXPENSE THE CONTRACTOR MAY INCUR AS A RESULT OF THEIR FAILURE TO ADEQUATELY ACQUAINT THEMSELVES WITH THE EXTENT OF THE WORK TO BE DONE, THE GENERAL SITE CONDITIONS, OR THE REQUIREMENTS OF THE PLANS, CONTRACT DOCUMENTS, GENERAL PROVISIONS, SPECIAL PROVISIONS, AND REFERENCED SPECIFICATIONS.
- THE CONTRACTOR SHALL POSSESS A CLASS 'A' (GENERAL ENGINEERING) CONTRACTOR'S LICENSE, AS WELL AS A CITY OF ARCATA BUSINESS LICENSE, AT THE TIME THE CONTRACT IS AWARDED. ANY SUBCONTRACTOR SHALL HAVE THE APPROPRIATE LICENSE FOR THE WORK BEING PERFORMED.
- IF THE CONTRACTOR WISHES TO USE WATER FROM THE CITY OF ARCATA WATER DISTRIBUTION SYSTEM DURING THE COURSE OF THIS PROJECT, THEY SHALL OBTAIN AND ATTACH A DOUBLE CHECK VALVE AT THE POINT WHERE THEY CONNECTS TO THE CITY WATER SYSTEM (I.E. AT A HYDRANT, WATER SERVICE, BLOW-OFF, ETC.). THE DOUBLE CHECK VALVE SHALL BE TESTED AND CERTIFIED BY EITHER A CERTIFIED TESTER OR THE CITY OF ARCATA AND APPROVED BY THE ENGINEER PRIOR TO USE. THE CONTRACTOR SHALL BE RESPONSIBLE FOR THE MAINTENANCE AND PROTECTION OF THE DOUBLE CHECK VALVE.
- THE CONTRACTOR SHALL NOT USE THE PUBLIC RIGHT-OF-WAY FOR LONG TERM STAGING OR MATERIAL STORAGE. DURING THE WORK DAY, THE CONTRACTOR MAY USE THE WORK AREA FOR STORAGE OF PROJECT MATERIALS AND EQUIPMENT THAT WILL BE USED THAT DAY; HOWEVER, AT THE END OF THE DAY, THE WORK SITE SHALL BE CLEANED TO THE SATISFACTION OF THE ENGINEER.
- THIS IS A PREVAILING WAGE PROJECT.
- THE CONTRACTOR SHALL SECURE THE CONSTRUCTION SITE DURING NON-WORKING HOURS AS APPROVED BY THE ENGINEER.
- THE CONTRACTOR SHALL SUBMIT TO THE ENGINEER FOR REVIEW A MINIMUM OF FOUR (4) COPIES OF THE MANUFACTURERS' PRODUCT INFORMATION CUT SHEETS INDICATING DIMENSIONS FOR ALL MANUFACTURED AND PRECAST ITEMS PROPOSED FOR USE. THE CITY WILL KEEP THREE (3) COPIES AND RETURN THE REMAINING COPIES TO THE CONTRACTOR AFTER APPROVAL.
- ALL MATERIALS AND EQUIPMENT SHALL BE INSTALLED PER MANUFACTURERS' RECOMMENDATIONS.
- ALL GRADES SHOWN ON THE PLANS SHALL BE SUBJECT TO ADJUSTMENT IN THE FIELD BY THE ENGINEER.
- THE CONTRACTOR SHALL SUBMIT A PROPOSED CONSTRUCTION SCHEDULE TO THE ENGINEER AT OR PRIOR TO THE PRECONSTRUCTION MEETING SHOWING THE ORDER IN WHICH THEY INTEND TO CONSTRUCT ALL PORTIONS OF THIS PROJECT. THE ENGINEER SHALL PROVIDE EITHER APPROVAL OF THE CONTRACTOR'S SCHEDULE OR A LIST OF PROPOSED CHANGES TO THE SCHEDULE PRIOR TO CONSTRUCTION, AND THE CONTRACTOR SHALL ABIDE BY THAT APPROVED SCHEDULE THROUGHOUT THE COURSE OF THE PROJECT UNLESS OTHERWISE DIRECTED BY THE ENGINEER.
- SEVERAL ITEMS OF WORK SHOWN ON THESE PLANS MUST BE COMPLETED IN A SINGLE DAY. THE CONTRACTOR SHALL TAKE THIS REQUIREMENT INTO ACCOUNT WHEN PREPARING THEIR BID AND THEIR WORK PLAN TO ENSURE THAT A SUFFICIENT AMOUNT OF PERSONNEL AND EQUIPMENT ARE ONSITE AND AVAILABLE TO ALLOW THE WORK TO BE COMPLETED AS REQUIRED.
- ALL WORKMANSHIP AND MATERIALS SHALL CONFORM TO THE CURRENT VERSION OF THE STATE OF CALIFORNIA DEPARTMENT OF TRANSPORTATION (CALTRANS) STANDARD PLANS & SPECIFICATIONS, AND THE CONTRACT SPECIAL PROVISIONS FOR THIS PROJECT, UNLESS SHOWN OTHERWISE.
- QUANTITIES OF ITEMS, LENGTH OF PROJECT, AND SITE CONDITIONS SHOWN IN THE PLANS ARE APPROXIMATE. ALL MATERIALS SHALL BE FURNISHED AND INSTALLED BY THE CONTRACTOR UNLESS OTHERWISE NOTED.
- CONTRACTOR AGREES TO ASSUME SOLE AND COMPLETE RESPONSIBILITY FOR THE JOB SITE DURING THE COURSE OF CONSTRUCTION OF THIS PROJECT, INCLUDING SAFETY OF ALL PERSONS AND PROPERTY; THAT THIS REQUIREMENT SHALL APPLY CONTINUOUSLY AND NOT BE LIMITED TO NORMAL WORKING HOURS; AND THAT THE CONTRACTOR SHALL DEFEND, INDEMNIFY, AND HOLD THE CITY AND THEIR REPRESENTATIVES HARMLESS FROM ANY AND ALL LIABILITY, REAL AND/OR ALLEGED, IN CONJUNCTION WITH THE PERFORMANCE OF THIS PROJECT.
- CONTRACTOR SHALL BE HELD RESPONSIBLE FOR ANY AND ALL DAMAGES TO EXISTING STRUCTURES, ROADS, RAILROAD TRACK AND TRACK BED, AND UTILITIES DURING CONSTRUCTION. ALL DAMAGE SHALL SHALL BE RESTORED TO EQUAL OR BETTER CONDITION AT THE CONTRACTOR'S EXPENSE.
- A SET OF SIGNED WORKING DRAWINGS AND A SET OF SPECIFICATIONS WILL BE KEPT AT ALL TIMES AT THE JOB SITE ON WHICH ALL CHANGES OR VARIATIONS IN THE WORK, INCLUDING ALL EXISTING UTILITIES, ARE TO BE RECORDED AND/OR CORRECTED DAILY AND SUBMITTED TO THE ENGINEER WHEN THE WORK TO BE DONE IS COMPLETED.
- CONTRACTOR SHALL NOTIFY THE ENGINEER AT LEAST 72 HOURS IN ADVANCE OF COMMENCEMENT OF ANY PART OF THE WORK AND SHALL COORDINATE CONSTRUCTION SCHEDULE WITH CITY ENGINEER TO MINIMIZE IMPACT TO RESIDENTS.
- THE DESIGN FEATURES INCLUDING HORIZONTAL AND VERTICAL ALIGNMENTS, TYPICAL SECTIONS, APPROACHES, AND OTHER DESIGN DETAILS SHOWN ON THESE DESIGN PLANS SHALL NOT BE ALTERED OR MODIFIED IN ANY WAY DURING CONSTRUCTION WITHOUT THE EXPRESSED, WRITTEN DIRECTION AND APPROVAL OF THE ENGINEER AND/OR CONTRACTING OFFICER. DRAINAGE STRUCTURES SHALL BE INSTALLED AS SHOWN THE PLANS WITH ONLY MINOR CORRECTIONS IN LOCATION SKEW AND/OR ELEVATIONS AS NEEDED TO FIT FIELD CONDITIONS AS DETERMINED BY THE ENGINEER OR OWNER'S REPRESENTATIVE.
- NO WORK SHALL BE PERFORMED OUTSIDE OF THE DESIGNATED CONSTRUCTION LIMITS WITHOUT THE APPROVAL OF THE CITY OR THEIR REPRESENTATIVE.
- THE CONTRACTOR IS RESPONSIBLE FOR COORDINATING STAGING AREAS WITH THE CITY OF ARCATA. ALL STAGING AREAS WITHIN THE RIGHT-OF-WAY SHALL BE PRE-APPROVED BY THE CITY.
- UPON COMPLETION OF THE CONSTRUCTION PROJECT, THE CONTRACTOR SHALL LEAVE THE PROJECT AREA FREE OF DEBRIS AND UNUSED MATERIAL. ALL DAMAGE CAUSED BY THE CONTRACTOR SHALL BE RESTORED TO AN "AS GOOD OR BETTER" CONDITION.
- EXISTING FENCING SHALL REMAIN IN PLACE AND UNDISTURBED BY CONSTRUCTION OPERATIONS UNLESS OTHERWISE SHOWN ON THE PLANS. CONTRACTOR SHALL BE HELD RESPONSIBLE FOR ANY AND ALL DAMAGES TO FENCES DURING CONSTRUCTION. ALL DAMAGE SHALL SHALL BE RESTORED TO EQUAL OR BETTER CONDITION AT THE CONTRACTOR'S EXPENSE.
- EXISTING SIGN SYSTEMS SHALL BE PROTECTED THROUGHOUT CONSTRUCTION ACTIVITY UNLESS NOTED OTHERWISE ON PLANS. CONTRACTOR SHALL BE HELD RESPONSIBLE FOR ANY AND ALL DAMAGES TO SIGNS DURING CONSTRUCTION. ALL DAMAGE SHALL BE RESTORED TO EQUAL OR BETTER CONDITION AT THE CONTRACTOR'S EXPENSE.
- CONTRACTOR IS RESPONSIBLE FOR ADDRESSING STORM WATER DRAINAGE AND DEWATERING OF WORK AREAS DURING CONSTRUCTION.
- DURING WET WEATHER PERIODS, CONTRACTOR IS RESPONSIBLE FOR SEQUENCING CONSTRUCTION IN A MANNER TO MINIMIZE IMPACT ON OPEN EARTHWORK AND COMPACTION OPERATIONS.

UTILITY NOTES:

- THE CONTRACTOR SHALL CONTACT UNDERGROUND SERVICE ALERT (USA) AT (800) 227-2600 AT LEAST FORTY-EIGHT (48) HOURS, BUT NOT LESS THAN TWO (2) WORKING DAYS, PRIOR TO ANY DEMOLITION OR EXCAVATION AND REQUEST FIELD MARKINGS OF ALL UNDERGROUND UTILITIES.
- THE CITY OF ARCATA DOES NOT GUARANTEE THE COMPLETENESS OR ACCURACY OF THE EXISTING UNDERGROUND UTILITIES SHOWN ON THESE PLANS. THE CONTRACTOR IS SOLELY RESPONSIBLE FOR FIELD VERIFYING ANY POTENTIAL UTILITY CONFLICTS BETWEEN EXISTING UNDERGROUND UTILITIES AND THE WORK SHOWN ON THESE PLANS, INCLUDING BOTH POTENTIAL UTILITY CONFLICTS SHOWN ON THESE PLANS AND POTENTIAL UTILITY CONFLICTS NOT SHOWN ON THESE PLANS BUT EITHER LOCATED, FOUND, OR MARKED IN THE FIELD. WHERE POTENTIAL CONFLICTS ARE FOUND, THE CONTRACTOR SHALL TAKE WHATEVER MEASURES ARE NEEDED (INCLUDING PRELIMINARY POTHOLOGING OF THE UTILITIES AT THE POTENTIAL CONFLICT LOCATION) PRIOR TO PERFORMING WORK IN THE AREA TO ALLOW TIME FOR THE RESPONSIBLE AGENCY TO CORRECT THE CONFLICT. NO ADDITIONAL PAYMENT SHALL BE MADE BY THE CITY FOR ANY EXPENSE THE CONTRACTOR MAY INCUR AS A RESULT OF THEIR FAILURE TO ADEQUATELY EXPLORE, IN THE OPINION OF THE ENGINEER, POTENTIAL UTILITY CONFLICTS.
- WHEN WATER OR SEWER SERVICE INTERRUPTION IS NECESSARY, THE CONTRACTOR SHALL NOTIFY ALL AFFECTED PERSONS AT LEAST FORTY-EIGHT (48) HOURS IN ADVANCE OF THE ANTICIPATED SERVICE INTERRUPTION. REFER TO THE CONTRACT SPECIAL PROVISIONS FOR ADDITIONAL REQUIREMENTS.
- THE CONTRACTOR IS RESPONSIBLE FOR REPAIRING AND/OR REPLACING, TO THE SATISFACTION OF THE ENGINEER, ANY UTILITIES THAT ARE DAMAGED BY THEIR ACTIVITIES.
- AT ANY LOCATION WHERE THE CONTRACTOR'S ACTIVITIES MAY EXPOSE AN ADJACENT WATER MAIN, THE CONTRACTOR SHALL EITHER RESTRAIN THE WATER MAIN OR REQUEST THAT THE CITY SHUT OFF WATER SERVICE IN THE AREA AND DEPRESSURIZE THE WATER MAIN. ANY WATER SHUTDOWN WILL REQUIRE THAT THE CONTRACTOR NOTIFY ALL AFFECTED RESIDENTS AND BUSINESSES WITHIN BOTH THE PRIMARY SHUTDOWN AREA AND THE BACKUP SHUTDOWN AREA AT LEAST TWO (2) WORKING DAYS IN ADVANCE OF THE ANTICIPATED SERVICE INTERRUPTION. THE CITY WILL PROVIDE THE SHUTDOWN NOTIFICATION FLIERS (ONE FOR PRIMARY AREAS, ONE FOR BACKUP AREAS); HOWEVER, THE CONTRACTOR SHALL BE RESPONSIBLE FOR CORRECTLY FILLING OUT, DUPLICATING, AND DISTRIBUTING THE FLIERS AS LISTED ABOVE. THE CONTRACTOR SHALL MAKE AN ALLOWANCE IN BOTH THEIR BID AND THEIR PROJECT SCHEDULE TO ALLOW FOR NOTIFICATION OF RESIDENTS AND BUSINESSES, AND NO ADDITIONAL PAYMENT WILL BE MADE BY THE CITY FOR ANY EXPENSES INCURRED BY THE CONTRACTOR TO COMPLETE THE REQUIRED NOTIFICATIONS
- ALL EXISTING UTILITIES AND TIE-IN POINTS SHOULD BE CONSIDERED ACTIVE UTILITIES UNLESS OTHERWISE INDICATED.
- STRUCTURAL EXCAVATION AND BACKFILL OF CULVERTS AND OTHER DRAINAGE STRUCTURES SHALL BE CONSIDERED INCIDENTAL TO INSTALLATION OF THE STRUCTURE. EXCESS MATERIAL REMOVED MAY BE USED TO REBUILD APPROACHES OR MAY BE PLACED ALONG ROADWAY SHOULDERS IN AREAS AS DIRECTED BY THE OWNER'S REPRESENTATIVE.
- THE LOCATIONS OF PIPES MAY BE MODIFIED AS NECESSARY TO FIT ACTUAL FIELD CONDITIONS AS DETERMINED BY THE CITY OR THEIR REPRESENTATIVE.
- EXISTING PIPES & CULVERTS TO BE REMOVED SHALL BECOME PROPERTY OF THE CONTRACTOR AND SHALL BE DISPOSED IN ACCORDANCE WITH THE PROJECT SPECIFICATIONS & STATE STANDARDS AND CODES.
- CONSTRUCTION ACTIVITY WILL TAKE PLACE IN THE VICINITY OF OVERHEAD ELECTRIC TRANSMISSION LINES. IT IS THE CONTRACTOR'S RESPONSIBILITY TO BE AWARE OF, AND OBSERVE, THE MINIMUM CLEARANCES FOR WORKERS AND EQUIPMENT OPERATING NEAR HIGH VOLTAGE ELECTRIC LINES AS SET OUT IN THE HIGH VOLTAGE SAFETY ORDERS OF THE CALIFORNIA DIVISION OF INDUSTRIAL SAFETY AS WELL AS OTHER APPLICABLE SAFETY REGULATIONS.

TRAFFIC CONTROL NOTES:

- THE CONTRACTOR SHALL PROVIDE TEMPORARY TRAFFIC CONTROL IN ACCORDANCE WITH THE CURRENT VERSION OF THE CALIFORNIA MANUAL OF UNIFORM TRAFFIC CONTROL DEVICES (MUTCD). A TRAFFIC CONTROL PLAN WILL NEED TO BE SUBMITTED AND APPROVED BY THE CITY PRIOR TO ANY WORK TAKING PLACE. THE PLAN SHALL PROVIDE ACCESS AT ALL TIMES FOR RESIDENTS AND EMERGENCY VEHICLES AND COMPLY WITH ALL REQUIRED PERMITS AND OTHER GUIDELINES LISTED ON THESE PLANS AND IN THE SPECIFICATIONS.
- CONTRACTOR SHALL PROVIDE AND MAINTAIN SUFFICIENT TEMPORARY BARRIERS TO PROVIDE FOR THE SAFETY OF THE STAFF AND PUBLIC TO THE SATISFACTION OF THE ENGINEER.

EROSION CONTROL NOTES:


- CONTRACTOR IS RESPONSIBLE FOR EROSION AND SEDIMENT CONTROL. CONTRACTOR SHALL USE CALTRANS STORMWATER QUALITY HANDBOOKS, CONSTRUCTION CONTRACTOR'S GUIDE AND SPECIFICATIONS.
- DURING WET WEATHER PERIODS, CONTRACTOR IS RESPONSIBLE FOR SEQUENCING CONSTRUCTION IN A MANNER TO MINIMIZE IMPACT ON OPEN EARTHWORK AND COMPACTION OPERATIONS.
- ALL NEWLY GRADED AREAS WITHIN THE PROJECT LIMITS, INCLUDING AREAS COVERED WITH EROSION CONTROL BLANKETS ARE TO BE SEEDED. THE PERMANENT PLANTINGS/SEED MIXTURE SHALL BE AS DIRECTED IN THE CONTRACT SPECIAL PROVISIONS, SWPPP OR THESE PLANS.
- AFTER SEEDING, A MULCH CONSISTING OF GRASS, HAY OR STRAW SHALL BE BLOWN ON TO ALL NEWLY SEEDED AREAS AT A RATE OF TWO TONS PER ACRE.
- IT WILL BE THE RESPONSIBILITY OF THE CONTRACTOR TO FIX ANY DEFICIENCIES INDICATED BY THE OWNER OR THE OWNERS REPRESENTATIVE TO PREVENT EROSION AND CONTROL SEDIMENT.
- PRIOR TO FINAL ACCEPTANCE TEMPORARY SEDIMENT CONTROL MEASURES SHALL BE REMOVED AND ALL AREAS OF SOIL DISTURBANCE, INCLUDING BUT NOT LIMITED TO CUT AND FILL SLOPES, SWALES AND DITCHES SHALL BE STABILIZED.

EARTHWORK NOTES:

- THE CONTRACTOR SHALL TAKE ALL NECESSARY PRECAUTIONS AND MEASURES TO PREVENT THE FLOW OF WATER, INCLUDING GROUNDWATER, FROM ENTERING ALL EXCAVATIONS WITHIN THE WORK AREA. IF WATER DOES ENTER AN EXCAVATION, SUCH WATER, WHEN REMOVAL IS NECESSARY TO PROCEED WITH THE WORK, SHALL BE PUMPED TO A CONTRACTOR SUPPLIED HOLDING TANK FOR DISPOSAL.
- THE CONTRACTOR SHALL MAKE ARRANGEMENTS FOR DISPOSAL SITES AND SHALL PAY ANY AND ALL COSTS INVOLVED. WHEN ANY MATERIAL IS TO BE DISPOSED OF OUTSIDE THE PROJECT WORK AREA, THE CONTRACTOR SHALL OBTAIN BOTH A WRITTEN AGREEMENT BETWEEN THE PROPERTY OWNER AND THE CONTRACTOR AND A COPY OF THE PERMIT THAT ALLOWS MATERIAL DISPOSAL AT THE SUBJECT SITE. THE AGREEMENT SHALL GRANT THE CONTRACTOR PERMISSION TO USE THE PRIVATE PROPERTY AS A DISPOSAL SITE AND SHALL ABSOLVE THE CITY OF ALL RESPONSIBILITY FOR CONSEQUENCES OF SUCH USAGE. THE PERMIT COPY SHALL BE OBTAINED FROM THE PROPERTY OWNER, THE HUMBOLDT COUNTY BUILDING DEPARTMENT, THE CITY OF ARCATA BUILDING DEPARTMENT, OR OTHER REGULATORY AGENCY AS APPROPRIATE. BOTH THE AGREEMENT AND PERMIT SHALL BE FILED WITH THE ENGINEER PRIOR TO THE USE OF THE PROPERTY, AND THE CONTRACTOR SHALL OBTAIN PERMISSION FROM THE ENGINEER TO DISPOSE OF THE MATERIAL AT THE PROPOSED LOCATION DESIGNATED IN THE AGREEMENT AND ON THE PERMIT BEFORE ANY MATERIAL IS DISPOSED OF ON SAID PROPERTY. REFER TO THE CONTRACT SPECIAL PROVISIONS FOR ADDITIONAL REQUIREMENTS.
- DISPOSAL OF MATERIALS IS NOT PERMITTED WITHIN THE PUBLIC RIGHT-OF-WAY UNLESS OTHERWISE SPECIFIED ON THE PLANS.
- THE CONTRACTOR IS RESPONSIBLE FOR FIELD VERIFICATION OF ALL SURVEY DATA. CONTRACTOR IS RESPONSIBLE FOR ESTABLISHING RIGHT-OF-WAY LINES, SLOPE EASEMENTS, AND ALL HORIZONTAL AND VERTICAL CONTROL PRIOR TO CONSTRUCTION.
- CONTRACTOR SHALL BE RESPONSIBLE FOR THE SAFETY OF ALL CONSTRUCTION. ADEQUATE SHORING BRACING, TIES, AND SUPPORTS SHALL BE USED TO PROVIDE PROPER TEMPORARY INTEGRITY DURING ALL PHASES OF CONSTRUCTION.
- ALL EXISTING LANDSCAPED AND UNPAVED AREAS WHICH ARE DISTURBED BY CONSTRUCTION OR EARTHWORK OPERATIONS SHALL BE HAND RAKED SMOOTH AND RETURNED TO ORIGINAL EXISTING CONDITIONS.
- ALL DITCHES, SWALES, GUTTERS, ETC. SHOULD BE CONSIDERED ACTIVE STORM CONVEYANCES UNLESS OTHERWISE INDICATED. CONTRACTOR IS RESPONSIBLE FOR ADDRESSING STORM WATER DRAINAGE AND DEWATERING OF WORK AREAS DURING CONSTRUCTION.
- UNSUITABLE EXCAVATED MATERIAL, AS DETERMINED BY THE ENGINEER, SHALL BE REMOVED FROM SITE AND DISPOSED OF IN A MANNER CONSISTENT WITH APPLICABLE REGULATIONS SUCH AS CITY OR COUNTY GRADING ORDINANCES. DOCUMENT, REQUEST PERMISSION, AND DISCLOSE ANY ENVIRONMENTAL REGULATIONS WHEN PROPERLY DISPOSING OF UNSUITABLE MATERIALS TAKEN FROM THE SITE, AS REQUESTED BY THE ENGINEER.

SURVEYING NOTES:

- ALL ELEVATIONS SHOWN ON THESE PLANS ARE ON THE STATE PLANE CALIFORNIA ZONE 1 NAD 1983 DATUM.
- CONTRACTOR IS RESPONSIBLE FOR CONSTRUCTION STAKING AND SHALL ARRANGE FOR STAKING WITH A CALIFORNIA LICENSED SURVEYOR. TWO-DIMENSIONAL COMPUTER AIDED DESIGN (CAD) FILES WILL BE AVAILABLE AND PROVIDED TO THE CONTRACTOR PRIOR TO CONSTRUCTION. STAKING WILL BE REVIEWED BY OWNER FOR CONFORMANCE TO DESIGN PRIOR TO CONSTRUCTION.
- CONTRACTOR SHALL VERIFY LOCATIONS, ELEVATIONS, DISTANCES, AND FEATURES THAT MAY AFFECT THE WORK. SHOULD EXISTING CONDITIONS DIFFER FROM THOSE SHOWN OR INDICATED, OR IF IT APPEARS THAT THESE PLANS, STANDARD SPECIFICATIONS, AND SPECIAL PROVISIONS DO NOT ADEQUATELY DETAIL THE WORK TO BE DONE, CONTRACTOR SHALL NOTIFY THE ENGINEER PRIOR TO CONTINUING WITH ANY RELATED WORK. NO ALLOWANCE WILL BE MADE ON THEIR BEHALF FOR ANY EXTRA EXPENSE RESULTING FROM FAILURE OR NEGLECT IN DETERMINING THE CONDITIONS UNDER WHICH WORK IS TO BE PERFORMED. NOTED DIMENSIONS TAKE PRECEDENCE OVER SCALE.
- THE CONTRACTOR SHALL BE RESPONSIBLE FOR COORDINATING WITH THE CITY OF ARCATA ENGINEERING DEPARTMENT OR CITY SURVEYOR IN THE PRESERVATION OR PROTECTION OF SURVEY MONUMENTS, WHETHER SHOWN ON THE PLANS OR WHEN ENCOUNTERED DURING THE PROJECT.
- IF MONUMENTS HAVE BEEN IDENTIFIED IN ADVANCE BY THE CITY OF ARCATA, OR OTHERS, AND NOTED ON THE PLANS, THE CONTRACTOR SHALL MARK OR IDENTIFY LOCATIONS PRIOR TO ANY DISTURBANCE FOR PROTECTION OR PERPETUATION DURING THE PROJECT. MONUMENTS THAT WILL INEVITABLY BE DESTROYED DURING CONSTRUCTION AND ARE IDENTIFIED AS SUCH ON THE PLANS, SHALL BE RESET IN AN APPROVED MONUMENT BOX, IF APPLICABLE, OR THEIR LOCATION SHALL BE PERPETUATED. ALL EFFORTS SHOULD BE MADE TO PRESERVE AND WORK AROUND EXISTING SURVEY MONUMENTS WHEN POSSIBLE.
- ALL WORK INVOLVING INITIAL SEARCHING AND IDENTIFICATION OF MONUMENTS, INCLUDING THEIR SURVEYED LOCATIONS, IS TO BE DONE BY OR UNDER THE DISCRETION OF A LICENSED LAND SURVEYOR. A CORNER RECORD OR RECORD OF SURVEY, AS APPLICABLE, MUST BE FILED IN ACCORDANCE WITH THE PROFESSIONAL LAND SURVEYOR'S. ALL MONUMENTS RESET OR PERPETUATED MUST BE DONE BY OR UNDER THE DISCRETION OF A LICENSED LAND SURVEYOR.
- MONUMENTS NOT SHOWN ON THE PLANS THAT ARE ENCOUNTERED DURING THE PROJECT ARE TO BE PROTECTED. STOP WORK NEAR THE MONUMENT AND NOTIFY THE PROJECT ENGINEER. CONTRACTOR MUST ENLIST A LICENSED LAND SURVEYOR TO SURVEY THE EXISTING LOCATION OF THE MONUMENT AND SET REFERENCE POINTS AS NECESSARY TO PERPETUATE THE "FOUND POSITION" OF THE MONUMENT. A REPLACEMENT MONUMENT SHALL BE RESET AND DEPICTED ON A CORNER RECORD OR RECORD OF SURVEY, AS APPLICABLE. ANY ALTERNATIVE TO RESETTING A MONUMENT SHALL BE DETERMINED THROUGH THE COORDINATION WITH THE PROJECT ENGINEER AND CITY SURVEYOR.
- COSTS ASSOCIATED WITH FAILURE TO COMPLY WITH THESE PROVISIONS WILL BE BORNE BY THE CONTRACTOR.

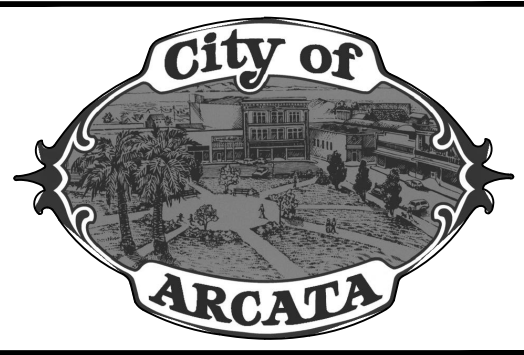

GENERAL NOTES

STEEL WATERLINE REPLACEMENT PROJECT

VARIOUS LOCATIONS

Designed By
JONATHAN A. KIRCHUBEL
Drawn By
JONATHAN A. KIRCHUBEL
Checked By
DAVID CAISSE
Approved By
NETRA B. KHATRI

Date
JANUARY 2025
Scale
N/A
Sheet
G-005
Page
5

CALL BEFORE YOU DIG
48 HR. NOTICE REQUIRED
CALL 811 OR 1-800-642-2444



SHEET KEY NOTES	
1	(N) 1" SERVICE LINE & WATER METER PER CITY STD DTL W-05
2	(N) 2" SERVICE LINE & WATER METER PER CITY STD DTL W-17
3	(N) 3 FLANGE TEE PER CITY STD DTL W-50
4	(N) 4 FLANGE CROSS PER CITY STD DTL W-50
5	(N) GATE VALVE AND BOX PER CITY STD DTL W-02
6	(N) FIRE HYDRANT, 6" FIRE LINE, & 6" GATE VALVE PER CITY STD DTL W-40
7	(N) BLOWOFF VALVE PER CITY STD DTL W-13
8	(N) 6" FIRE LINE & 6" GATE VALVE PER CITY STD DTL W-09
A	ABANDON (E) WATERLINE IN PLACE PER CITY STD DTL SS-14
R	REMOVE (E) WATERLINE, (TYP)
N	INSTALL (N) WATERLINE, (TYP)


PLAN SHEET GENERAL NOTES:

- ALL WATERLINE DIMENSIONS ARE MEASURED IN BETWEEN VALVE CLUSTERS AND INLINE VALVES AND/OR CONNECTIONS TO (E) WATERLINES (CENTER TO CENTER, REGARDLESS OF MATCHLINES AND SHEET CARRY-OVERS)
- DIMENSIONS TO (E) VALVE NUTS PROVIDED TO DETERMINE APPROXIMATE (E) WATERLINE DEPTHS. (E) END OF LINE BLOW OFF DEPTHS CAN BE ASSUMED TO BE APPROXIMATELY 3' TO 4' IN DEPTH.
- ALL WATER SERVICES SHALL BE 1" CLASS 250 POLYETHYLENE CTS PIPE UNLESS OTHERWISE NOTED
- REMOVE AND REPLACE STORM DRAIN INFRASTRUCTURE AS NEEDED FOR WATER MAIN REPLACEMENT
- SALVAGE VALVE BOXES AND LIDS, RETURN TO THE CITY OF ARCATA CORPYARD
- ANY DAMAGE TO CONCRETE COLLARS ON MANHOLES OR VALVES SHALL BE REPAIRED BY THE CONTRACTOR TO CITY STANDARD
- IF THERE ARE ANY CIRCUMSTANCES WHERE A SEWER LINE CROSSES A WATER LINE, THE LENGTH OF WATER PIPE SHALL BE CENTERED OVER THE SEWER LINE TO REDUCE THE RISK OF CROSS CONTAMINATION. SEE DETAIL
- ALL CONCRETE RELATED DEMOLITION AND REPLACEMENT TO FACILITATE WATER PIPE AND WATER METER INSTALLATION SHALL BE INCIDENTAL TO THAT ITEM OF WORK (UNLESS OTHERWISE NOTED). A MINIMUM OF ONE 5'X5' PCC PANEL WILL BE REPLACED FOR EVERY WATER METER, UNLESS OTHERWISE NOTED.
- TRENCHING & STREET PAVEMENT RESTORATION WORK SHALL BE IN ACCORDANCE WITH THE CITY STD DTL G-02 AND ST-30.
- DEMOLISH EXISTING WATERLINES AND REPLACE WITH C900 PIPE A MINIMUM OF 10 FEET IN EACH DIRECTION FROM PROPOSED VALVE CLUSTERS, UNLESS OTHERWISE NOTED.
- DEMOLITION OF EXISTING VALVE ASSEMBLIES SHALL BE INCIDENTAL TO THE VALVE INSTALLATION ITEM OF WORK.
- CONNECT ALL NEW PIPING TO EXISTING PER CITY STANDARD DETAIL W-50.

ANTOINETTE CT - PLAN VIEW
STATION 0+00 TO 2+89

ANTOINETTE CT - PLAN VIEW
STATION 0+00 TO 4+04

MARTHA CT - PLAN VIEW
STATION 0+00 TO 2+88

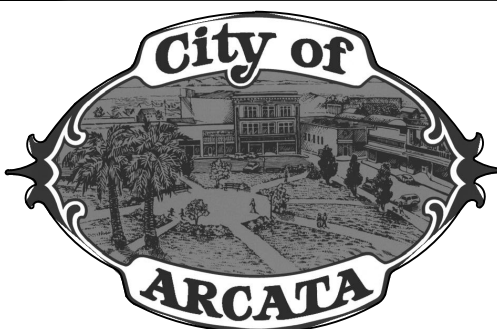

ANTOINETTE CT &
MARTHA CT

STEEL WATERLINE REPLACEMENT PROJECT

Project Address

VARIOUS LOCATIONS

Designed By

JONATHAN A. KIRCHUBEL

Drawn By

JONATHAN A. KIRCHUBEL

Checked By

DAVID CAISSE

Approved By

NETRA B. KHATRI

Date

JANUARY 2025

Sheet


C-101

Scale


1"=30'

Page

6

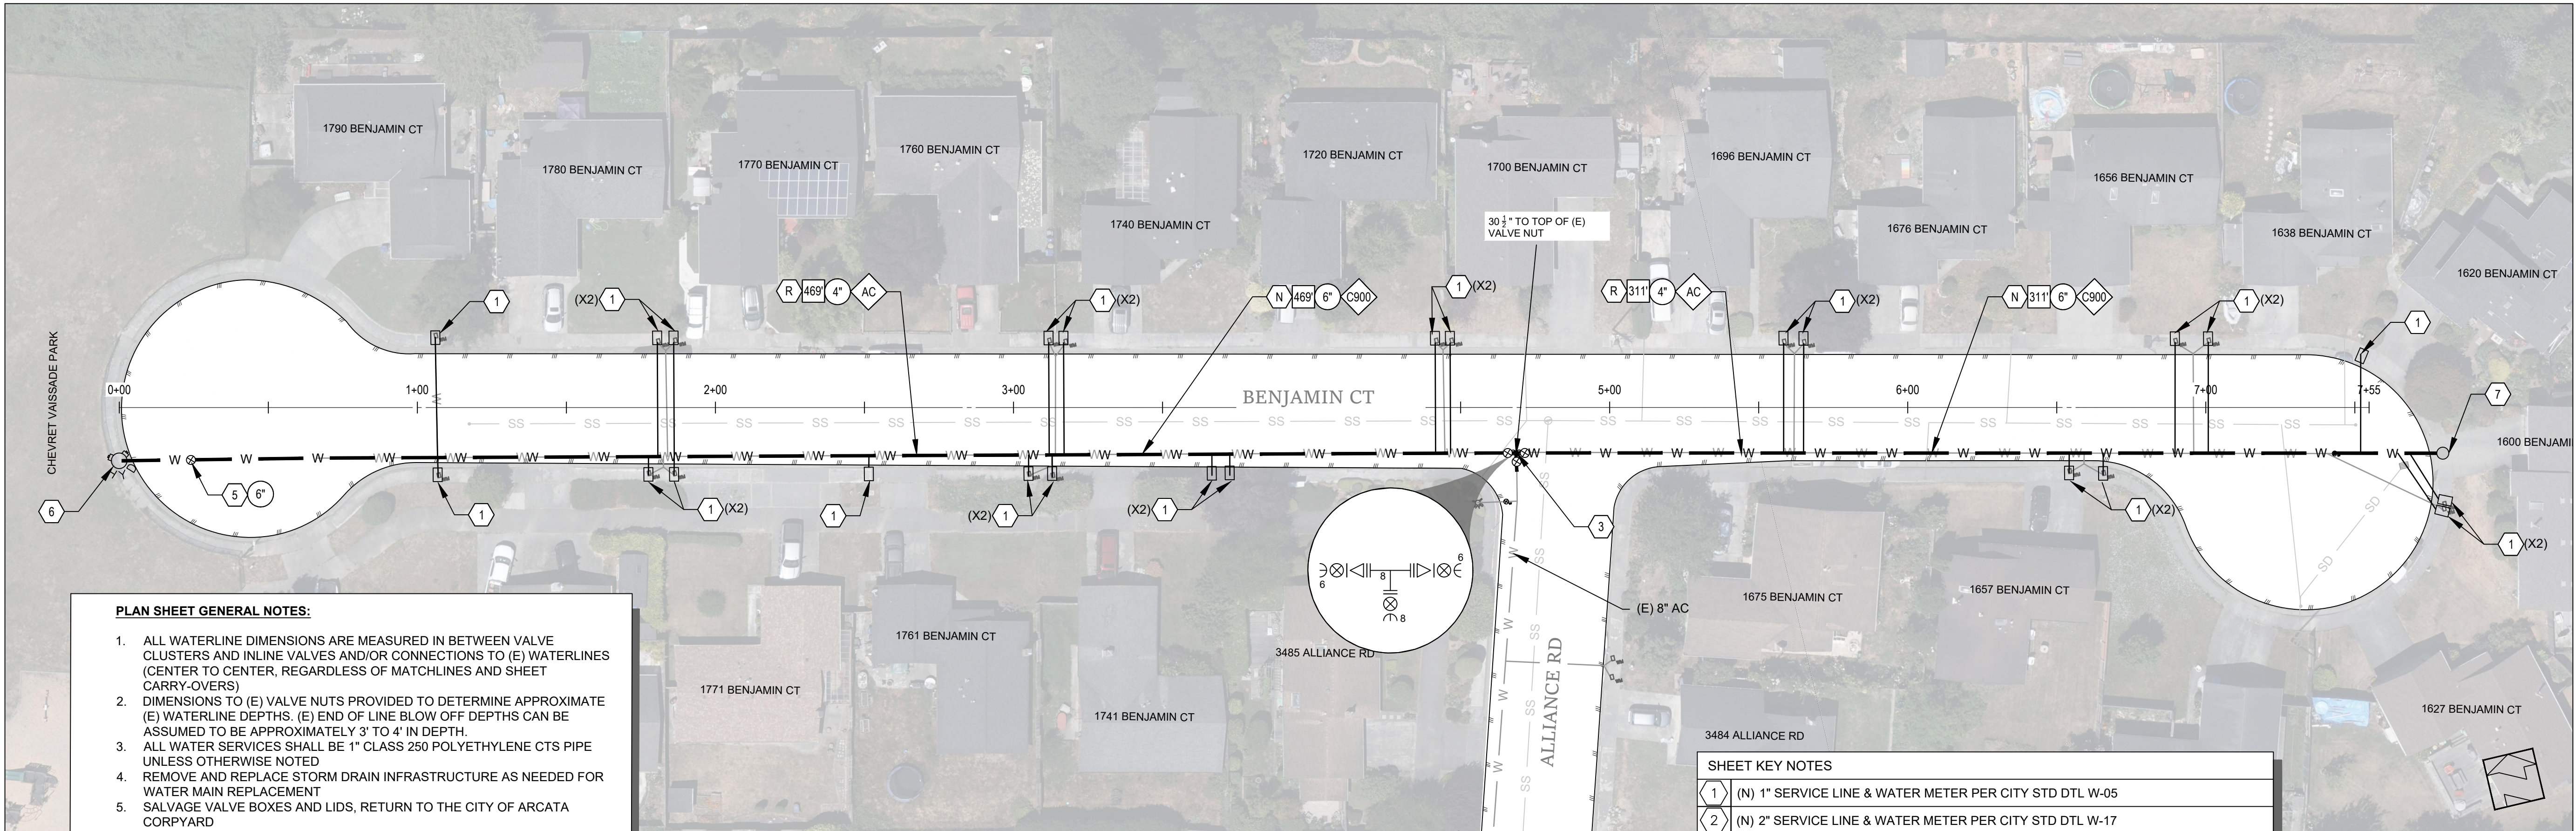

BENJAMIN CT - PLAN VIEW
STATION 0+00 TO 7+55

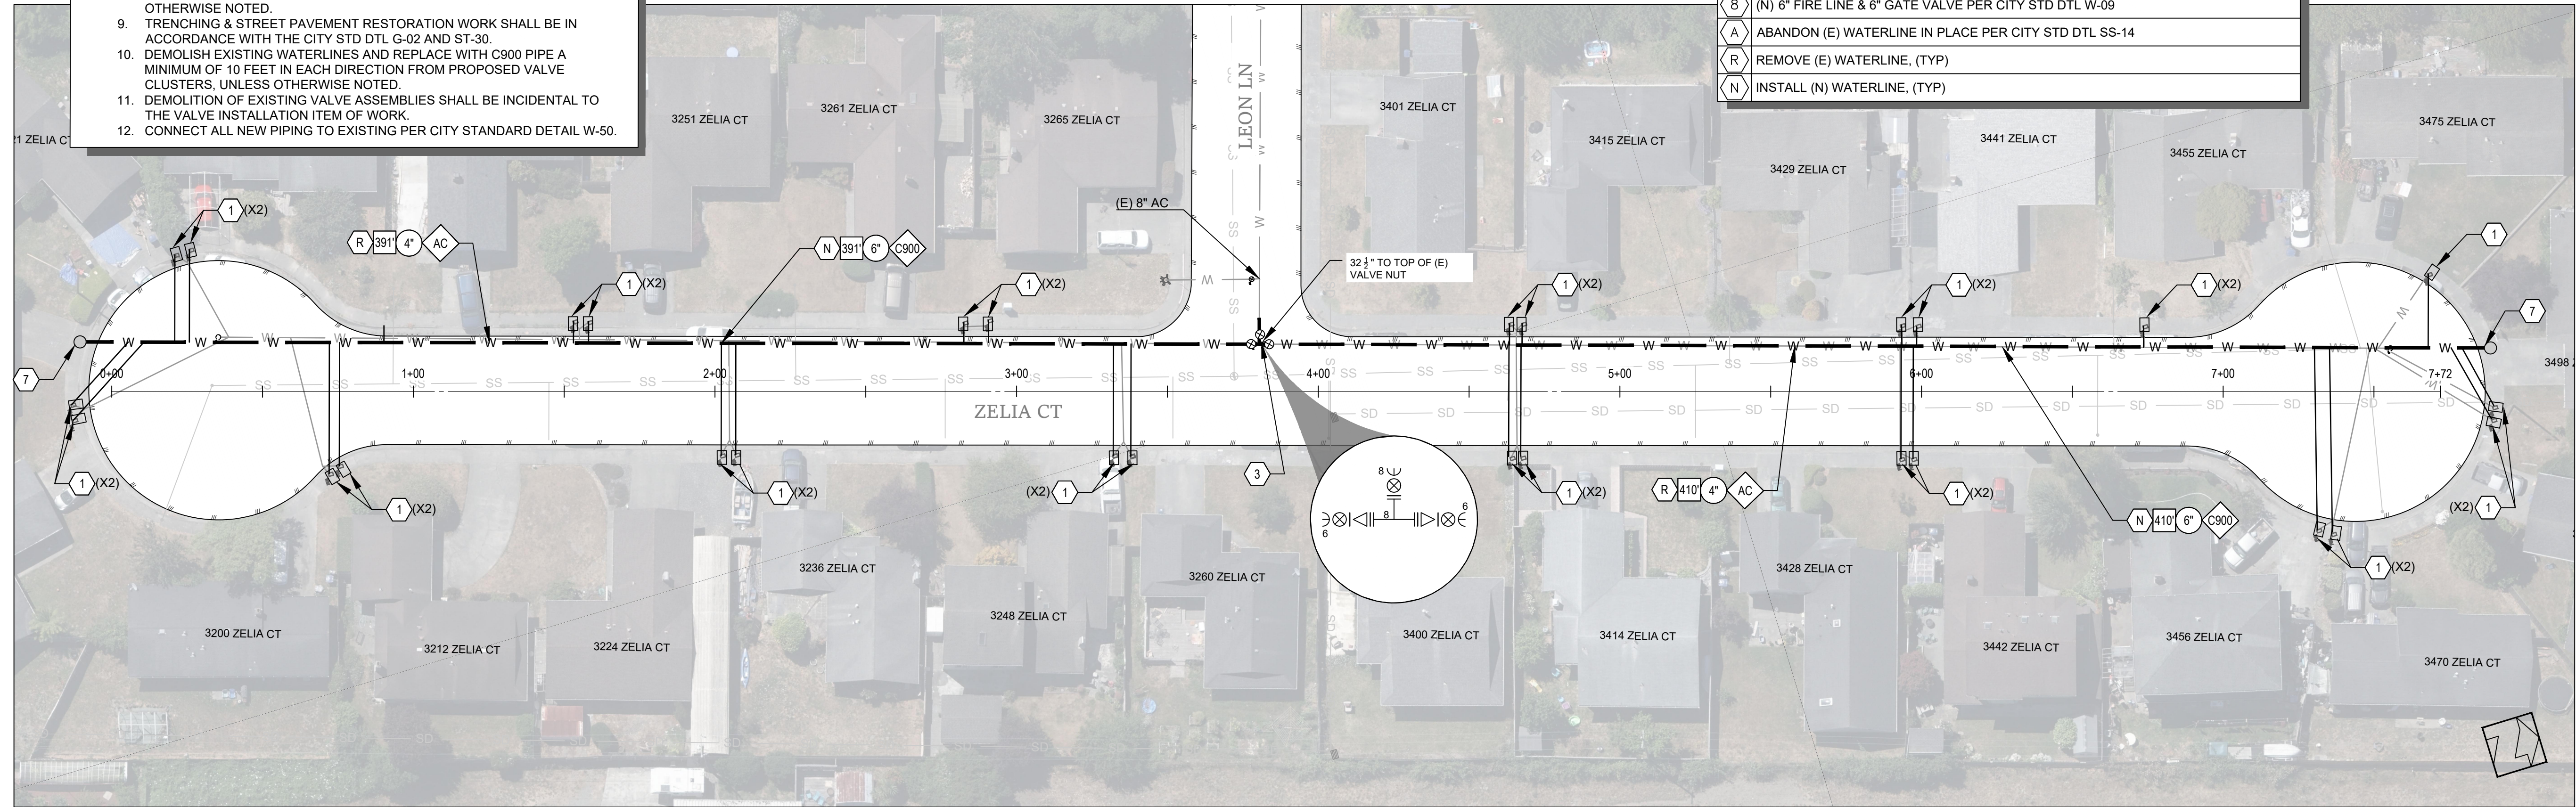


ZELIA CT - PLAN VIEW
STATION 0+00 TO 7+72

PLAN SHEET GENERAL NOTES:

1. ALL WATERLINE DIMENSIONS ARE MEASURED IN BETWEEN VALVE CLUSTERS AND INLINE VALVES AND/OR CONNECTIONS TO (E) WATERLINES (CENTER TO CENTER, REGARDLESS OF MATCHLINES AND SHEET CARRY-OVERS)
2. DIMENSIONS TO (E) VALVE NUTS PROVIDED TO DETERMINE APPROXIMATE (E) WATERLINE DEPTHS. (E) END OF LINE BLOW OFF DEPTHS CAN BE ASSUMED TO BE APPROXIMATELY 3' TO 4' IN DEPTH.
3. ALL WATER SERVICES SHALL BE 1" CLASS 250 POLYETHYLENE CTS PIPE UNLESS OTHERWISE NOTED
4. REMOVE AND REPLACE STORM DRAIN INFRASTRUCTURE AS NEEDED FOR WATER MAIN REPLACEMENT
5. SALVAGE VALVE BOXES AND LIDS, RETURN TO THE CITY OF ARCATA CORPYARD
6. ANY DAMAGE TO CONCRETE COLLARS ON MANHOLES OR VALVES SHALL BE REPAIRED BY THE CONTRACTOR TO CITY STANDARD
7. IF THERE ARE ANY CIRCUMSTANCES WHERE A SEWER LINE CROSSES A WATER LINE, THE LENGTH OF WATER PIPE SHALL BE CENTERED OVER THE SEWER LINE TO REDUCE THE RISK OF CROSS CONTAMINATION. SEE DETAIL
8. ALL CONCRETE RELATED DEMOLITION AND REPLACEMENT TO FACILITATE WATER PIPE AND WATER METER INSTALLATION SHALL BE INCIDENTAL TO THAT ITEM OF WORK (UNLESS OTHERWISE NOTED). A MINIMUM OF ONE 5'X5' PCC PANEL WILL BE REPLACED FOR EVERY WATER METER, UNLESS OTHERWISE NOTED.
9. TRENCHING & STREET PAVEMENT RESTORATION WORK SHALL BE IN ACCORDANCE WITH THE CITY STD DTL G-02 AND ST-30
10. DEMOLISH EXISTING WATERLINES AND REPLACE WITH C900 PIPE A MINIMUM OF 10 FEET IN EACH DIRECTION FROM PROPOSED VALVE CLUSTERS, UNLESS OTHERWISE NOTED.
11. DEMOLITION OF EXISTING VALVE ASSEMBLIES SHALL BE INCIDENTAL TO THE VALVE INSTALLATION ITEM OF WORK.
12. CONNECT ALL NEW PIPING TO EXISTING PER CITY STANDARD DETAIL W-50.

SHEET KEY NOTES

1	(N) 1" SERVICE LINE & WATER METER PER CITY STD DTL W-05
2	(N) 2" SERVICE LINE & WATER METER PER CITY STD DTL W-17
3	(N) 3" FLANGE TEE PER CITY STD DTL W-50
4	(N) 4" FLANGE CROSS PER CITY STD DTL W-50
5	(N) GATE VALVE AND BOX PER CITY STD DTL W-02
6	(N) FIRE HYDRANT, 6" FIRE LINE, & 6" GATE VALVE PER CITY STD DTL W-40
7	(N) BLOWOFF VALVE PER CITY STD DTL W-13
8	(N) 6" FIRE LINE & 6" GATE VALVE PER CITY STD DTL W-09
A	ABANDON (E) WATERLINE IN PLACE PER CITY STD DTL SS-14
R	REMOVE (E) WATERLINE, (TYP)
N	INSTALL (N) WATERLINE, (TYP)

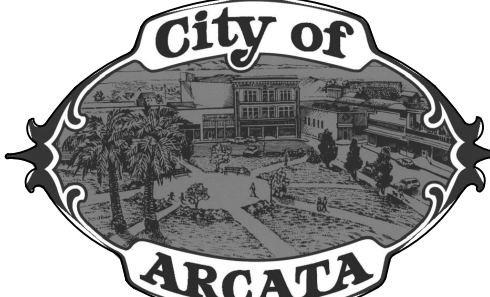

BENJAMIN CT & ZELIA CT

STEEL WATERLINE REPLACEMENT PROJECT

Project Address

VARIOUS LOCATIONS

Designed By

JONATHAN A. KIRCHUBEL

Drawn By

JONATHAN A. KIRCHUBEL

Checked By

DAVID CAISSE

Approved By

NETRA B. KHATRI

Date

JANUARY 2025

Sheet


C-102

Scale

1"=30'

Page

7

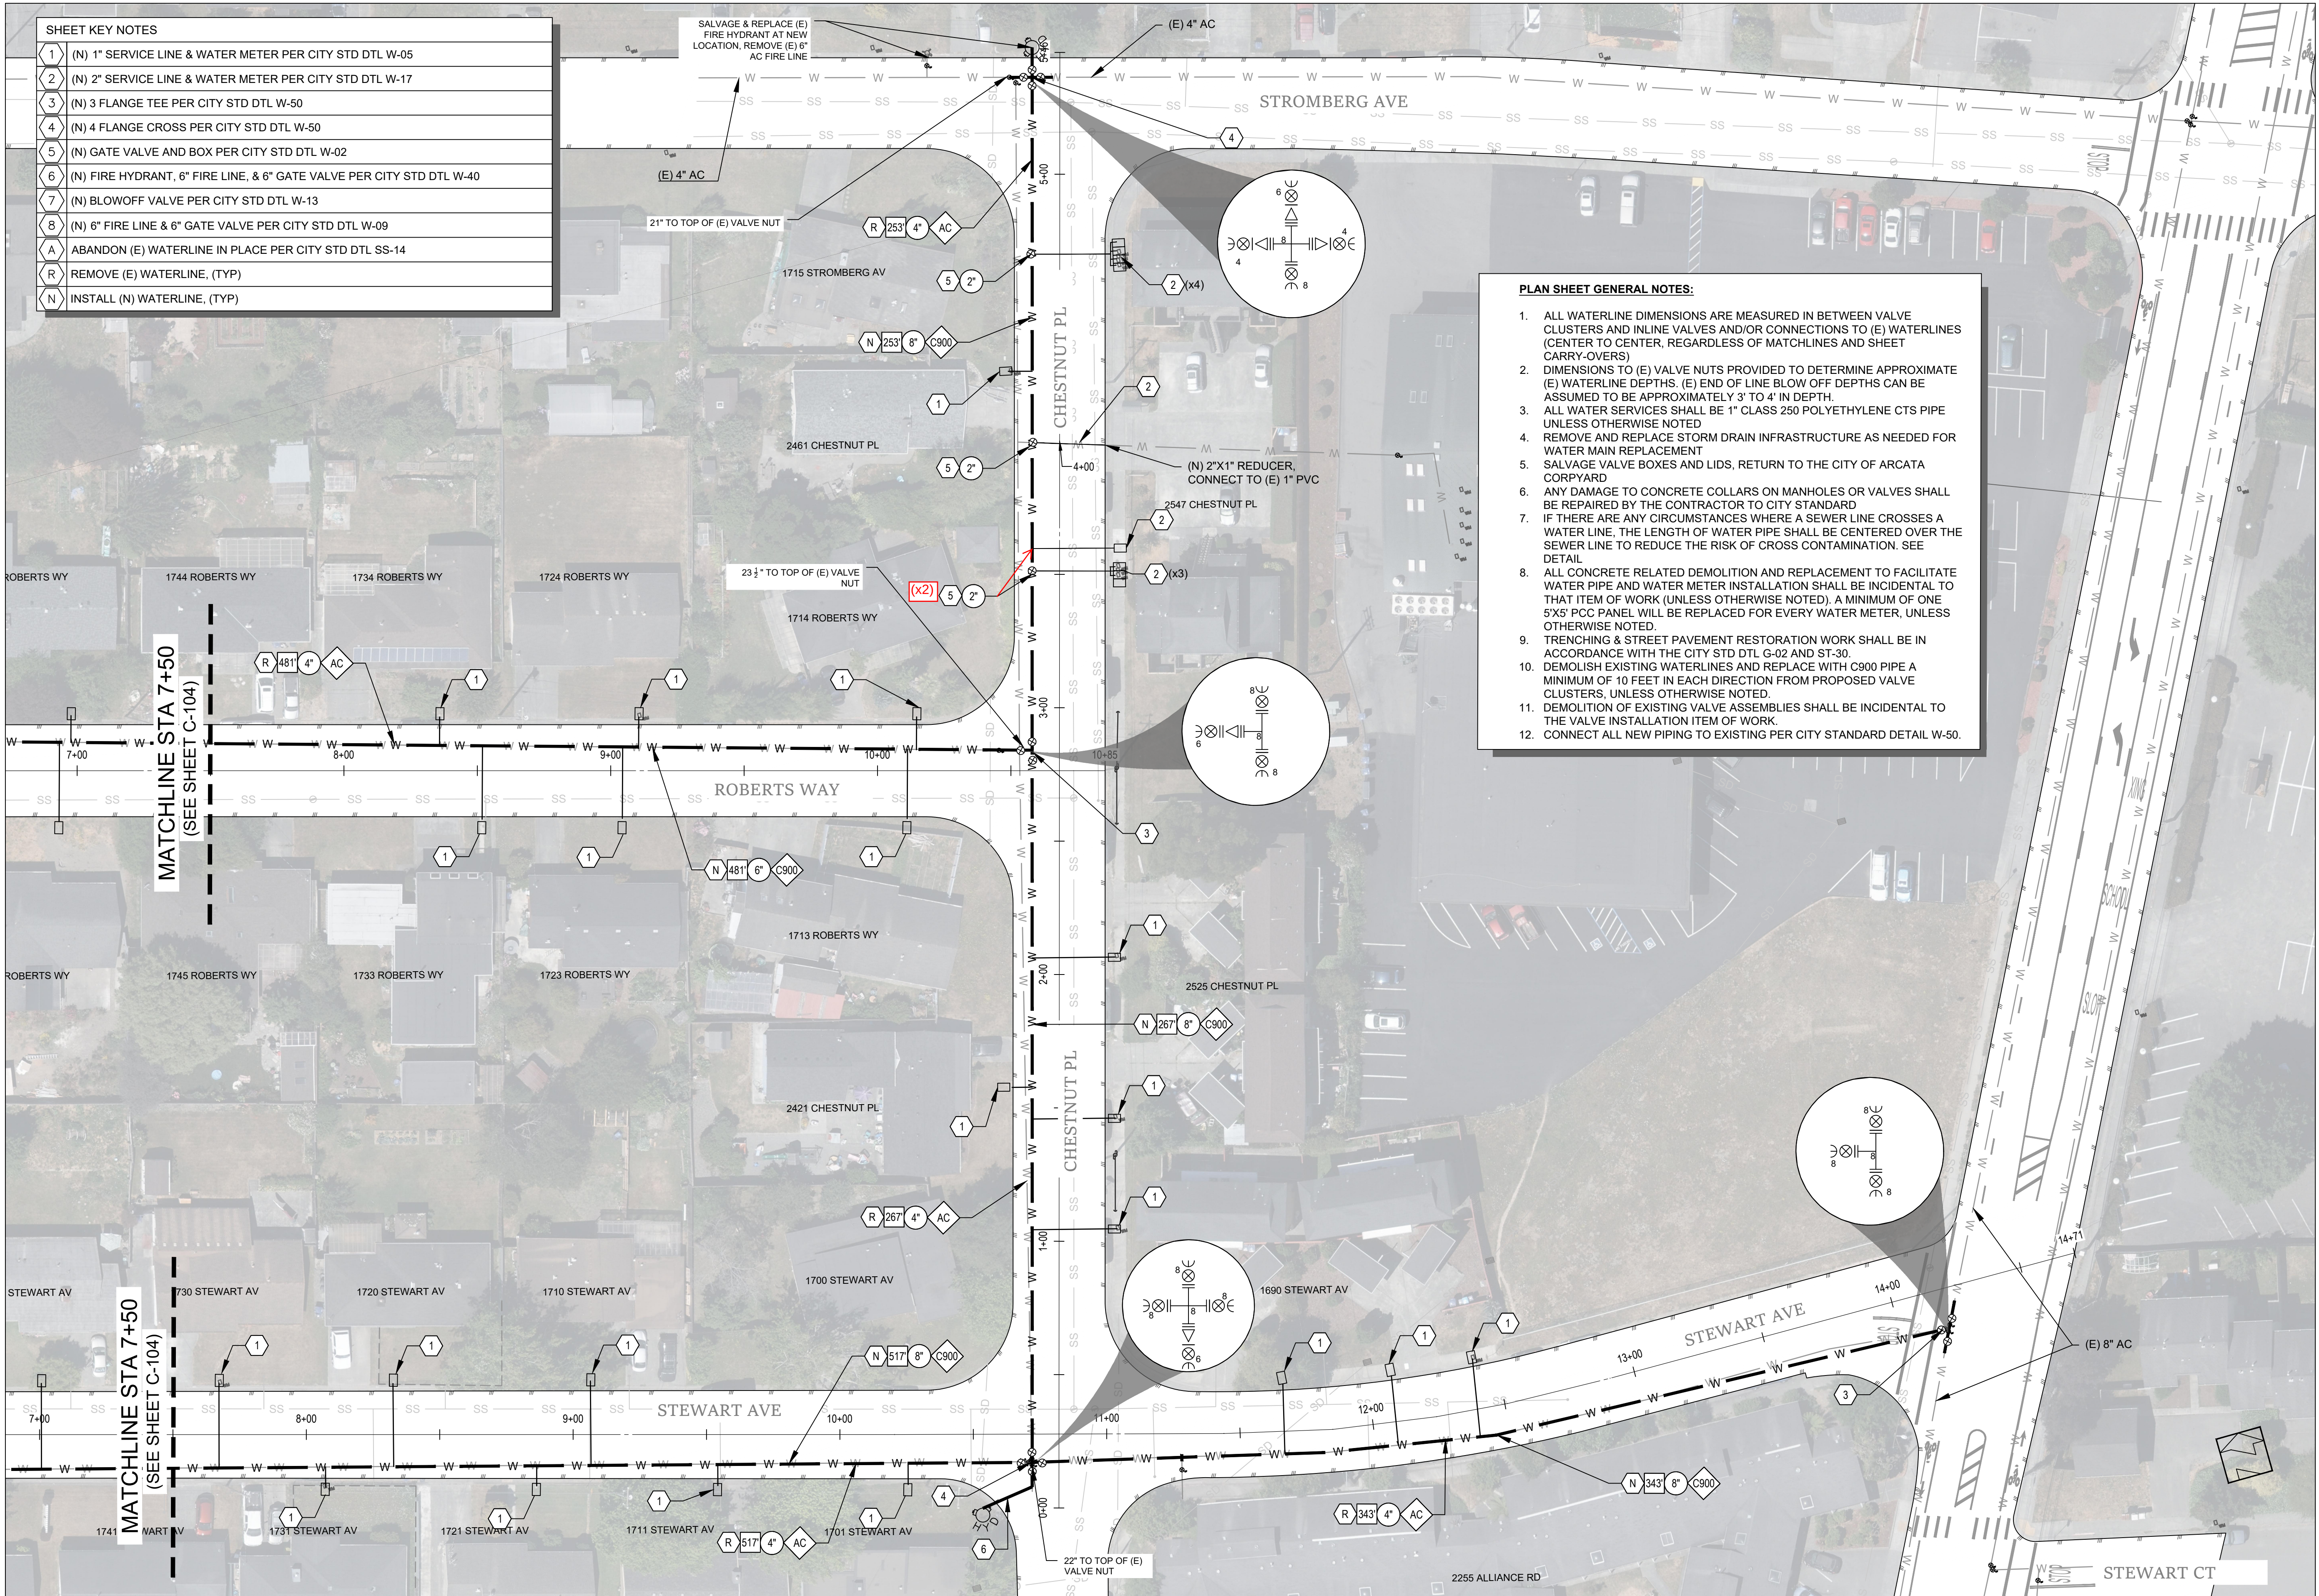


ROBERTS WAY - PLAN VIEW
STATION 7+50 TO 10+85

STEWART AVE - PLAN VIEW
STATION 7+50 TO 14+71

CHESTNUT PL - PLAN VIEW
STATION 0+00 TO 5+46

SHEET KEY NOTES	
1	(N) 1" SERVICE LINE & WATER METER PER CITY STD DTL W-05
2	(N) 2" SERVICE LINE & WATER METER PER CITY STD DTL W-17
3	(N) 3 FLANGE TEE PER CITY STD DTL W-50
4	(N) 4 FLANGE CROSS PER CITY STD DTL W-50
5	(N) GATE VALVE AND BOX PER CITY STD DTL W-02
6	(N) FIRE HYDRANT, 6" FIRE LINE, & 6" GATE VALVE PER CITY STD DTL W-40
7	(N) BLOWOFF VALVE PER CITY STD DTL W-13
8	(N) 6" FIRE LINE & 6" GATE VALVE PER CITY STD DTL W-09
A	ABANDON (E) WATERLINE IN PLACE PER CITY STD DTL SS-14
R	REMOVE (E) WATERLINE, (TYP)
N	INSTALL (N) WATERLINE, (TYP)



- PLAN SHEET GENERAL NOTES:**
- ALL WATERLINE DIMENSIONS ARE MEASURED IN BETWEEN VALVE CLUSTERS AND INLINE VALVES AND/OR CONNECTIONS TO (E) WATERLINES (CENTER TO CENTER, REGARDLESS OF MATCHLINES AND SHEET CARRY-OVERS)
 - DIMENSIONS TO (E) VALVE NUTS PROVIDED TO DETERMINE APPROXIMATE (E) WATERLINE DEPTHS. (E) END OF LINE BLOW OFF DEPTHS CAN BE ASSUMED TO BE APPROXIMATELY 3' TO 4' IN DEPTH.
 - ALL WATER SERVICES SHALL BE 1" CLASS 250 POLYETHYLENE CTS PIPE UNLESS OTHERWISE NOTED
 - REMOVE AND REPLACE STORM DRAIN INFRASTRUCTURE AS NEEDED FOR WATER MAIN REPLACEMENT
 - SALVAGE VALVE BOXES AND LIDS, RETURN TO THE CITY OF ARCATA CORP YARD
 - ANY DAMAGE TO CONCRETE COLLARS ON MANHOLES OR VALVES SHALL BE REPAIRED BY THE CONTRACTOR TO CITY STANDARD
 - IF THERE ARE ANY CIRCUMSTANCES WHERE A SEWER LINE CROSSES A WATER LINE, THE LENGTH OF WATER PIPE SHALL BE CENTERED OVER THE SEWER LINE TO REDUCE THE RISK OF CROSS CONTAMINATION. SEE DETAIL
 - ALL CONCRETE RELATED DEMOLITION AND REPLACEMENT TO FACILITATE WATER PIPE AND WATER METER INSTALLATION SHALL BE INCIDENTAL TO THAT ITEM OF WORK (UNLESS OTHERWISE NOTED), A MINIMUM OF ONE 5'X5' PCC PANEL WILL BE REPLACED FOR EVERY WATER METER, UNLESS OTHERWISE NOTED.
 - TRENCHING & STREET PAVEMENT RESTORATION WORK SHALL BE IN ACCORDANCE WITH THE CITY STD DTL G-02 AND ST-30.
 - DEMOLISH EXISTING WATERLINES AND REPLACE WITH C900 PIPE A MINIMUM OF 10 FEET IN EACH DIRECTION FROM PROPOSED VALVE CLUSTERS, UNLESS OTHERWISE NOTED.
 - DEMOLITION OF EXISTING VALVE ASSEMBLIES SHALL BE INCIDENTAL TO THE VALVE INSTALLATION ITEM OF WORK.
 - CONNECT ALL NEW PIPING TO EXISTING PER CITY STANDARD DETAIL W-50.

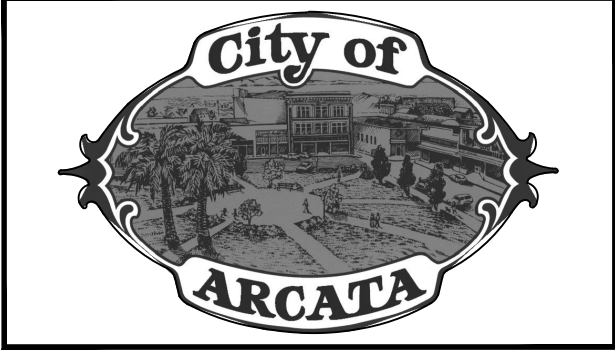

Sheet Title	ROBERTS WAY, STEWART AVE, & CHESTNUT PL
	STEEL WATERLINE REPLACEMENT PROJECT
Project Name	

Project Address	
VARIOUS LOCATIONS	
Designed By	JONATHAN A. KIRCHUBEL
Drawn By	JONATHAN A. KIRCHUBEL
Checked By	DAVID CAISSE
Approved By	NETRA B. KHATRI

Date	JANUARY 2025	Sheet	C-103
Scale	1"=30'	Page	8

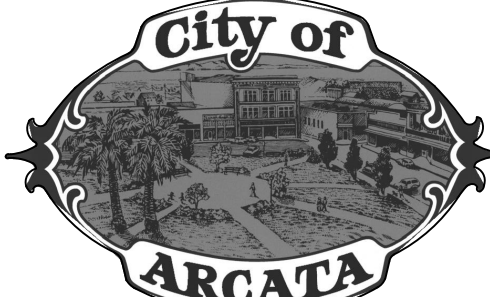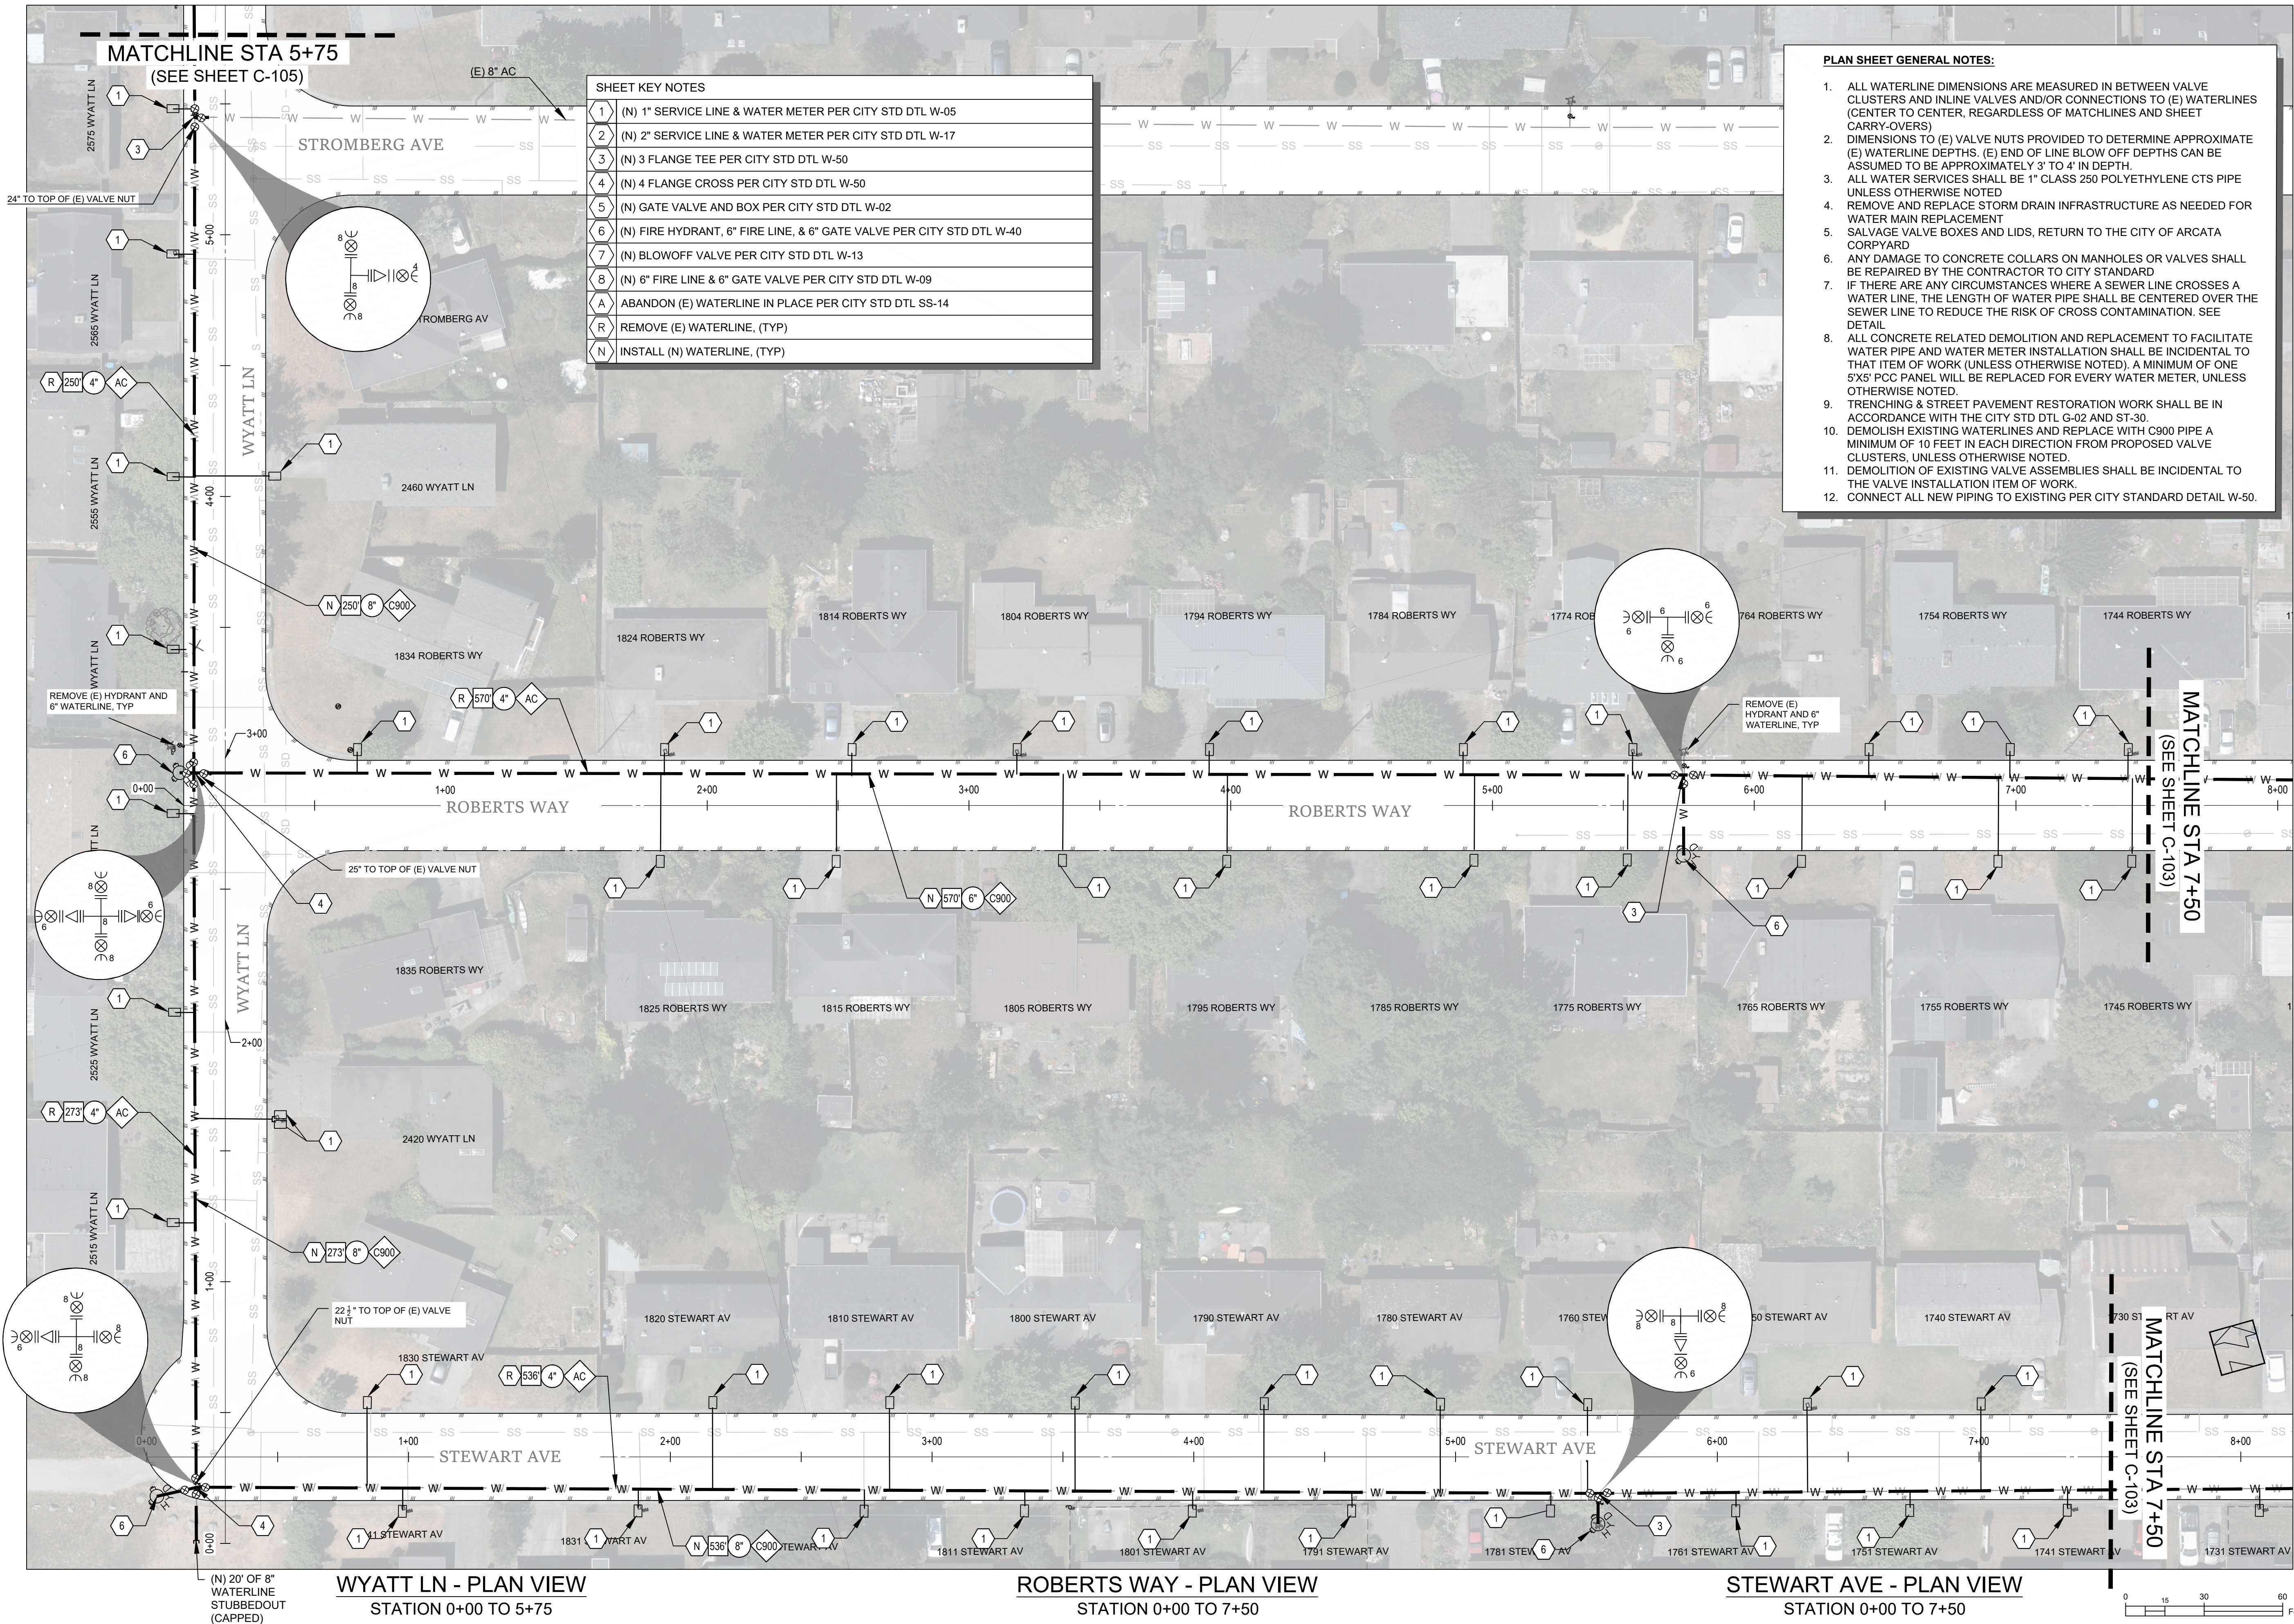

WYATT LN, ROBERTS WAY &
STEWART AVE

STEEL WATERLINE REPLACEMENT PROJECT

VARIOUS LOCATIONS

Designed By
JONATHAN A. KIRCHUBEL

Drawn By
JONATHAN A. KIRCHUBEL

Checked By
DAVID CAISSE




Approved By
NETRA B. KHATRI

Date
JANUARY 2025

Scale
1"=30'

Sheet
C-104

Page
9

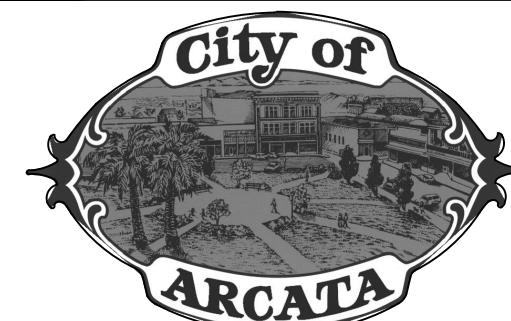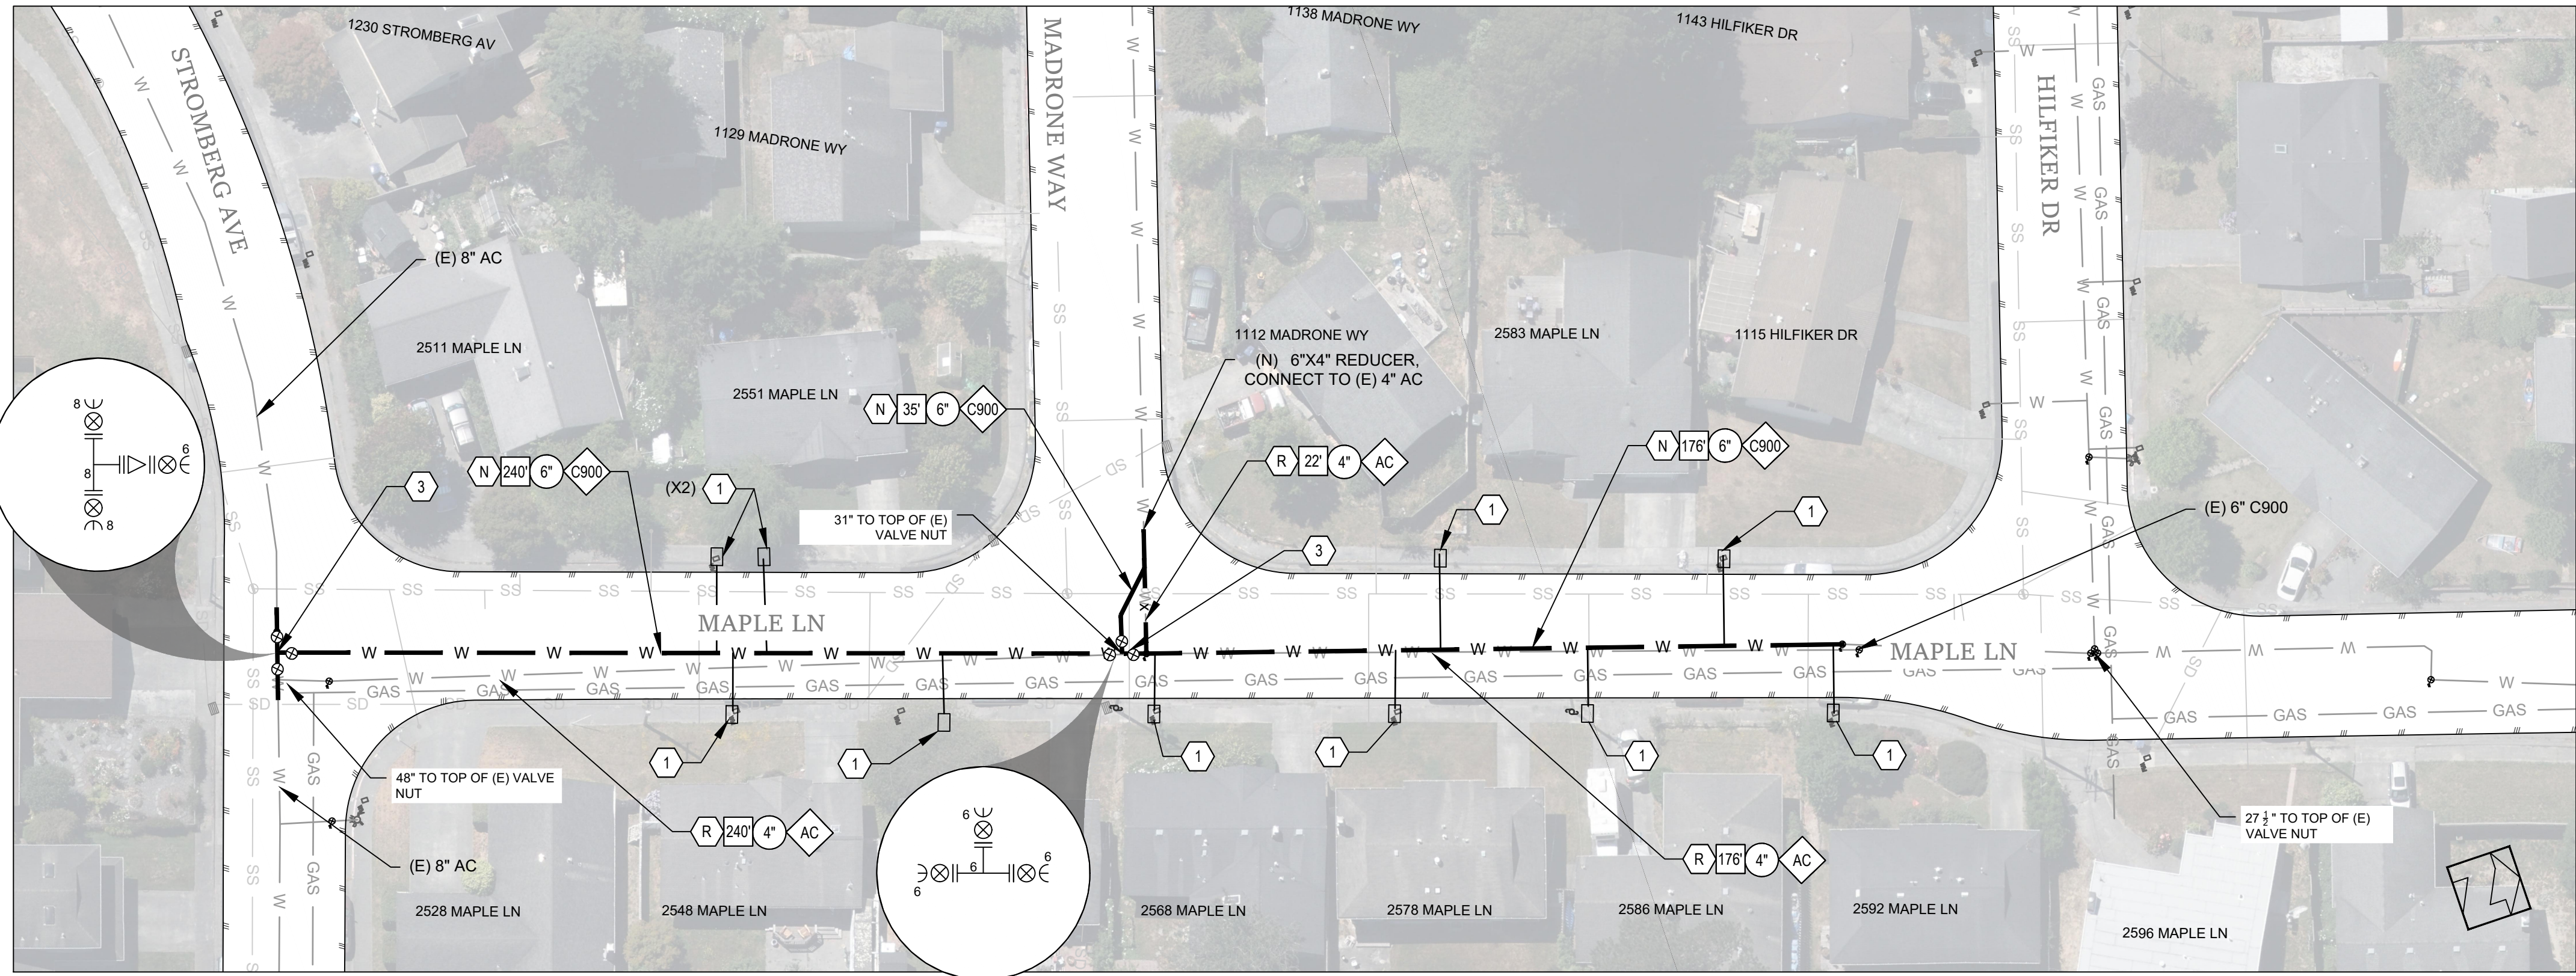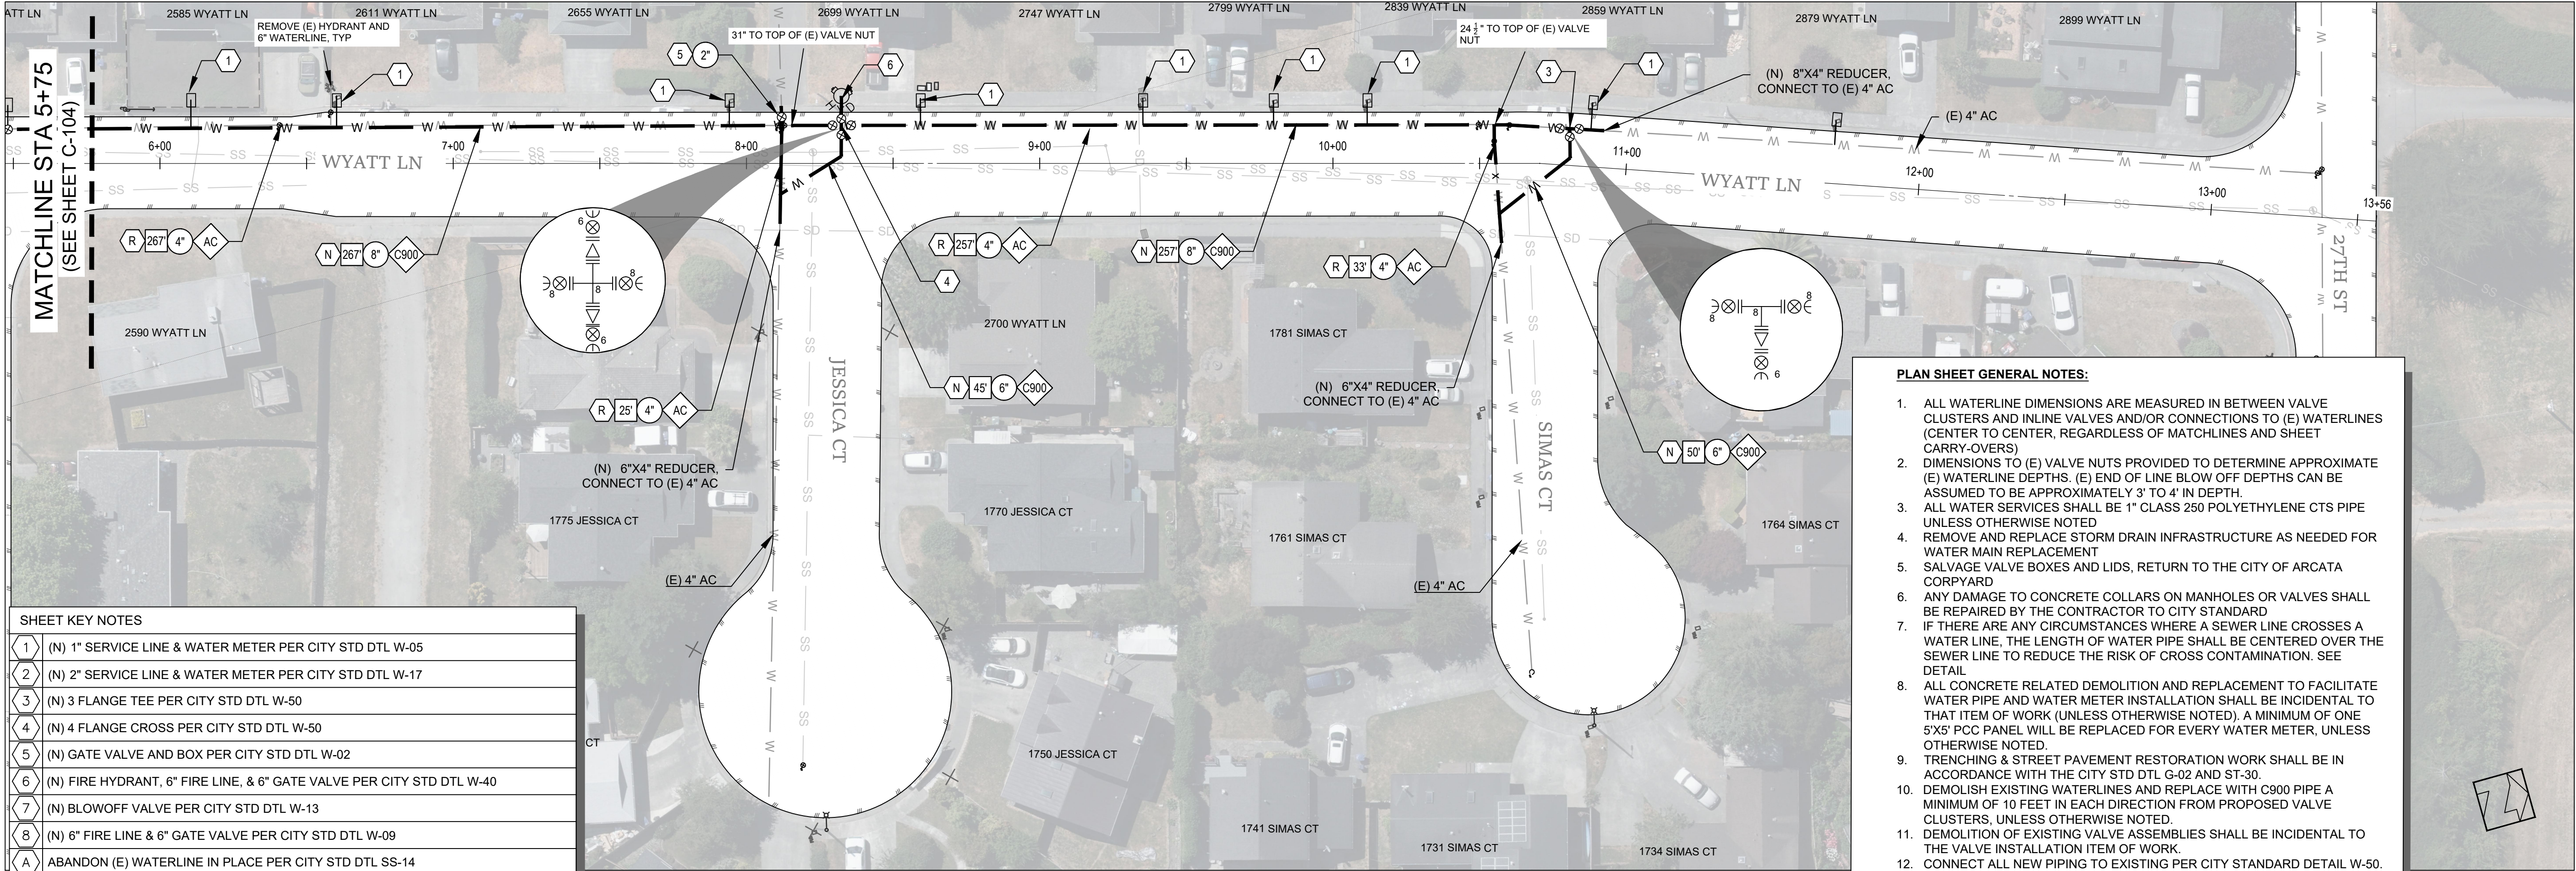



WYATT LN & MAPLE LN

STEEL WATERLINE REPLACEMENT PROJECT

Project Address
VARIOUS LOCATIONS

Designed By
JONATHAN A. KIRCHUBEL
Drawn By
JONATHAN A. KIRCHUBEL
Checked By
DAVID CAISSE
Approved By
NETRA B. KHATRI


Date
JANUARY 2025
Scale
1"=30'
Sheet
C-105
Page
10

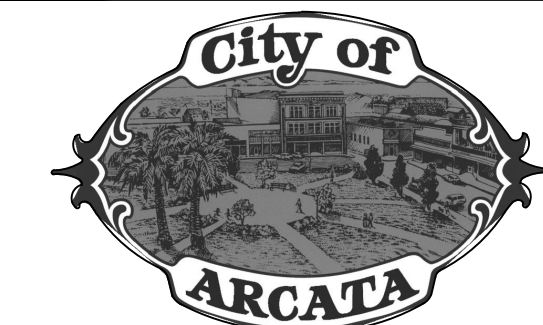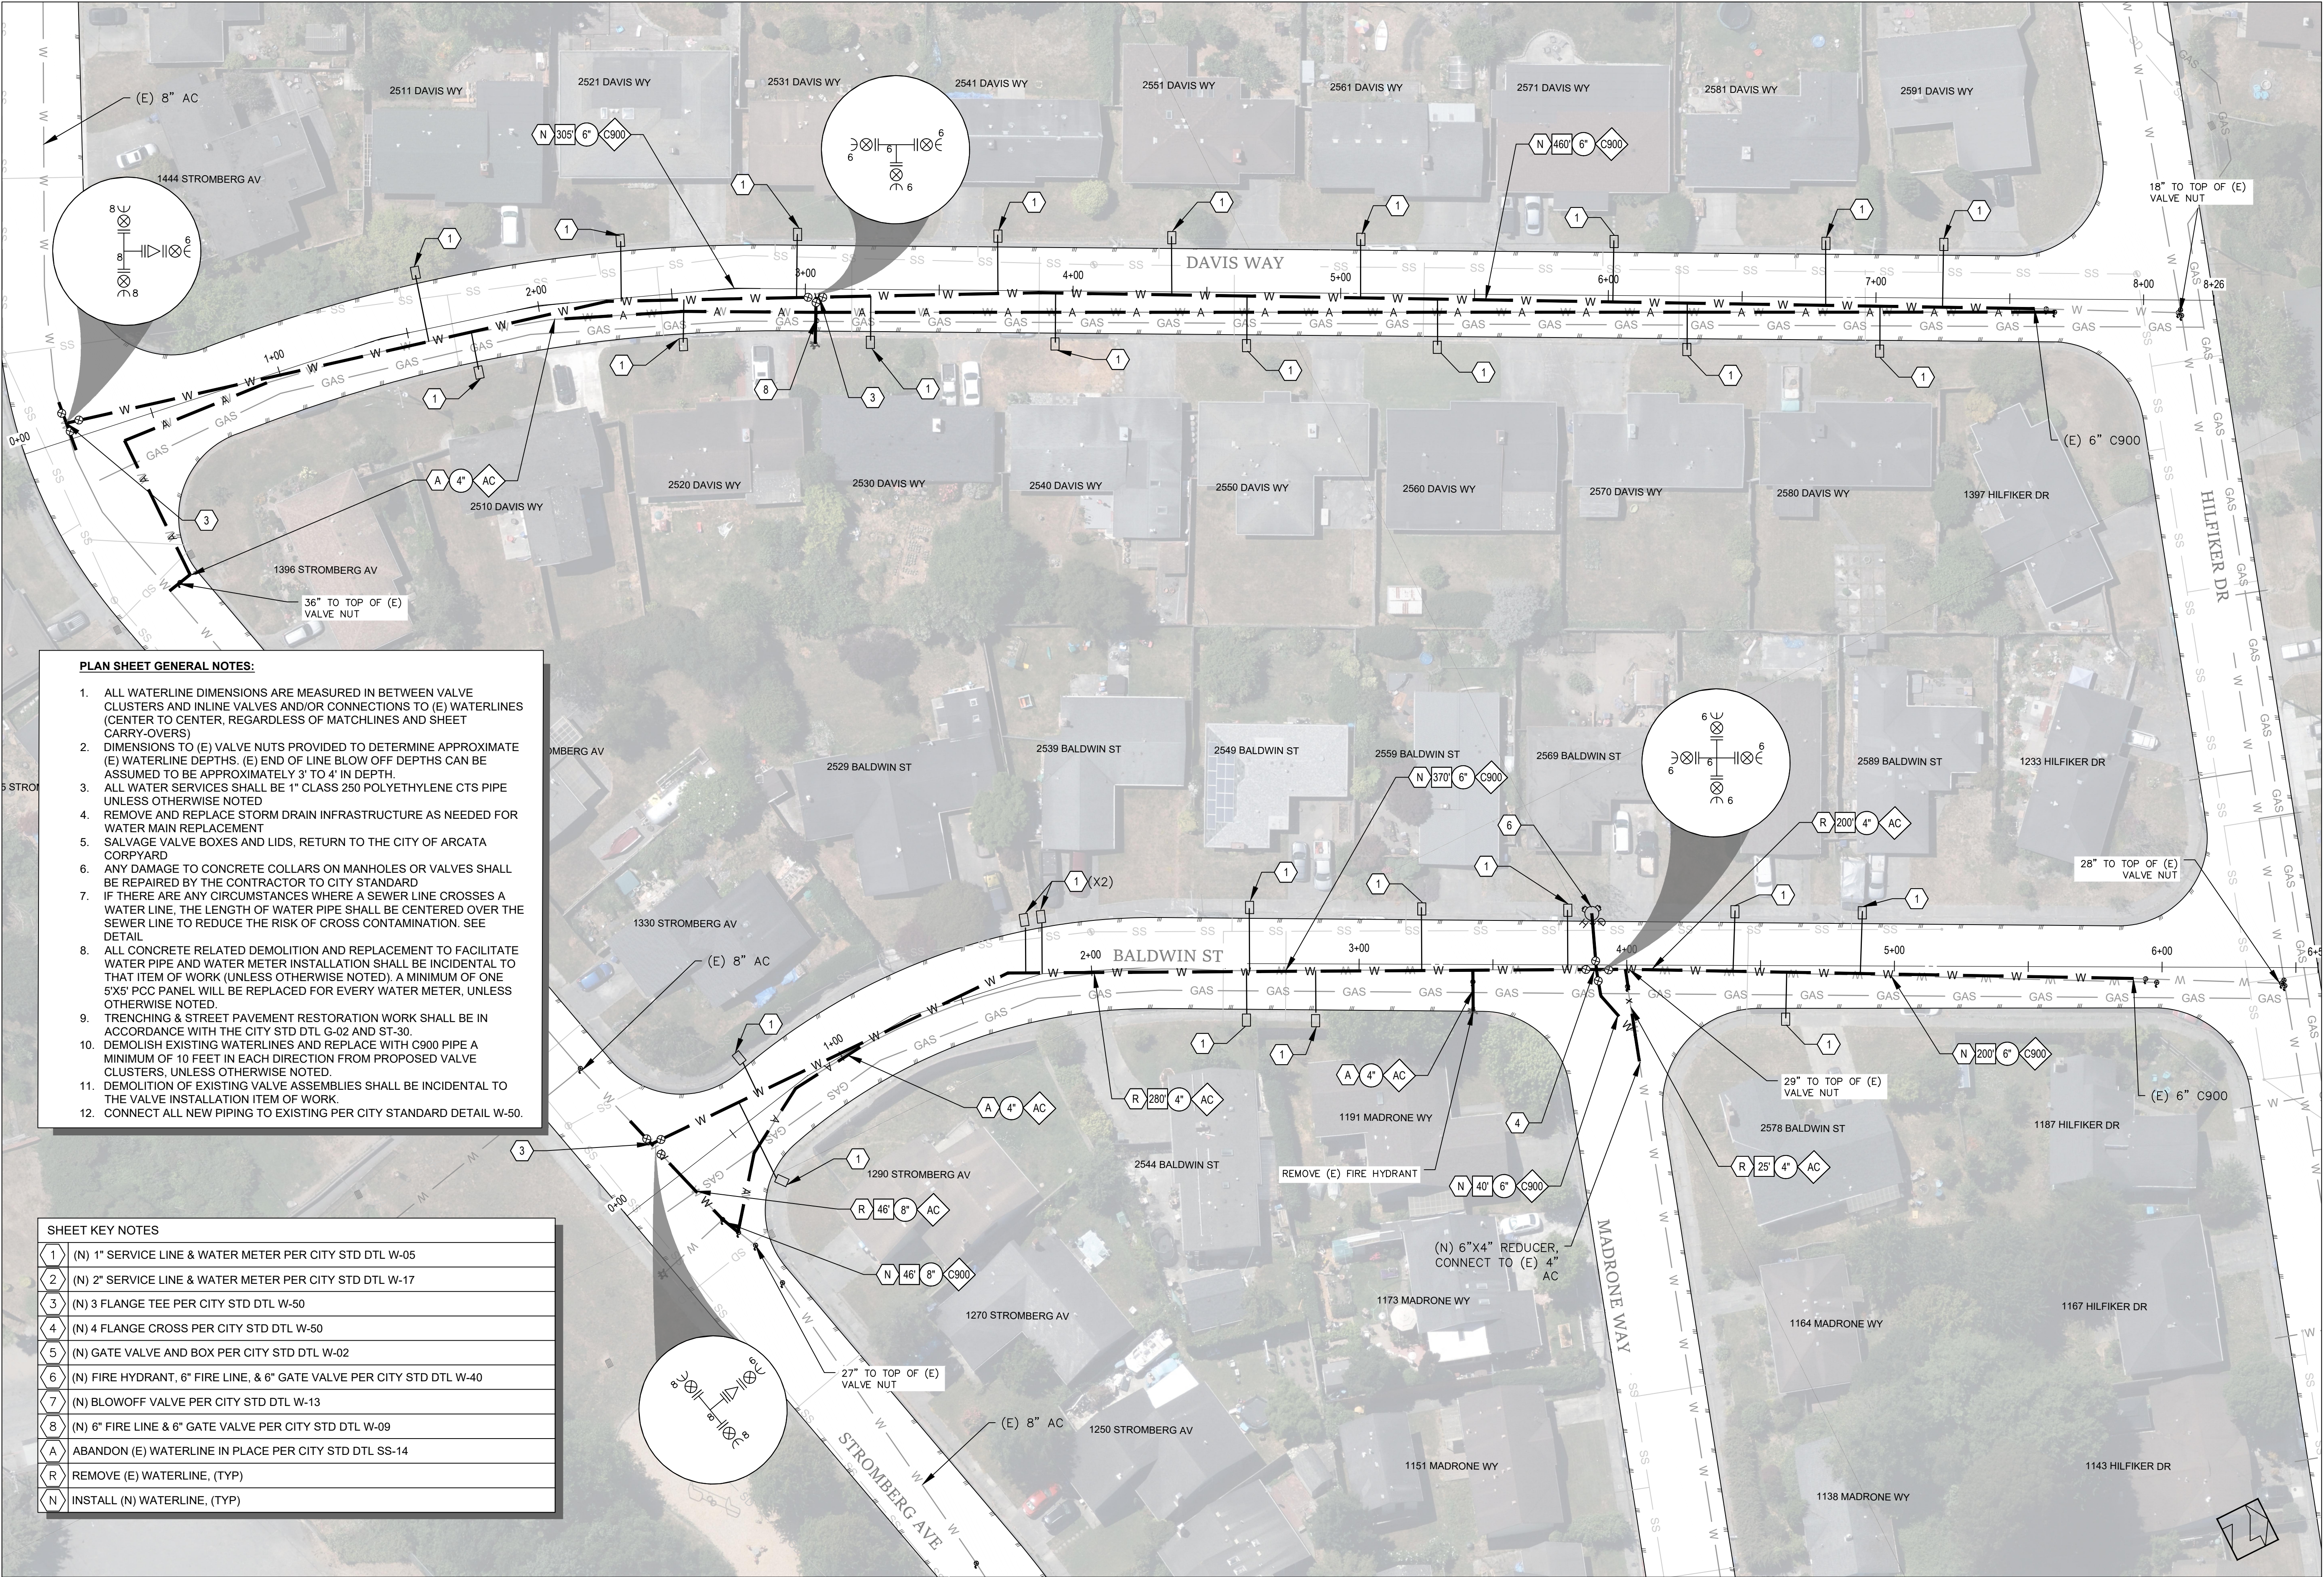

Sheet Title	DAVIS WAY & BALDWIN ST
Project Name	STEEL WATERLINE REPLACEMENT PROJECT



Project Address	VARIOUS LOCATIONS
Designed By	JONATHAN A. KIRCHUBEL
Drawn By	JONATHAN A. KIRCHUBEL
Checked By	DAVID CAISSE
Approved By	NETRA B. KHATRI

Date	JANUARY 2025	Sheet	C-106
Scale	1"=30'	Page	11

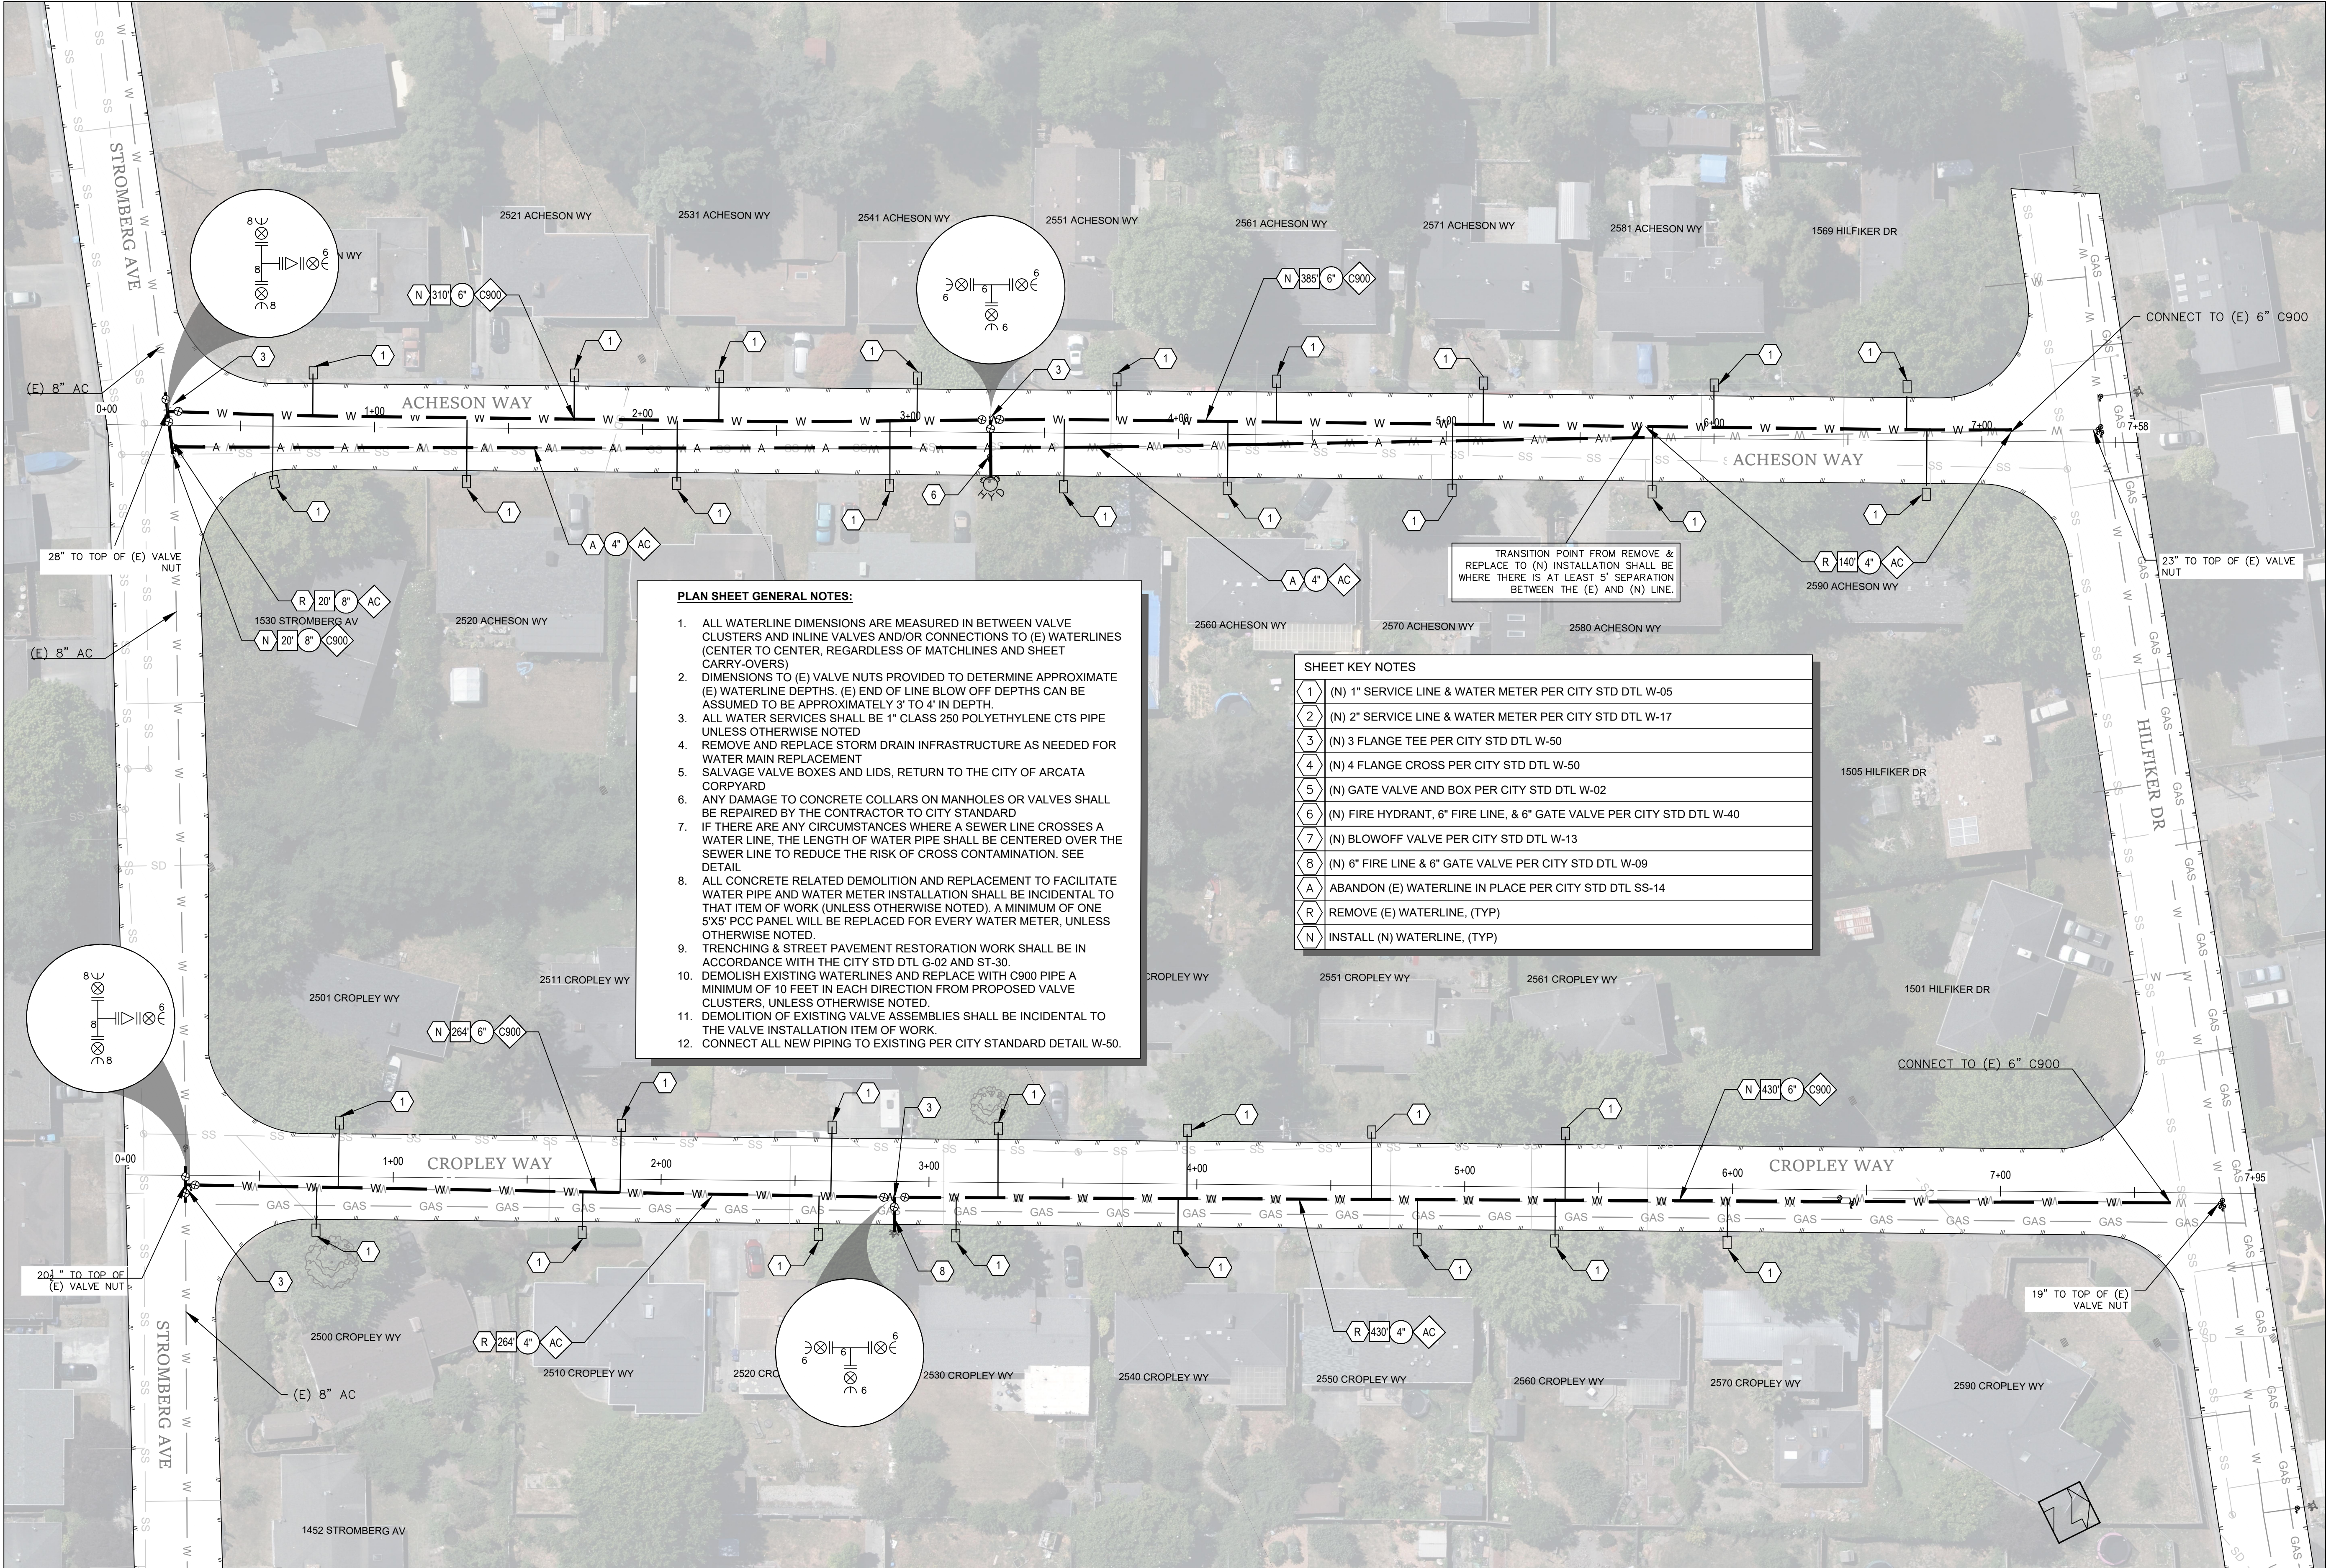

ARCHESON WAY — PLAN VIEW
STATION 0+00 TO 7+58

 CROPLEY WAY — PLAN VIEW
STATION 0+00 TO 7+95

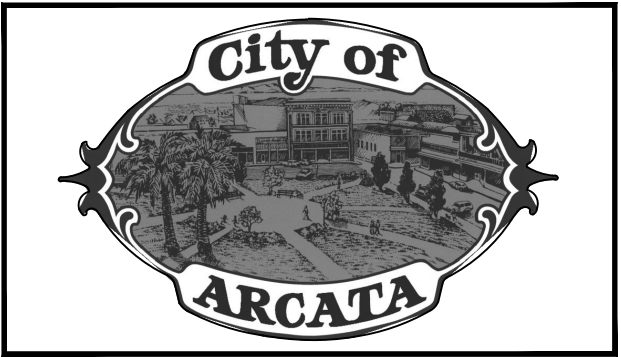

ARCHESON WAY & CROPLEY WAY

STEEL WATERLINE REPLACEMENT PROJECT

Project Name

Project Address

VARIOUS LOCATIONS

Designed By

JONATHAN A. KIRCHUBEL

Drawn By

JONATHAN A. KIRCHUBEL

Checked By

DAVID CAISSE

Approved By

NETRA B. KHATRI

Date

JANUARY 2025

Sheet


C-107

Scale

1"=30'

Page

12


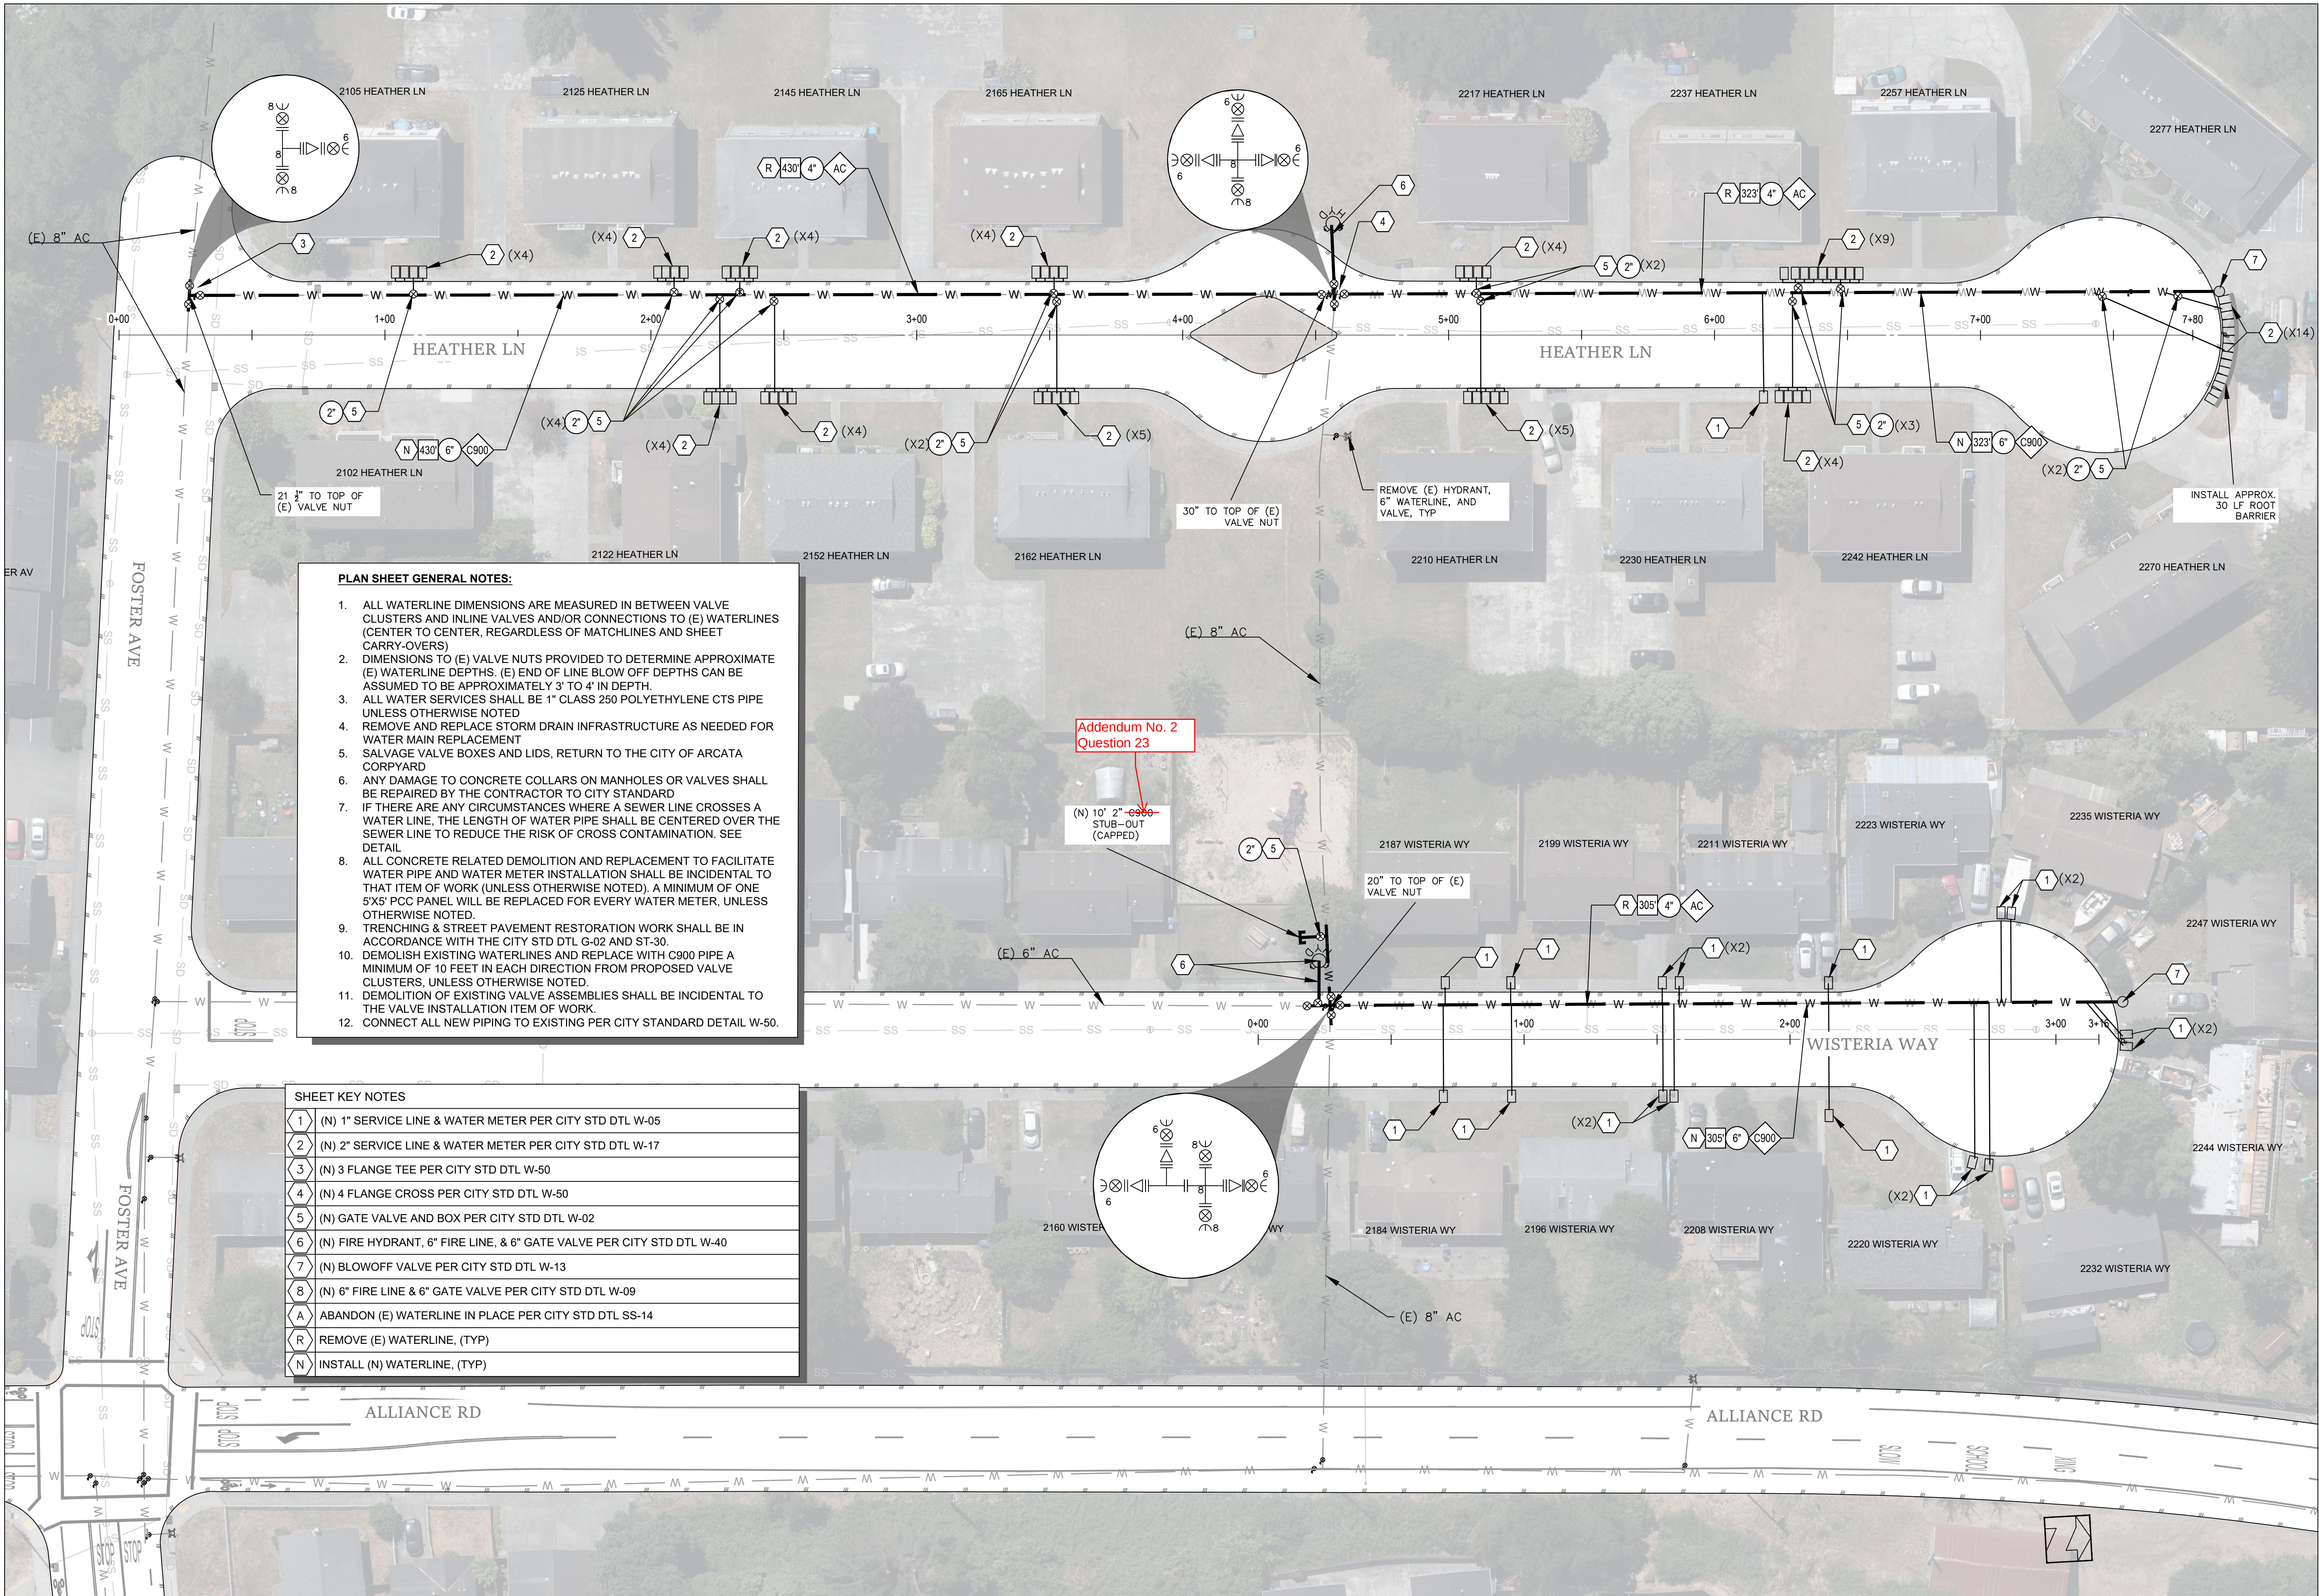


- PLAN SHEET GENERAL NOTES:**
1. ALL WATERLINE DIMENSIONS ARE MEASURED IN BETWEEN VALVE CLUSTERS AND INLINE VALVES AND/OR CONNECTIONS TO (E) WATERLINES (CENTER TO CENTER, REGARDLESS OF MATCHLINES AND SHEET CARRY-OVERS)
 2. DIMENSIONS TO (E) VALVE NUTS PROVIDED TO DETERMINE APPROXIMATE (E) WATERLINE DEPTHS. (E) END OF LINE BLOW OFF DEPTHS CAN BE ASSUMED TO BE APPROXIMATELY 3' TO 4' IN DEPTH.
 3. ALL WATER SERVICES SHALL BE 1" CLASS 250 POLYETHYLENE CTS PIPE UNLESS OTHERWISE NOTED
 4. REMOVE AND REPLACE STORM DRAIN INFRASTRUCTURE AS NEEDED FOR WATER MAIN REPLACEMENT
 5. SALVAGE VALVE BOXES AND LIDS, RETURN TO THE CITY OF ARCATA CORPYARD
 6. ANY DAMAGE TO CONCRETE COLLARS ON MANHOLES OR VALVES SHALL BE REPAIRED BY THE CONTRACTOR TO CITY STANDARD
 7. IF THERE ARE ANY CIRCUMSTANCES WHERE A SEWER LINE CROSSSES A WATER LINE, THE LENGTH OF WATER PIPE SHALL BE CENTERED OVER THE SEWER LINE TO REDUCE THE RISK OF CROSS CONTAMINATION. SEE DETAIL
 8. ALL CONCRETE RELATED DEMOLITION AND REPLACEMENT TO FACILITATE WATER PIPE AND WATER METER INSTALLATION SHALL BE INCIDENTAL TO THAT ITEM OF WORK (UNLESS OTHERWISE NOTED). A MINIMUM OF ONE 5'X5' PCC PANEL WILL BE REPLACED FOR EVERY WATER METER, UNLESS OTHERWISE NOTED.
 9. TRENCHING & STREET PAVEMENT RESTORATION WORK SHALL BE IN ACCORDANCE WITH THE CITY STD DTL G-02 AND ST-30.
 10. DEMOLISH EXISTING WATERLINES AND REPLACE WITH C900 PIPE A MINIMUM OF 10 FEET IN EACH DIRECTION FROM PROPOSED VALVE CLUSTERS, UNLESS OTHERWISE NOTED.
 11. DEMOLITION OF EXISTING VALVE ASSEMBLIES SHALL BE INCIDENTAL TO THE VALVE INSTALLATION ITEM OF WORK.
 12. CONNECT ALL NEW PIPING TO EXISTING PER CITY STANDARD DETAIL W-50.

SHEET KEY NOTES	
1	(N) 1" SERVICE LINE & WATER METER PER CITY STD DTL W-05
2	(N) 2" SERVICE LINE & WATER METER PER CITY STD DTL W-17
3	(N) 3 FLANGE TEE PER CITY STD DTL W-50
4	(N) 4 FLANGE CROSS PER CITY STD DTL W-50
5	(N) GATE VALVE AND BOX PER CITY STD DTL W-02
6	(N) FIRE HYDRANT, 6" FIRE LINE, & 6" GATE VALVE PER CITY STD DTL W-40
7	(N) BLOWOFF VALVE PER CITY STD DTL W-13
8	(N) 6" FIRE LINE & 6" GATE VALVE PER CITY STD DTL W-09
A	ABANDON (E) WATERLINE IN PLACE PER CITY STD DTL SS-14
R	REMOVE (E) WATERLINE, (TYP)
N	INSTALL (N) WATERLINE, (TYP)

HEATHER LN – PLAN VIEW
STATION 0+00 TO 7+80

 WISTERIA WAY – PLAN VIEW
STATION 0+00 TO 3+16

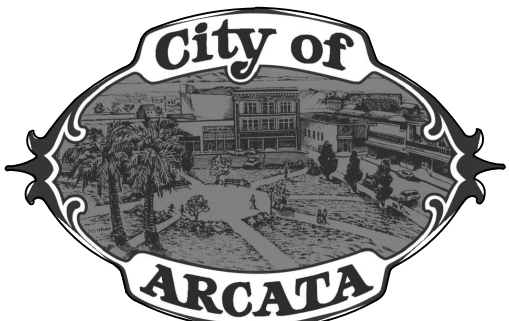


HEATHER LN & WISTERIA WAY

STEEL WATERLINE REPLACEMENT PROJECT


Project Address
VARIOUS LOCATIONS

Designed By
JONATHAN A. KIRCHUBEL
Drawn By
JONATHAN A. KIRCHUBEL
Checked By
DAVID CAISSE
Approved By
NETRA B. KHATRI

Date JANUARY 2025	Sheet C-108
Scale 1"=30'	Page 13

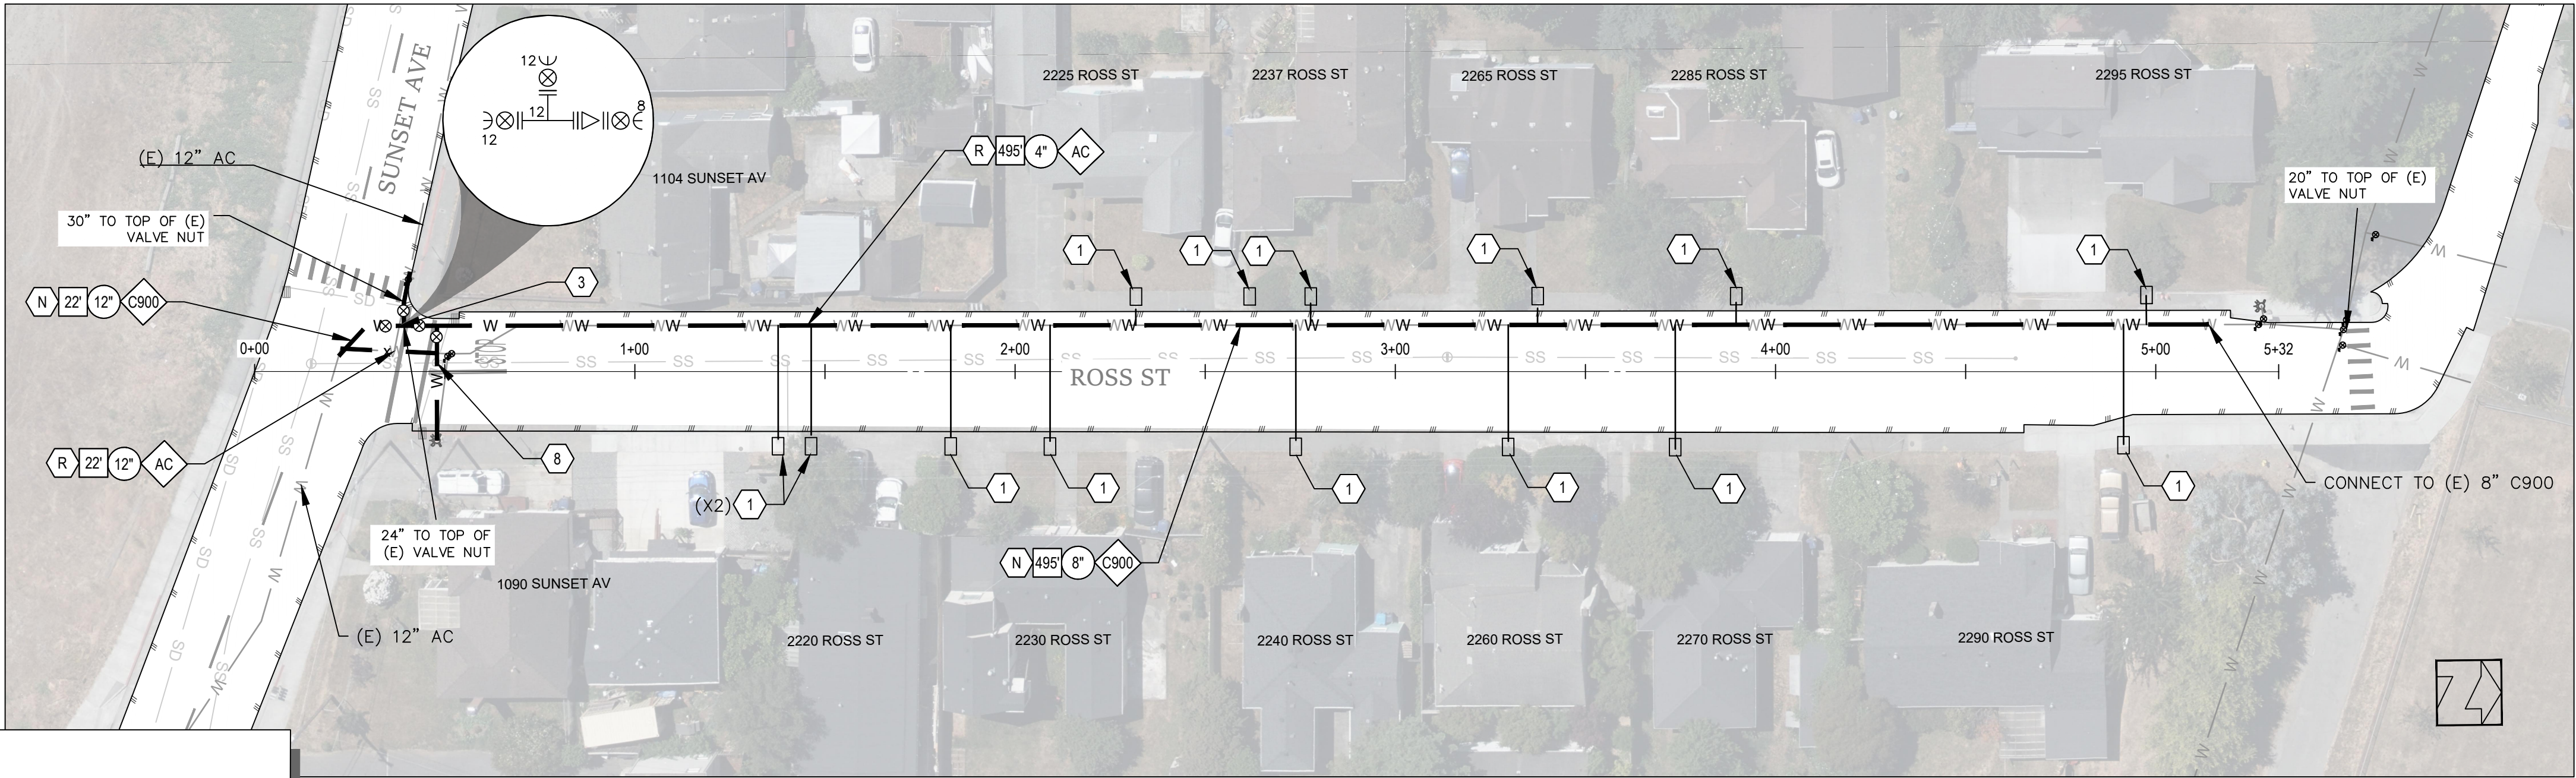

 ROSS ST – PLAN VIEW
STATION 0+00 TO 5+32




PLAN SHEET GENERAL NOTES:



1. ALL WATERLINE DIMENSIONS ARE MEASURED IN BETWEEN VALVE CLUSTERS AND INLINE VALVES AND/OR CONNECTIONS TO (E) WATERLINES (CENTER TO CENTER, REGARDLESS OF MATCHLINES AND SHEET CARRY-OVERS)
2. DIMENSIONS TO (E) VALVE NUTS PROVIDED TO DETERMINE APPROXIMATE (E) WATERLINE DEPTHS. (E) END OF LINE BLOW OFF DEPTHS CAN BE ASSUMED TO BE APPROXIMATELY 3' TO 4' IN DEPTH.
3. ALL WATER SERVICES SHALL BE 1" CLASS 250 POLYETHYLENE CTS PIPE UNLESS OTHERWISE NOTED
4. REMOVE AND REPLACE STORM DRAIN INFRASTRUCTURE AS NEEDED FOR WATER MAIN REPLACEMENT
5. SALVAGE VALVE BOXES AND LIDS, RETURN TO THE CITY OF ARCATA CORPYARD
6. ANY DAMAGE TO CONCRETE COLLARS ON MANHOLES OR VALVES SHALL BE REPAIRED BY THE CONTRACTOR TO CITY STANDARD
7. IF THERE ARE ANY CIRCUMSTANCES WHERE A SEWER LINE CROSSES A WATER LINE, THE LENGTH OF WATER PIPE SHALL BE CENTERED OVER THE SEWER LINE TO REDUCE THE RISK OF CROSS CONTAMINATION. SEE DETAIL
8. ALL CONCRETE RELATED DEMOLITION AND REPLACEMENT TO FACILITATE WATER PIPE AND WATER METER INSTALLATION SHALL BE INCIDENTAL TO THAT ITEM OF WORK (UNLESS OTHERWISE NOTED). A MINIMUM OF ONE 5'X5' PCC PANEL WILL BE REPLACED FOR EVERY WATER METER, UNLESS OTHERWISE NOTED.
9. TRENCHING & STREET PAVEMENT RESTORATION WORK SHALL BE IN ACCORDANCE WITH THE CITY STD DTL G-02 AND ST-30.
10. DEMOLISH EXISTING WATERLINES AND REPLACE WITH C900 PIPE A MINIMUM OF 10 FEET IN EACH DIRECTION FROM PROPOSED VALVE CLUSTERS, UNLESS OTHERWISE NOTED.
11. DEMOLITION OF EXISTING VALVE ASSEMBLIES SHALL BE INCIDENTAL TO THE VALVE INSTALLATION ITEM OF WORK.
12. CONNECT ALL NEW PIPING TO EXISTING PER CITY STANDARD DETAIL W-50.

SHEET KEY NOTES

- | | |
|---|---|
| 1 | (N) 1" SERVICE LINE & WATER METER PER CITY STD DTL W-05 |
| 2 | (N) 2" SERVICE LINE & WATER METER PER CITY STD DTL W-17 |
| 3 | (N) 3 FLANGE TEE PER CITY STD DTL W-50 |
| 4 | (N) 4 FLANGE CROSS PER CITY STD DTL W-50 |
| 5 | (N) GATE VALVE AND BOX PER CITY STD DTL W-02 |
| 6 | (N) FIRE HYDRANT, 6" FIRE LINE, & 6" GATE VALVE PER CITY STD DTL W-40 |
| 7 | (N) BLOWOFF VALVE PER CITY STD DTL W-13 |
| 8 | (N) 6" FIRE LINE & 6" GATE VALVE PER CITY STD DTL W-09 |
| A | ABANDON (E) WATERLINE IN PLACE PER CITY STD DTL SS-14 |
| R | REMOVE (E) WATERLINE, (TYP) |
| N | INSTALL (N) WATERLINE, (TYP) |

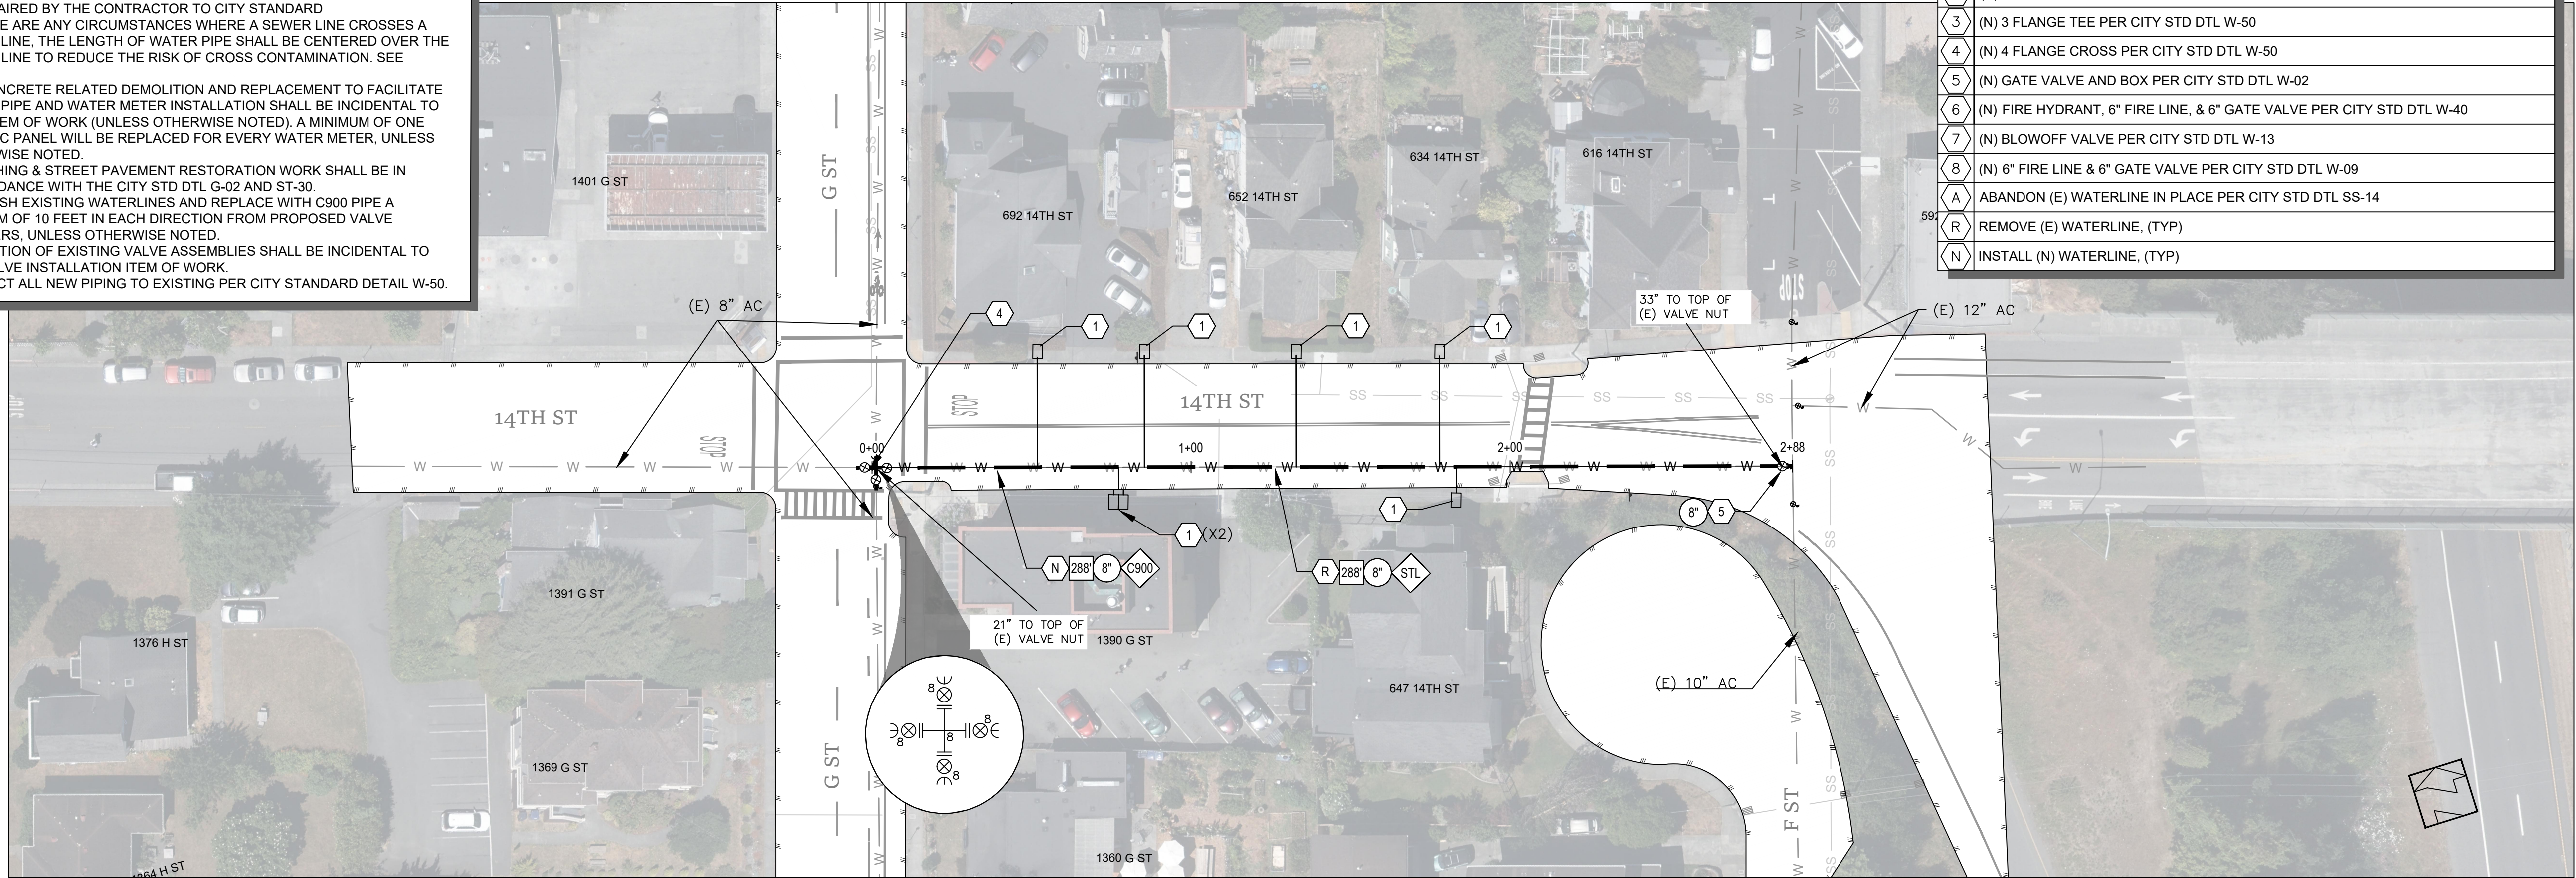

 14TH ST – PLAN VIEW
STATION 0+00 TO 2+88

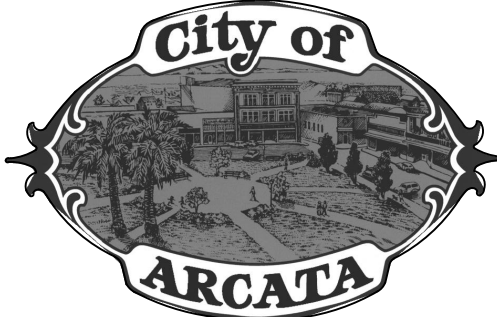

ROSS ST & 14TH ST

STEEL WATERLINE REPLACEMENT PROJECT

Project Address

VARIOUS LOCATIONS

Designed By

JONATHAN A. KIRCHUBEL

Drawn By

JONATHAN A. KIRCHUBEL

Checked By

DAVID CAISSE

Approved By

NETRA B. KHATRI

Date

JANUARY 2025

Sheet


C-109

Scale

1"=30'

Page

14

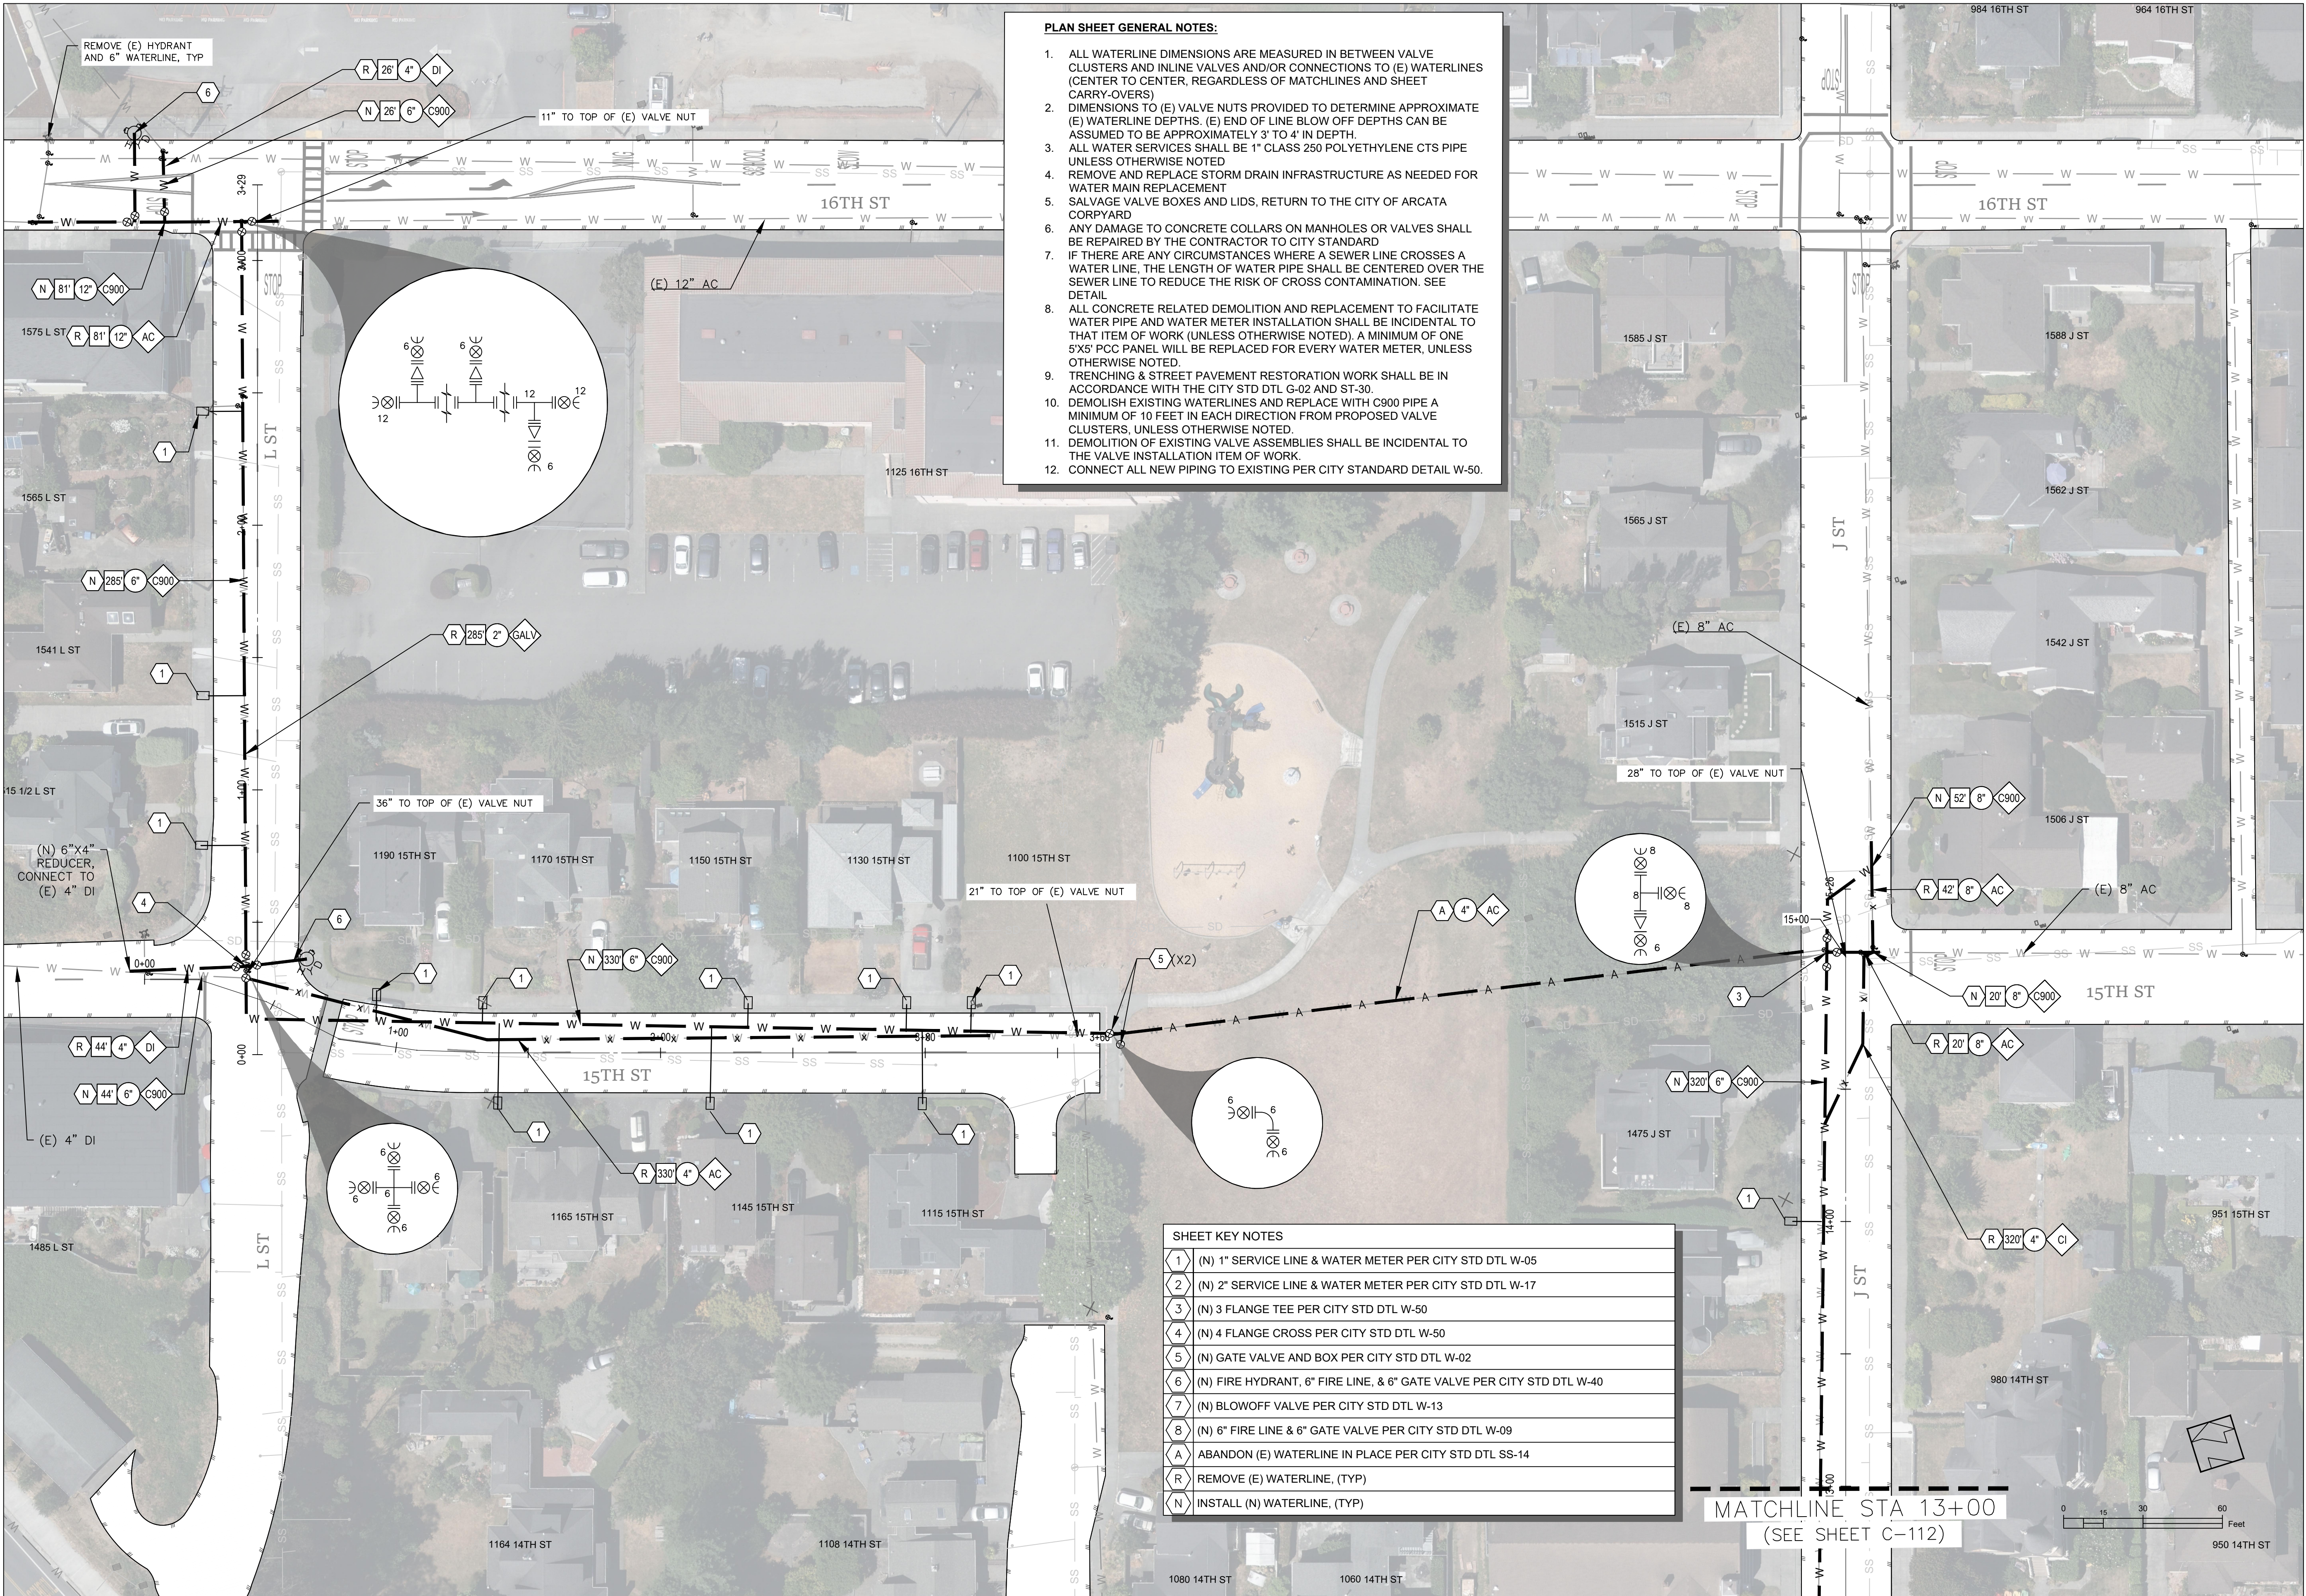

PLAN SHEET GENERAL NOTES:

1. ALL WATERLINE DIMENSIONS ARE MEASURED IN BETWEEN VALVE CLUSTERS AND INLINE VALVES AND/OR CONNECTIONS TO (E) WATERLINES (CENTER TO CENTER, REGARDLESS OF MATCHLINES AND SHEET CARRY-OVERS)
2. DIMENSIONS TO (E) VALVE NUTS PROVIDED TO DETERMINE APPROXIMATE (E) WATERLINE DEPTHS. (E) END OF LINE BLOW OFF DEPTHS CAN BE ASSUMED TO BE APPROXIMATELY 3' TO 4' IN DEPTH.
3. ALL WATER SERVICES SHALL BE 1" CLASS 250 POLYETHYLENE CTS PIPE UNLESS OTHERWISE NOTED
4. REMOVE AND REPLACE STORM DRAIN INFRASTRUCTURE AS NEEDED FOR WATER MAIN REPLACEMENT
5. SALVAGE VALVE BOXES AND LIDS, RETURN TO THE CITY OF ARCATA CORPYARD
6. ANY DAMAGE TO CONCRETE COLLARS ON MANHOLES OR VALVES SHALL BE REPAIRED BY THE CONTRACTOR TO CITY STANDARD
7. IF THERE ARE ANY CIRCUMSTANCES WHERE A SEWER LINE CROSSES A WATER LINE, THE LENGTH OF WATER PIPE SHALL BE CENTERED OVER THE SEWER LINE TO REDUCE THE RISK OF CROSS CONTAMINATION. SEE DETAIL
8. ALL CONCRETE RELATED DEMOLITION AND REPLACEMENT TO FACILITATE WATER PIPE AND WATER METER INSTALLATION SHALL BE INCIDENTAL TO THAT ITEM OF WORK (UNLESS OTHERWISE NOTED). A MINIMUM OF ONE 5'X5' PCC PANEL WILL BE REPLACED FOR EVERY WATER METER, UNLESS OTHERWISE NOTED.
9. TRENCHING & STREET PAVEMENT RESTORATION WORK SHALL BE IN ACCORDANCE WITH THE CITY STD DTL G-02 AND ST-30.
10. DEMOLISH EXISTING WATERLINES AND REPLACE WITH C900 PIPE A MINIMUM OF 10 FEET IN EACH DIRECTION FROM PROPOSED VALVE CLUSTERS, UNLESS OTHERWISE NOTED.
11. DEMOLITION OF EXISTING VALVE ASSEMBLIES SHALL BE INCIDENTAL TO THE VALVE INSTALLATION ITEM OF WORK.
12. CONNECT ALL NEW PIPING TO EXISTING PER CITY STANDARD DETAIL W-50.


SHEET KEY NOTES

- | | |
|---|---|
| 1 | (N) 1" SERVICE LINE & WATER METER PER CITY STD DTL W-05 |
| 2 | (N) 2" SERVICE LINE & WATER METER PER CITY STD DTL W-17 |
| 3 | (N) 3 FLANGE TEE PER CITY STD DTL W-50 |
| 4 | (N) 4 FLANGE CROSS PER CITY STD DTL W-50 |
| 5 | (N) GATE VALVE AND BOX PER CITY STD DTL W-02 |
| 6 | (N) FIRE HYDRANT, 6" FIRE LINE, & 6" GATE VALVE PER CITY STD DTL W-40 |
| 7 | (N) BLOWOFF VALVE PER CITY STD DTL W-13 |
| 8 | (N) 6" FIRE LINE & 6" GATE VALVE PER CITY STD DTL W-09 |
| A | ABANDON (E) WATERLINE IN PLACE PER CITY STD DTL SS-14 |
| R | REMOVE (E) WATERLINE, (TYP) |
| N | INSTALL (N) WATERLINE, (TYP) |

L ST — PLAN VIEW
STATION 0+00 TO 3+29

15TH ST — PLAN VIEW
STATION 0+00 TO 3+66

J ST — PLAN VIEW
STATION 13+00 TO 15+26

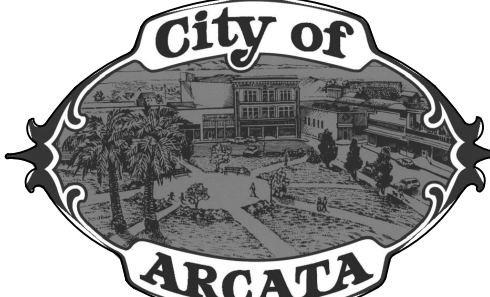

L ST, 16TH ST, 15TH, ST, & J ST

STEEL WATERLINE REPLACEMENT PROJECT

Project Address

VARIOUS LOCATIONS

Designed By

JONATHAN A. KIRCHUBEL

Drawn By

JONATHAN A. KIRCHUBEL

Checked By

DAVID CAISSE

Approved By

NETRA B. KHATRI

Date

JANUARY 2025

Sheet

C-110

Scale

1"=30'


Page

15

SHEET KEY NOTES	
1	(N) 1" SERVICE LINE & WATER METER PER CITY STD DTL W-05
2	(N) 2" SERVICE LINE & WATER METER PER CITY STD DTL W-17
3	(N) 3 FLANGE TEE PER CITY STD DTL W-50
4	(N) 4 FLANGE CROSS PER CITY STD DTL W-50
5	(N) GATE VALVE AND BOX PER CITY STD DTL W-02
6	(N) FIRE HYDRANT, 6" FIRE LINE, & 6" GATE VALVE PER CITY STD DTL W-40
7	(N) BLOWOFF VALVE PER CITY STD DTL W-13
8	(N) 6" FIRE LINE & 6" GATE VALVE PER CITY STD DTL W-09
A	ABANDON (E) WATERLINE IN PLACE PER CITY STD DTL SS-14
R	REMOVE (E) WATERLINE, (TYP)
N	INSTALL (N) WATERLINE, (TYP)



PLAN SHEET GENERAL NOTES:

- ALL WATERLINE DIMENSIONS ARE MEASURED IN BETWEEN VALVE CLUSTERS AND INLINE VALVES AND/OR CONNECTIONS TO (E) WATERLINES (CENTER TO CENTER, REGARDLESS OF MATCHLINES AND SHEET CARRY-OVERS)
- DIMENSIONS TO (E) VALVE NUTS PROVIDED TO DETERMINE APPROXIMATE (E) WATERLINE DEPTHS. (E) END OF LINE BLOW OFF DEPTHS CAN BE ASSUMED TO BE APPROXIMATELY 3' TO 4' IN DEPTH.
- ALL WATER SERVICES SHALL BE 1" CLASS 250 POLYETHYLENE CTS PIPE UNLESS OTHERWISE NOTED
- REMOVE AND REPLACE STORM DRAIN INFRASTRUCTURE AS NEEDED FOR WATER MAIN REPLACEMENT
- SALVAGE VALVE BOXES AND LIDS, RETURN TO THE CITY OF ARCATA CORPYARD
- ANY DAMAGE TO CONCRETE COLLARS ON MANHOLES OR VALVES SHALL BE REPAIRED BY THE CONTRACTOR TO CITY STANDARD
- IF THERE ARE ANY CIRCUMSTANCES WHERE A SEWER LINE CROSSES A WATER LINE, THE LENGTH OF WATER PIPE SHALL BE CENTERED OVER THE SEWER LINE TO REDUCE THE RISK OF CROSS CONTAMINATION. SEE DETAIL
- ALL CONCRETE RELATED DEMOLITION AND REPLACEMENT TO FACILITATE WATER PIPE AND WATER METER INSTALLATION SHALL BE INCIDENTAL TO THAT ITEM OF WORK (UNLESS OTHERWISE NOTED). A MINIMUM OF ONE 5'X5' PCC PANEL WILL BE REPLACED FOR EVERY WATER METER, UNLESS OTHERWISE NOTED.
- TRENCHING & STREET PAVEMENT RESTORATION WORK SHALL BE IN ACCORDANCE WITH THE CITY STD DTL G-02 AND ST-30.
- DEMOLISH EXISTING WATERLINES AND REPLACE WITH C900 PIPE A MINIMUM OF 10 FEET IN EACH DIRECTION FROM PROPOSED VALVE CLUSTERS, UNLESS OTHERWISE NOTED.
- DEMOLITION OF EXISTING VALVE ASSEMBLIES SHALL BE INCIDENTAL TO THE VALVE INSTALLATION ITEM OF WORK.
- CONNECT ALL NEW PIPING TO EXISTING PER CITY STANDARD DETAIL W-50.

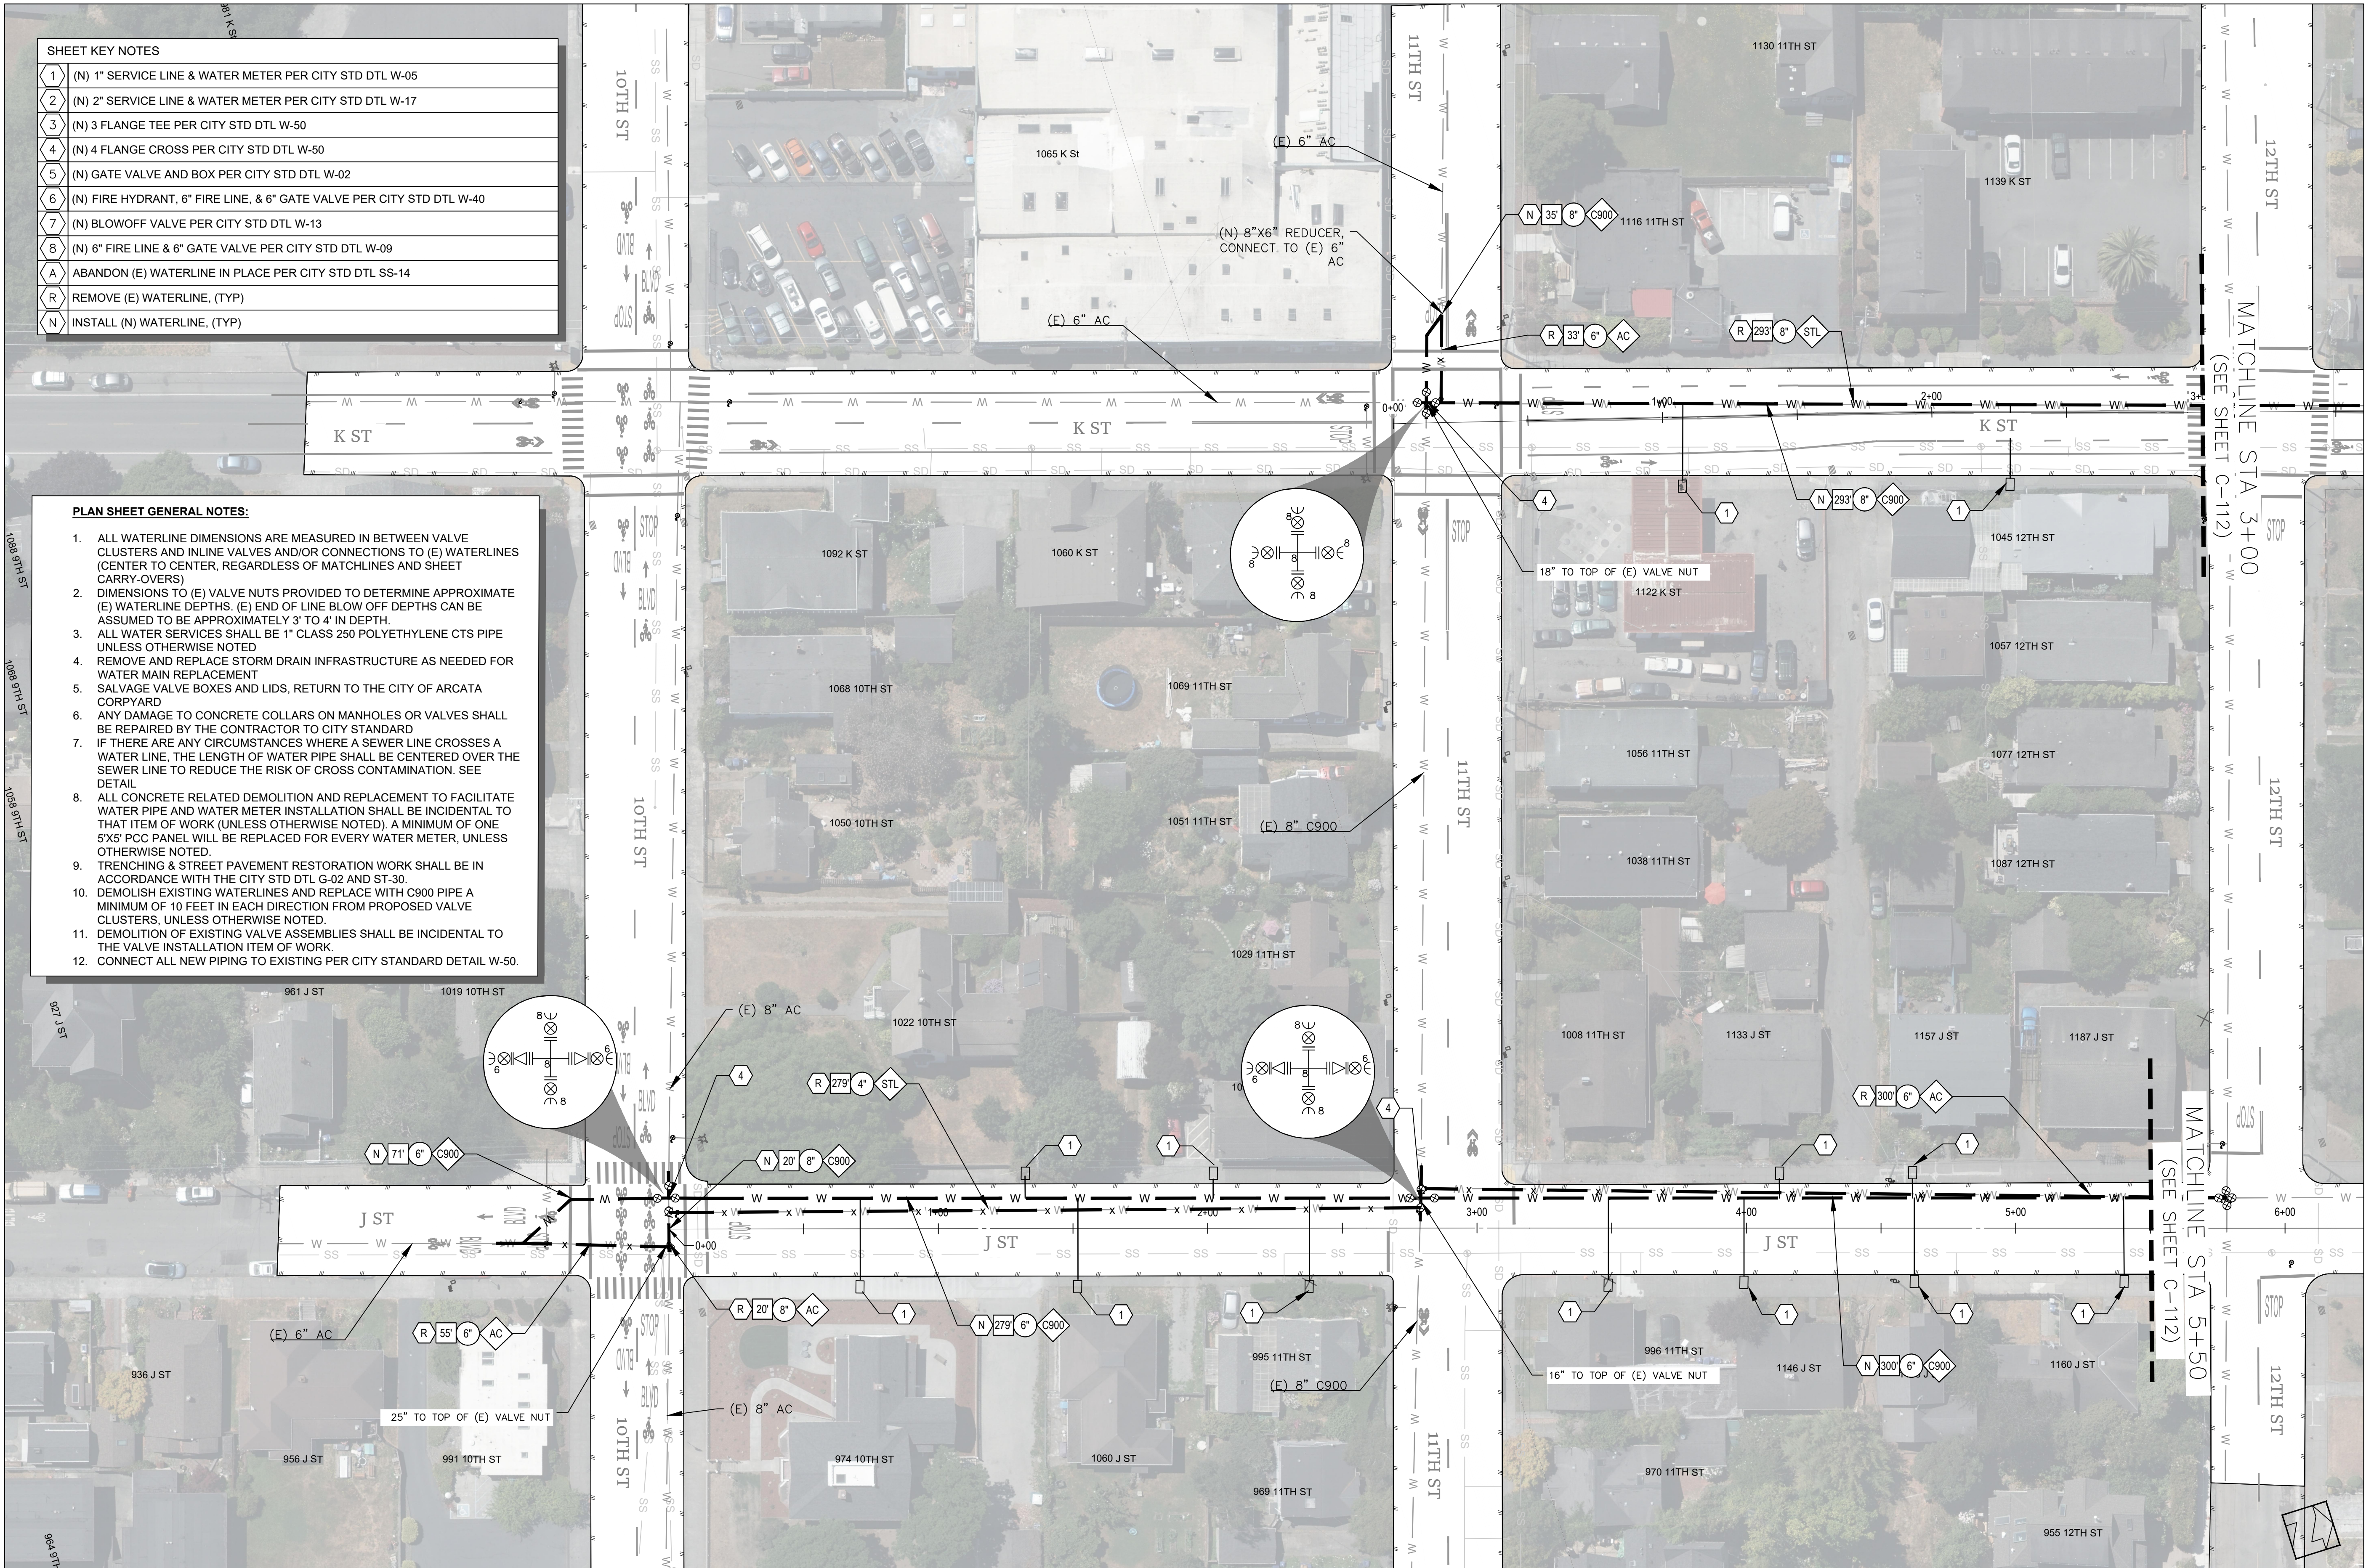

J ST — PLAN VIEW
STATION 0+00 TO 5+50

 K ST — PLAN VIEW
STATION 0+00 TO 3+00

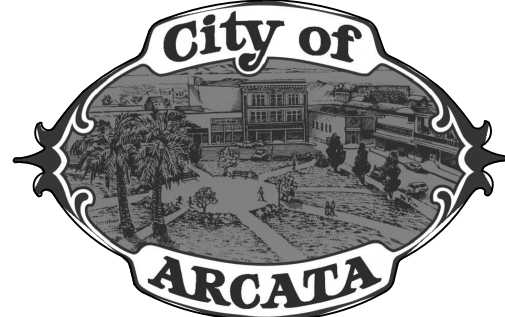

Sheet Title
J & K ST

Project Name
STEEL WATERLINE REPLACEMENT PROJECT

Project Address
VARIOUS LOCATIONS

Designed By
JONATHAN A. KIRCHUBEL

Drawn By
JONATHAN A. KIRCHUBEL

Checked By
DAVID CAISSE


Approved By
NETRA B. KHATRI

Date
JANUARY 2025

Sheet
C-111

Scale
1"=30'

Page
16


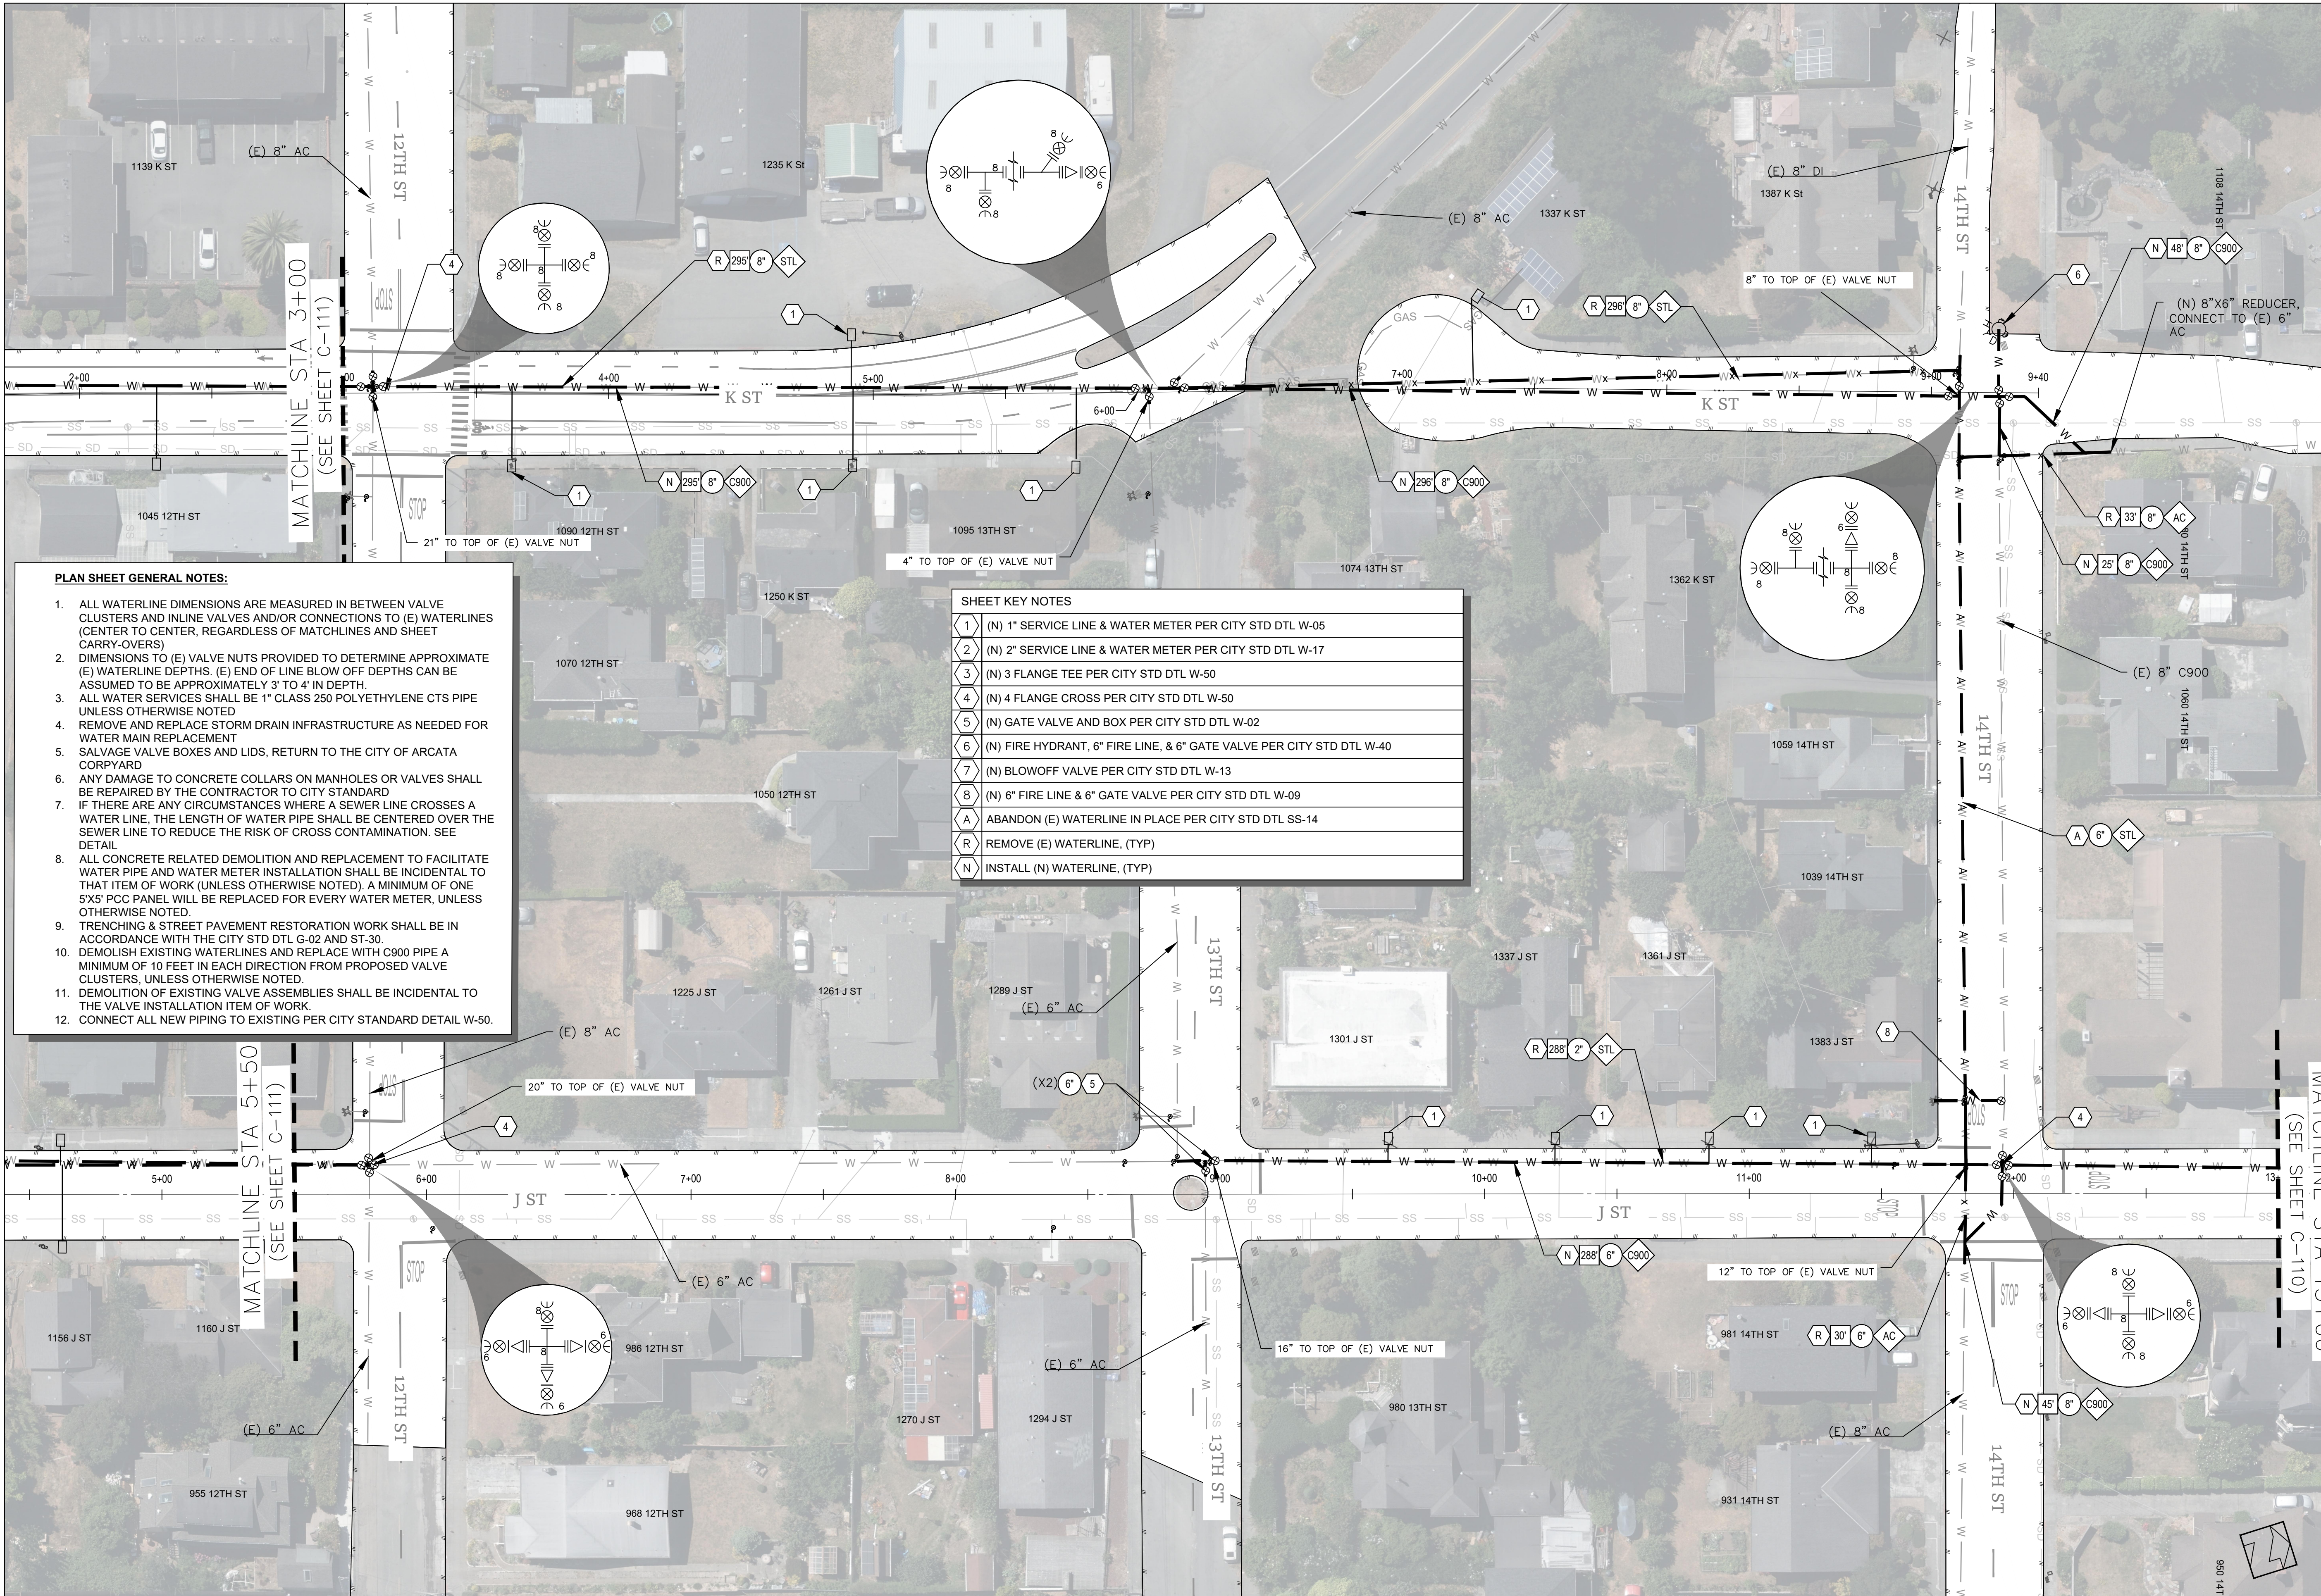


- PLAN SHEET GENERAL NOTES:**
1. ALL WATERLINE DIMENSIONS ARE MEASURED IN BETWEEN VALVE CLUSTERS AND INLINE VALVES OR CONNECTIONS TO (E) WATERLINES (CENTER TO CENTER, REGARDLESS OF MATCHLINES AND SHEET CARRY-OVERS)
 2. DIMENSIONS TO (E) VALVE NUTS PROVIDED TO DETERMINE APPROXIMATE (E) WATERLINE DEPTHS. (E) END OF LINE BLOW OFF DEPTHS CAN BE ASSUMED TO BE APPROXIMATELY 3' TO 4' IN DEPTH.
 3. ALL WATER SERVICES SHALL BE 1" CLASS 250 POLYETHYLENE CTS PIPE UNLESS OTHERWISE NOTED
 4. REMOVE AND REPLACE STORM DRAIN INFRASTRUCTURE AS NEEDED FOR WATER MAIN REPLACEMENT
 5. SALVAGE VALVE BOXES AND LIDS, RETURN TO THE CITY OF ARCATA CORPYARD
 6. ANY DAMAGE TO CONCRETE COLLARS ON MANHOLES OR VALVES SHALL BE REPAIRED BY THE CONTRACTOR TO CITY STANDARD
 7. IF THERE ARE ANY CIRCUMSTANCES WHERE A SEWER LINE CROSSES A WATER LINE, THE LENGTH OF WATER PIPE SHALL BE CENTERED OVER THE SEWER LINE TO REDUCE THE RISK OF CROSS CONTAMINATION. SEE DETAIL
 8. ALL CONCRETE RELATED DEMOLITION AND REPLACEMENT TO FACILITATE WATER PIPE AND WATER METER INSTALLATION SHALL BE INCIDENTAL TO THAT ITEM OF WORK (UNLESS OTHERWISE NOTED). A MINIMUM OF ONE 5X5' PCC PANEL WILL BE REPLACED FOR EVERY WATER METER, UNLESS OTHERWISE NOTED.
 9. TRENCHING & STREET PAVEMENT RESTORATION WORK SHALL BE IN ACCORDANCE WITH THE CITY STD DTL G-02 AND ST-30.
 10. DEMOLISH EXISTING WATERLINES AND REPLACE WITH C900 PIPE A MINIMUM OF 10 FEET IN EACH DIRECTION FROM PROPOSED VALVE CLUSTERS, UNLESS OTHERWISE NOTED.
 11. DEMOLITION OF EXISTING VALVE ASSEMBLIES SHALL BE INCIDENTAL TO THE VALVE INSTALLATION ITEM OF WORK.
 12. CONNECT ALL NEW PIPING TO EXISTING PER CITY STANDARD DETAIL W-50.

SHEET KEY NOTES	
1	(N) 1" SERVICE LINE & WATER METER PER CITY STD DTL W-05
2	(N) 2" SERVICE LINE & WATER METER PER CITY STD DTL W-17
3	(N) 3 FLANGE TEE PER CITY STD DTL W-50
4	(N) 4 FLANGE CROSS PER CITY STD DTL W-50
5	(N) GATE VALVE AND BOX PER CITY STD DTL W-02
6	(N) FIRE HYDRANT, 6" FIRE LINE, & 6" GATE VALVE PER CITY STD DTL W-40
7	(N) BLOWOFF VALVE PER CITY STD DTL W-13
8	(N) 6" FIRE LINE & 6" GATE VALVE PER CITY STD DTL W-09
A	ABANDON (E) WATERLINE IN PLACE PER CITY STD DTL SS-14
R	REMOVE (E) WATERLINE, (TYP)
N	INSTALL (N) WATERLINE, (TYP)

J ST – PLAN VIEW
STATION 5+50 TO 13+00

 K ST – PLAN VIEW
STATION 3+00 TO 9+40

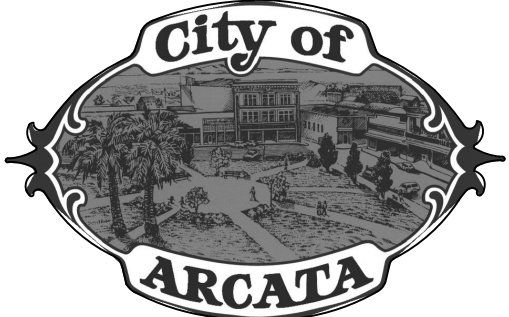

Sheet Title
J & K ST

Project Name
STEEL WATERLINE REPLACEMENT PROJECT

Project Address
VARIOUS LOCATIONS

Designed By
JONATHAN A. KIRCHUBEL

Drawn By
JONATHAN A. KIRCHUBEL

Checked By
DAVID CAISSE



Approved By
NETRA B. KHATRI

Date
JANUARY 2025

Sheet
C-112

Scale
1"=30'


Page
17

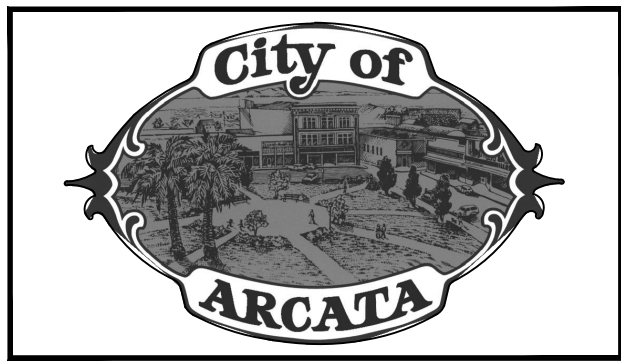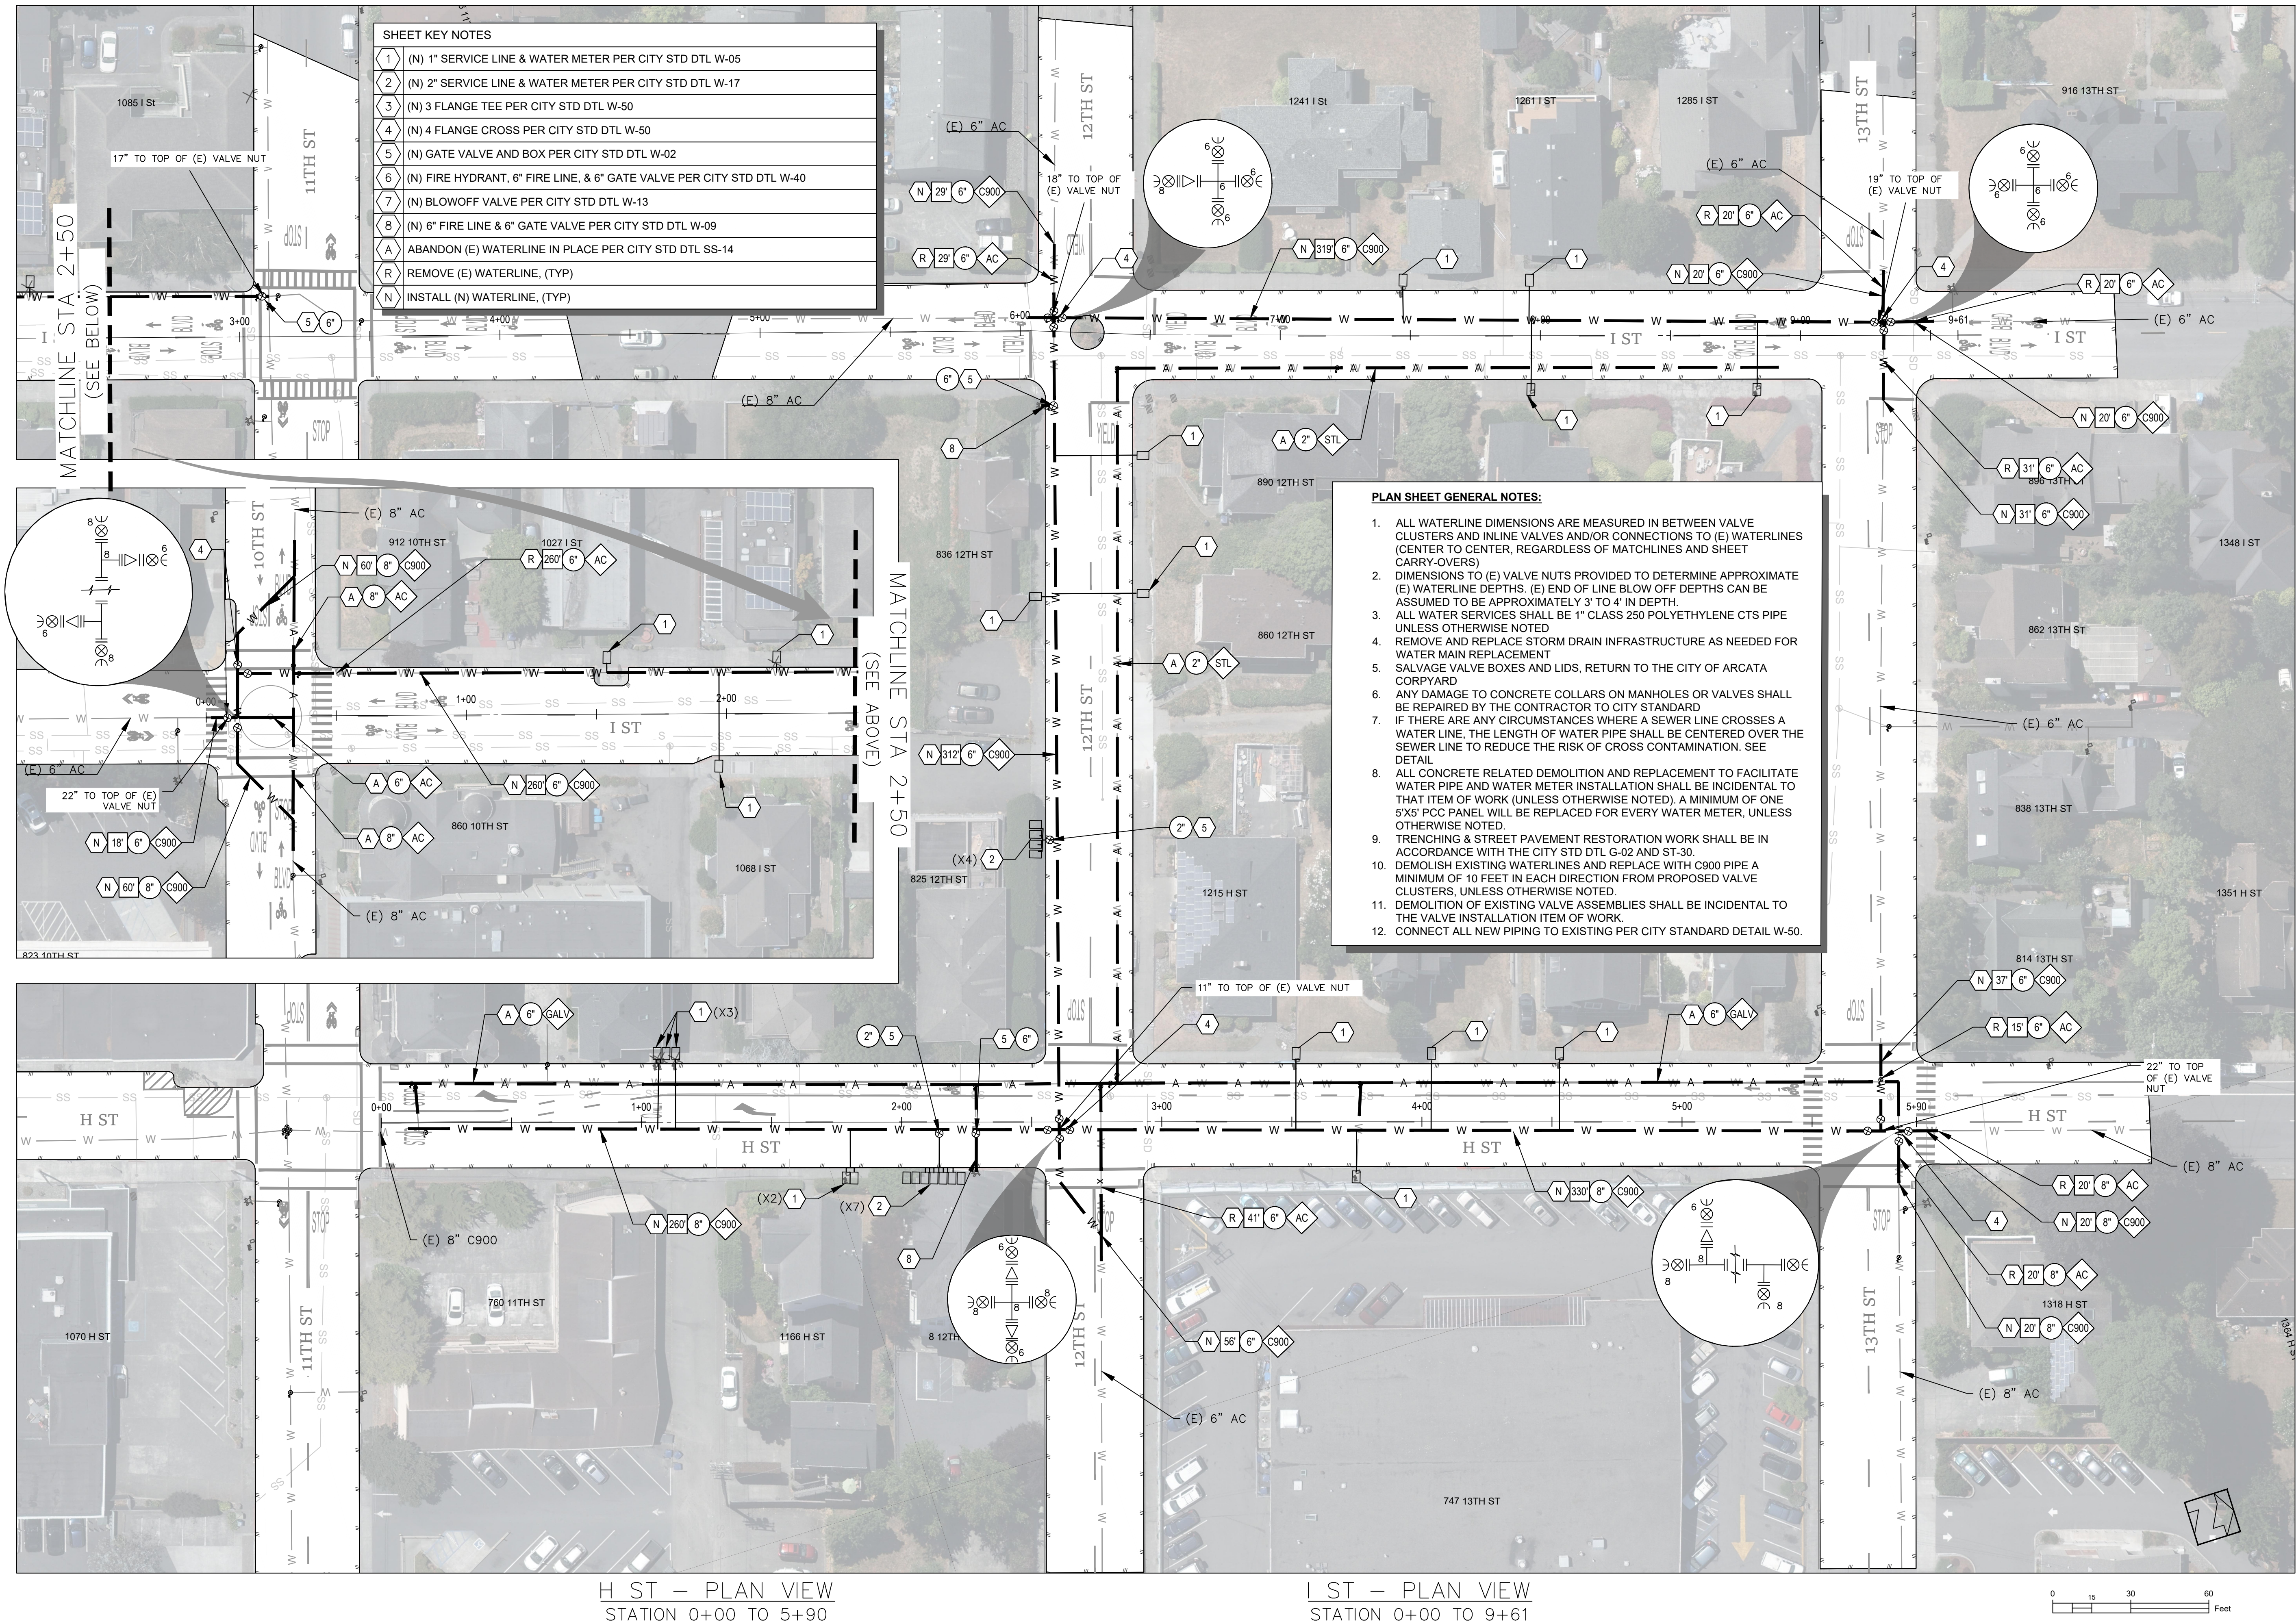

Sheet Title	H ST & I ST
Project Name	STEEL WATERLINE REPLACEMENT PROJECT

Project Address	VARIOUS LOCATIONS
Designed By	JONATHAN A. KIRCHUBEL
Drawn By	JONATHAN A. KIRCHUBEL
Checked By	DAVID CAISSE
Approved By	NETRA B. KHATRI

Date	JANUARY 2025	Sheet	C-113
Scale	1"=30'	Page	18


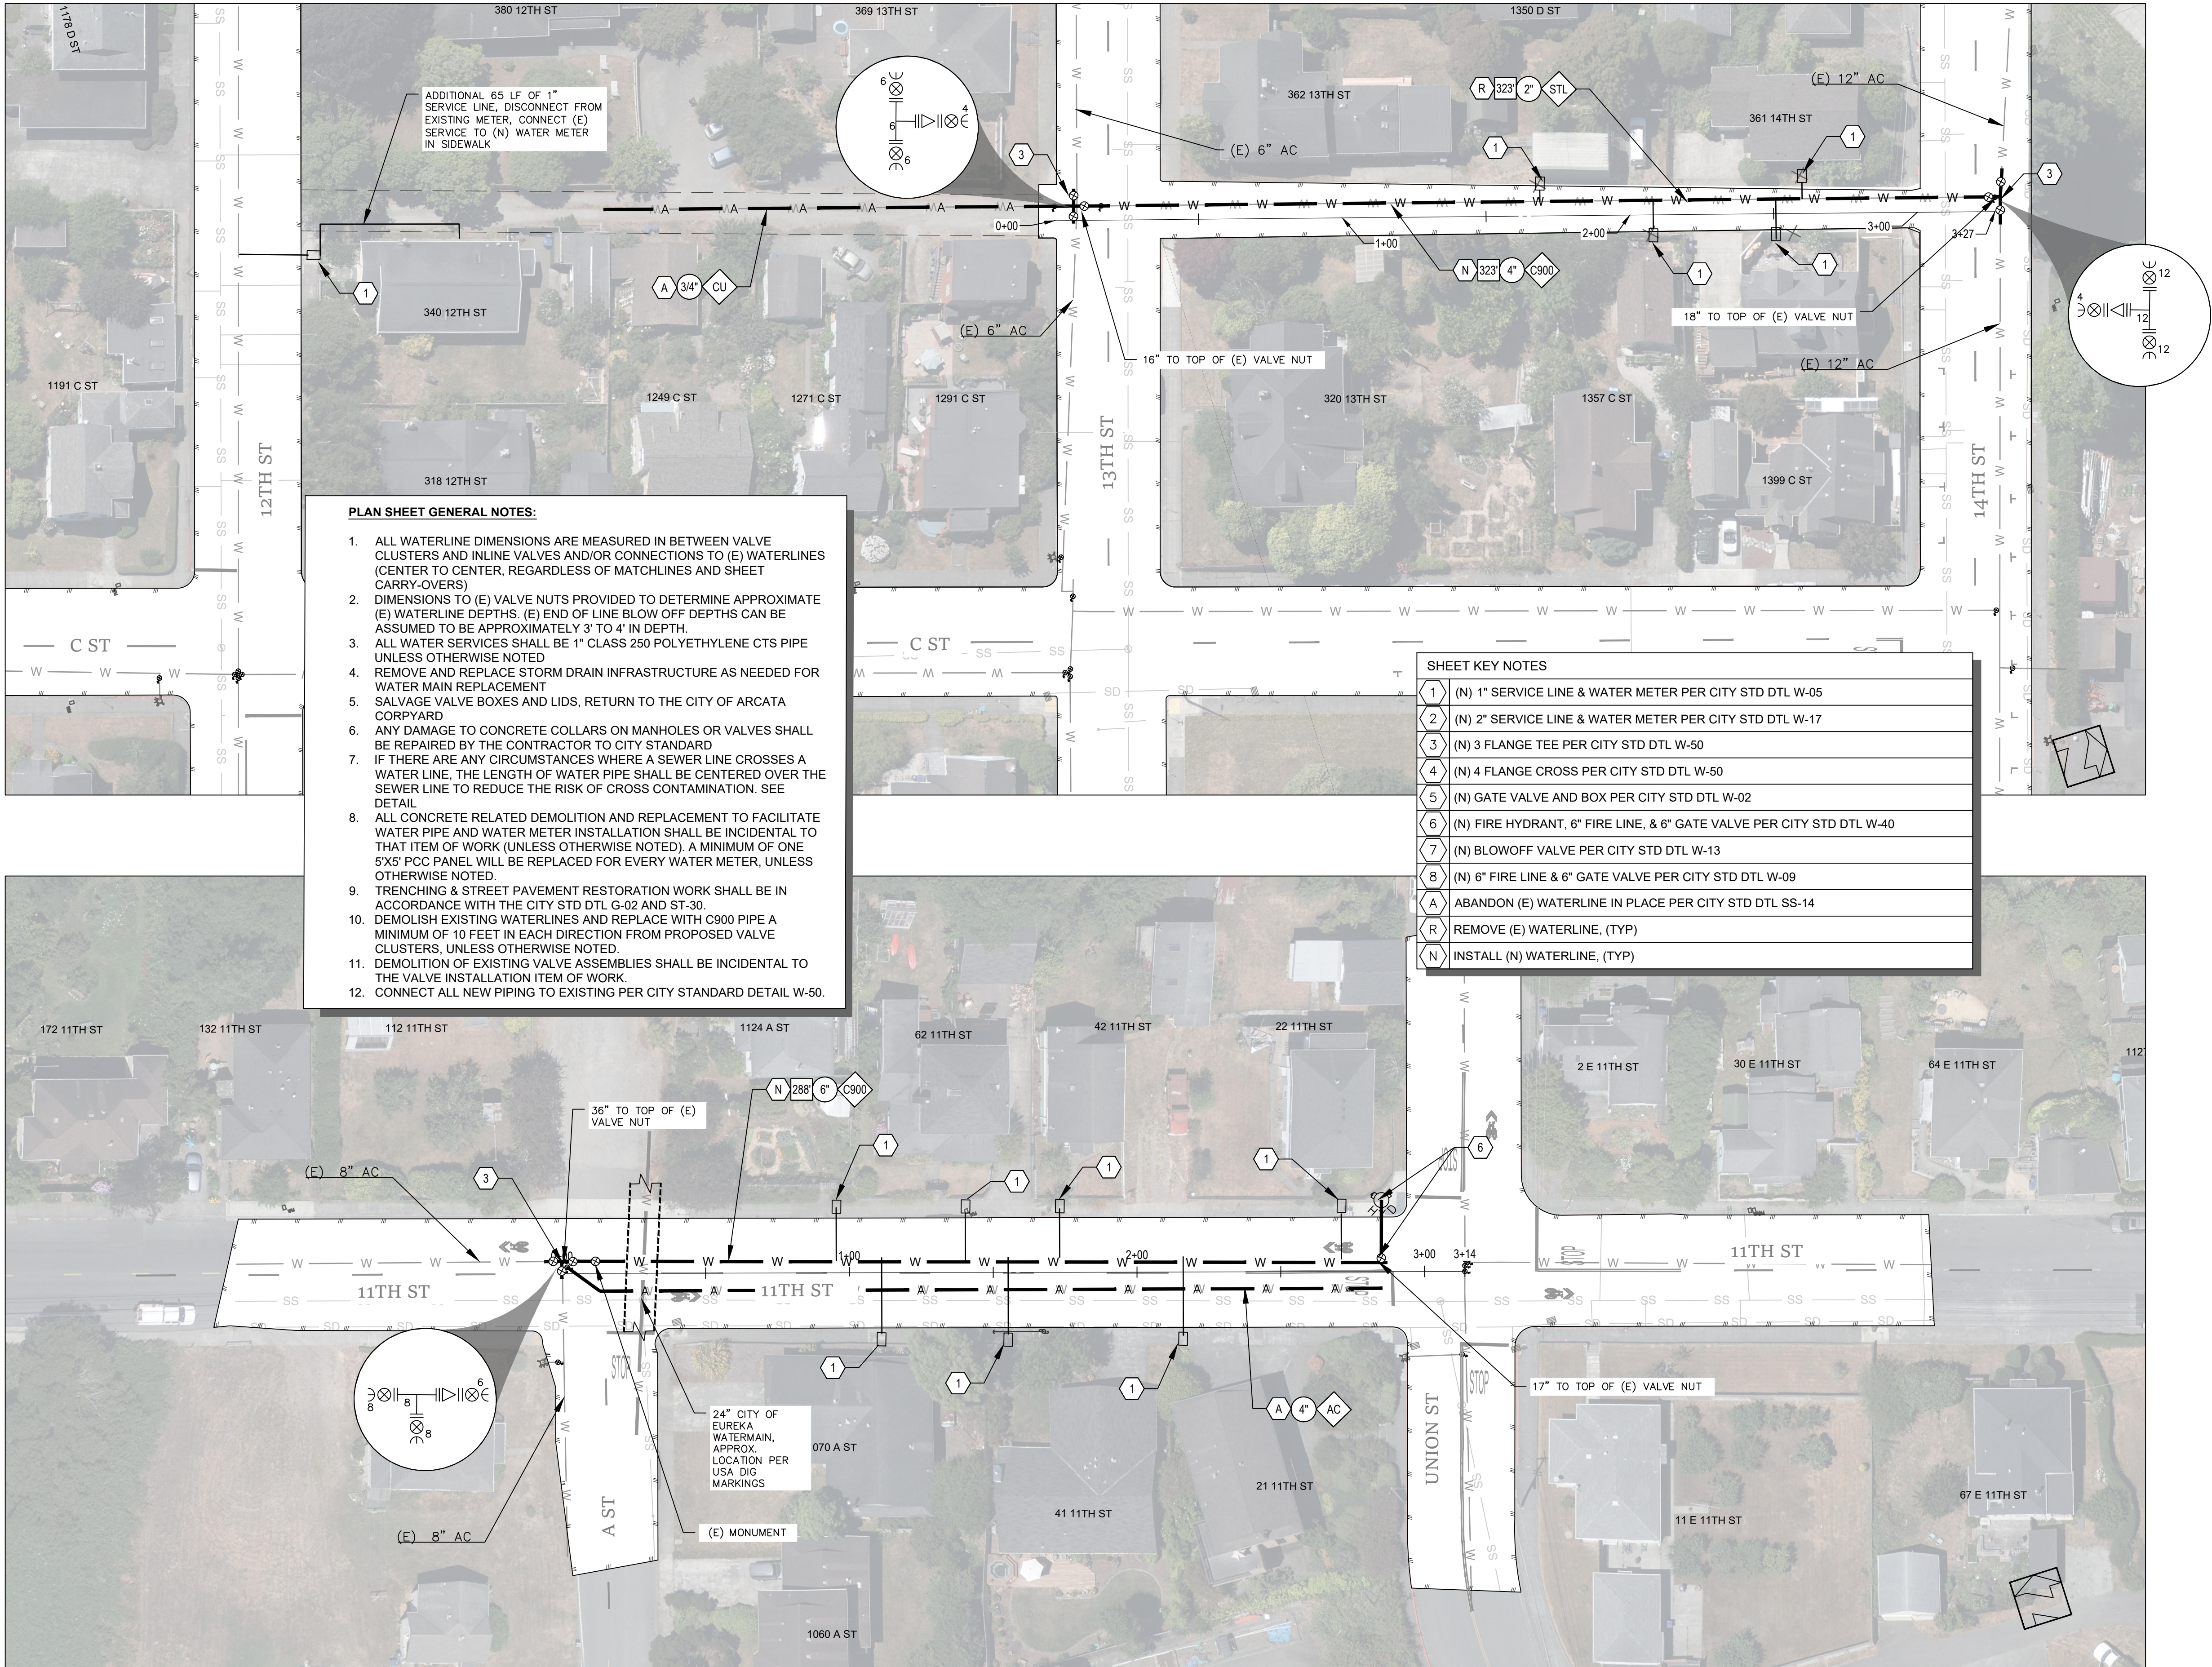


- PLAN SHEET GENERAL NOTES:**
1. ALL WATERLINE DIMENSIONS ARE MEASURED IN BETWEEN VALVE CLUSTERS AND INLINE VALVES AND/OR CONNECTIONS TO (E) WATERLINES (CENTER TO CENTER, REGARDLESS OF MATCHLINES AND SHEET CARRY-OVERS)
 2. DIMENSIONS TO (E) VALVE NUTS PROVIDED TO DETERMINE APPROXIMATE (E) WATERLINE DEPTHS. (E) END OF LINE BLOW OFF DEPTHS CAN BE ASSUMED TO BE APPROXIMATELY 3' TO 4' IN DEPTH.
 3. ALL WATER SERVICES SHALL BE 1" CLASS 250 POLYETHYLENE CTS PIPE UNLESS OTHERWISE NOTED
 4. REMOVE AND REPLACE STORM DRAIN INFRASTRUCTURE AS NEEDED FOR WATER MAIN REPLACEMENT
 5. SALVAGE VALVE BOXES AND LIDS, RETURN TO THE CITY OF ARCATA CORPYARD
 6. ANY DAMAGE TO CONCRETE COLLARS ON MANHOLES OR VALVES SHALL BE REPAIRED BY THE CONTRACTOR TO CITY STANDARD
 7. IF THERE ARE ANY CIRCUMSTANCES WHERE A SEWER LINE CROSSES A WATER LINE, THE LENGTH OF WATER PIPE SHALL BE CENTERED OVER THE SEWER LINE TO REDUCE THE RISK OF CROSS CONTAMINATION. SEE DETAIL
 8. ALL CONCRETE RELATED DEMOLITION AND REPLACEMENT TO FACILITATE WATER PIPE AND WATER METER INSTALLATION SHALL BE INCIDENTAL TO THAT ITEM OF WORK (UNLESS OTHERWISE NOTED). A MINIMUM OF ONE 5X5' PCC PANEL WILL BE REPLACED FOR EVERY WATER METER, UNLESS OTHERWISE NOTED.
 9. TRENCHING & STREET PAVEMENT RESTORATION WORK SHALL BE IN ACCORDANCE WITH THE CITY STD DTL G-02 AND ST-30.
 10. DEMOLISH EXISTING WATERLINES AND REPLACE WITH C900 PIPE A MINIMUM OF 10 FEET IN EACH DIRECTION FROM PROPOSED VALVE CLUSTERS, UNLESS OTHERWISE NOTED.
 11. DEMOLITION OF EXISTING VALVE ASSEMBLIES SHALL BE INCIDENTAL TO THE VALVE INSTALLATION ITEM OF WORK.
 12. CONNECT ALL NEW PIPING TO EXISTING PER CITY STANDARD DETAIL W-50.



SHEET KEY NOTES	
1	(N) 1" SERVICE LINE & WATER METER PER CITY STD DTL W-05
2	(N) 2" SERVICE LINE & WATER METER PER CITY STD DTL W-17
3	(N) 3 FLANGE TEE PER CITY STD DTL W-50
4	(N) 4 FLANGE CROSS PER CITY STD DTL W-50
5	(N) GATE VALVE AND BOX PER CITY STD DTL W-02
6	(N) FIRE HYDRANT, 6" FIRE LINE, & 6" GATE VALVE PER CITY STD DTL W-40
7	(N) BLOWOFF VALVE PER CITY STD DTL W-13
8	(N) 6" FIRE LINE & 6" GATE VALVE PER CITY STD DTL W-09
A	ABANDON (E) WATERLINE IN PLACE PER CITY STD DTL SS-14
R	REMOVE (E) WATERLINE, (TYP)
N	INSTALL (N) WATERLINE, (TYP)

11TH ST – PLAN VIEW
STATION 0+00 TO 3+14

 ALLEY (B/T 13TH & 14TH) – PLAN VIEW
STATION 0+00 TO 3+27

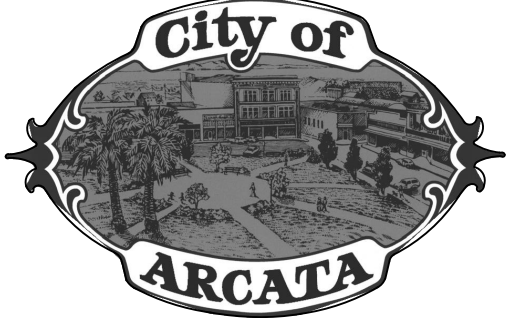

Sheet Title	11TH ST & ALLEY (B/T 13TH & 14TH)
	STEEL WATERLINE REPLACEMENT PROJECT
Project Address	
VARIOUS LOCATIONS	
Designed By	
JONATHAN A. KIRCHUBEL	
Drawn By	
JONATHAN A. KIRCHUBEL	
Checked By	
DAVID CAISSE	
Approved By	
NETRA B. KHATRI	
Date	January 2025
Sheet	C-114
Scale	1"=30'
Page	19

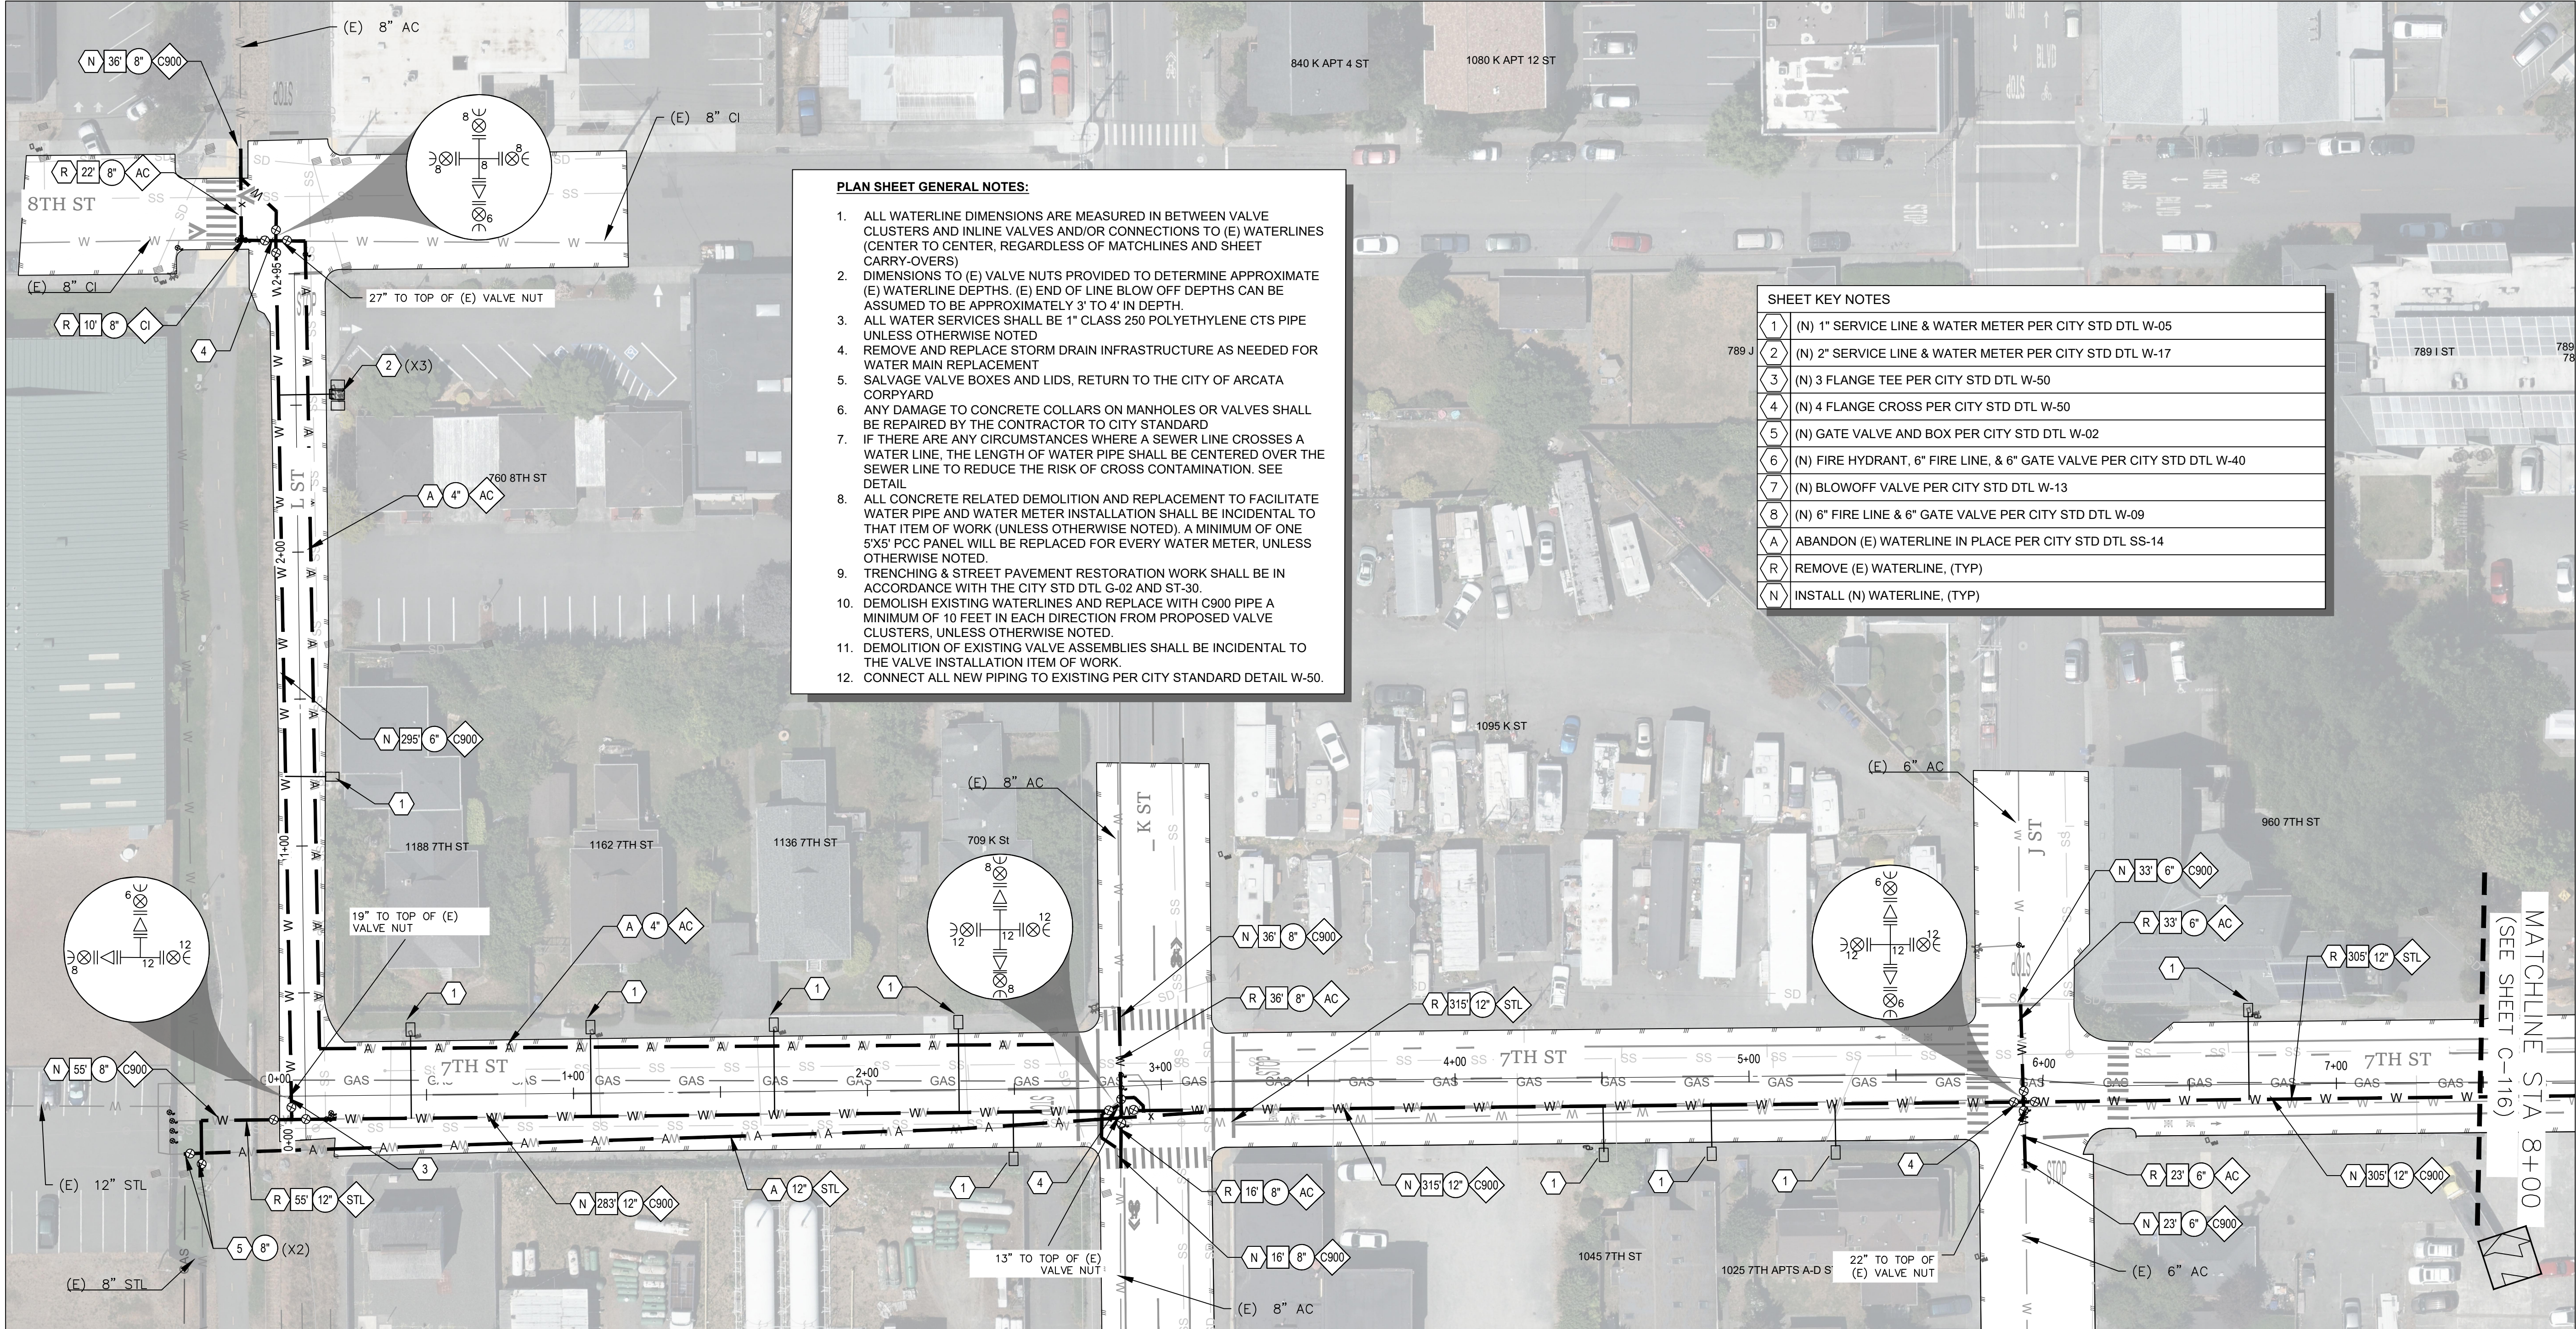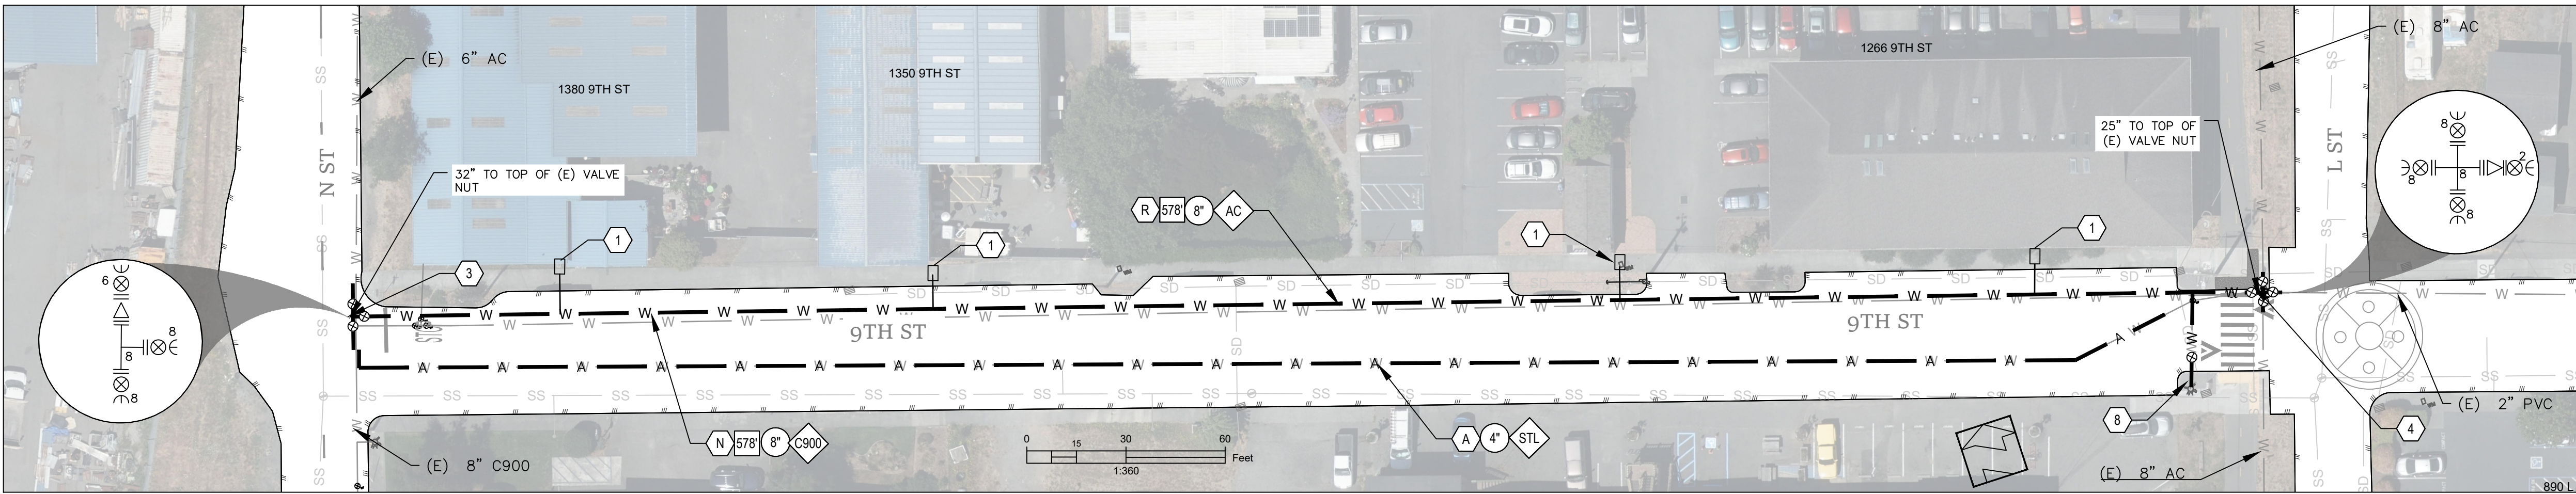

9TH ST — PLAN VIEW
STATION 0+00 TO 6+11

L ST — PLAN VIEW
STATION 0+00 TO 2+95


7TH ST — PLAN VIEW
STATION 0+00 TO 7+50

PLAN SHEET GENERAL NOTES:

1. ALL WATERLINE DIMENSIONS ARE MEASURED IN BETWEEN VALVE CLUSTERS AND INLINE VALVES AND/OR CONNECTIONS TO (E) WATERLINES (CENTER TO CENTER, REGARDLESS OF MATCHLINES AND SHEET CARRY-OVERS)
2. DIMENSIONS TO (E) VALVE NUTS PROVIDED TO DETERMINE APPROXIMATE (E) WATERLINE DEPTHS. (E) END OF LINE BLOW OFF DEPTHS CAN BE ASSUMED TO BE APPROXIMATELY 3' TO 4' IN DEPTH.
3. ALL WATER SERVICES SHALL BE 1" CLASS 250 POLYETHYLENE CTS PIPE UNLESS OTHERWISE NOTED
4. REMOVE AND REPLACE STORM DRAIN INFRASTRUCTURE AS NEEDED FOR WATER MAIN REPLACEMENT
5. SALVAGE VALVE BOXES AND LIDS, RETURN TO THE CITY OF ARCATA CORPYARD
6. ANY DAMAGE TO CONCRETE COLLARS ON MANHOLES OR VALVES SHALL BE REPAIRED BY THE CONTRACTOR TO CITY STANDARD
7. IF THERE ARE ANY CIRCUMSTANCES WHERE A SEWER LINE CROSSES A WATER LINE, THE LENGTH OF WATER PIPE SHALL BE CENTERED OVER THE SEWER LINE TO REDUCE THE RISK OF CROSS CONTAMINATION. SEE DETAIL
8. ALL CONCRETE RELATED DEMOLITION AND REPLACEMENT TO FACILITATE WATER PIPE AND WATER METER INSTALLATION SHALL BE INCIDENTAL TO THAT ITEM OF WORK (UNLESS OTHERWISE NOTED). A MINIMUM OF ONE 5'X5' PCC PANEL WILL BE REPLACED FOR EVERY WATER METER, UNLESS OTHERWISE NOTED.
9. TRENCHING & STREET PAVEMENT RESTORATION WORK SHALL BE IN ACCORDANCE WITH THE CITY STD DTL G-02 AND ST-30.
10. DEMOLISH EXISTING WATERLINES AND REPLACE WITH C900 PIPE A MINIMUM OF 10 FEET IN EACH DIRECTION FROM PROPOSED VALVE CLUSTERS, UNLESS OTHERWISE NOTED.
11. DEMOLITION OF EXISTING VALVE ASSEMBLIES SHALL BE INCIDENTAL TO THE VALVE INSTALLATION ITEM OF WORK.
12. CONNECT ALL NEW PIPING TO EXISTING PER CITY STANDARD DETAIL W-50.

SHEET KEY NOTES

- | | |
|---|---|
| 1 | (N) 1" SERVICE LINE & WATER METER PER CITY STD DTL W-05 |
| 2 | (N) 2" SERVICE LINE & WATER METER PER CITY STD DTL W-17 |
| 3 | (N) 3" FLANGE TEE PER CITY STD DTL W-50 |
| 4 | (N) 4" FLANGE CROSS PER CITY STD DTL W-50 |
| 5 | (N) GATE VALVE AND BOX PER CITY STD DTL W-02 |
| 6 | (N) FIRE HYDRANT, 6" FIRE LINE, & 6" GATE VALVE PER CITY STD DTL W-40 |
| 7 | (N) BLOWOFF VALVE PER CITY STD DTL W-13 |
| 8 | (N) 6" FIRE LINE & 6" GATE VALVE PER CITY STD DTL W-09 |
| A | ABANDON (E) WATERLINE IN PLACE PER CITY STD DTL SS-14 |
| R | REMOVE (E) WATERLINE, (TYP) |
| N | INSTALL (N) WATERLINE, (TYP) |

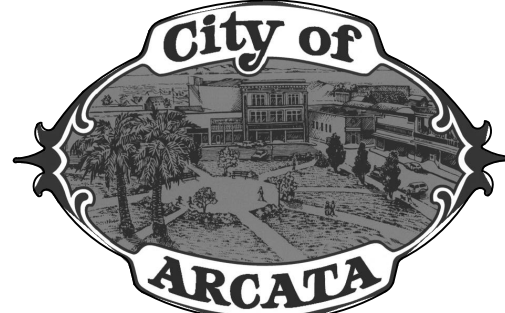


9TH ST, L ST, & 7TH ST

STEEL WATERLINE REPLACEMENT PROJECT

Project Address
VARIOUS LOCATIONS



Designed By
JONATHAN A. KIRCHUBEL
Drawn By
JONATHAN A. KIRCHUBEL
Checked By
DAVID CAISSE
Approved By
NETRA B. KHATRI

Date JANUARY 2025	Sheet C-115
Scale 1"=30'	Page 20

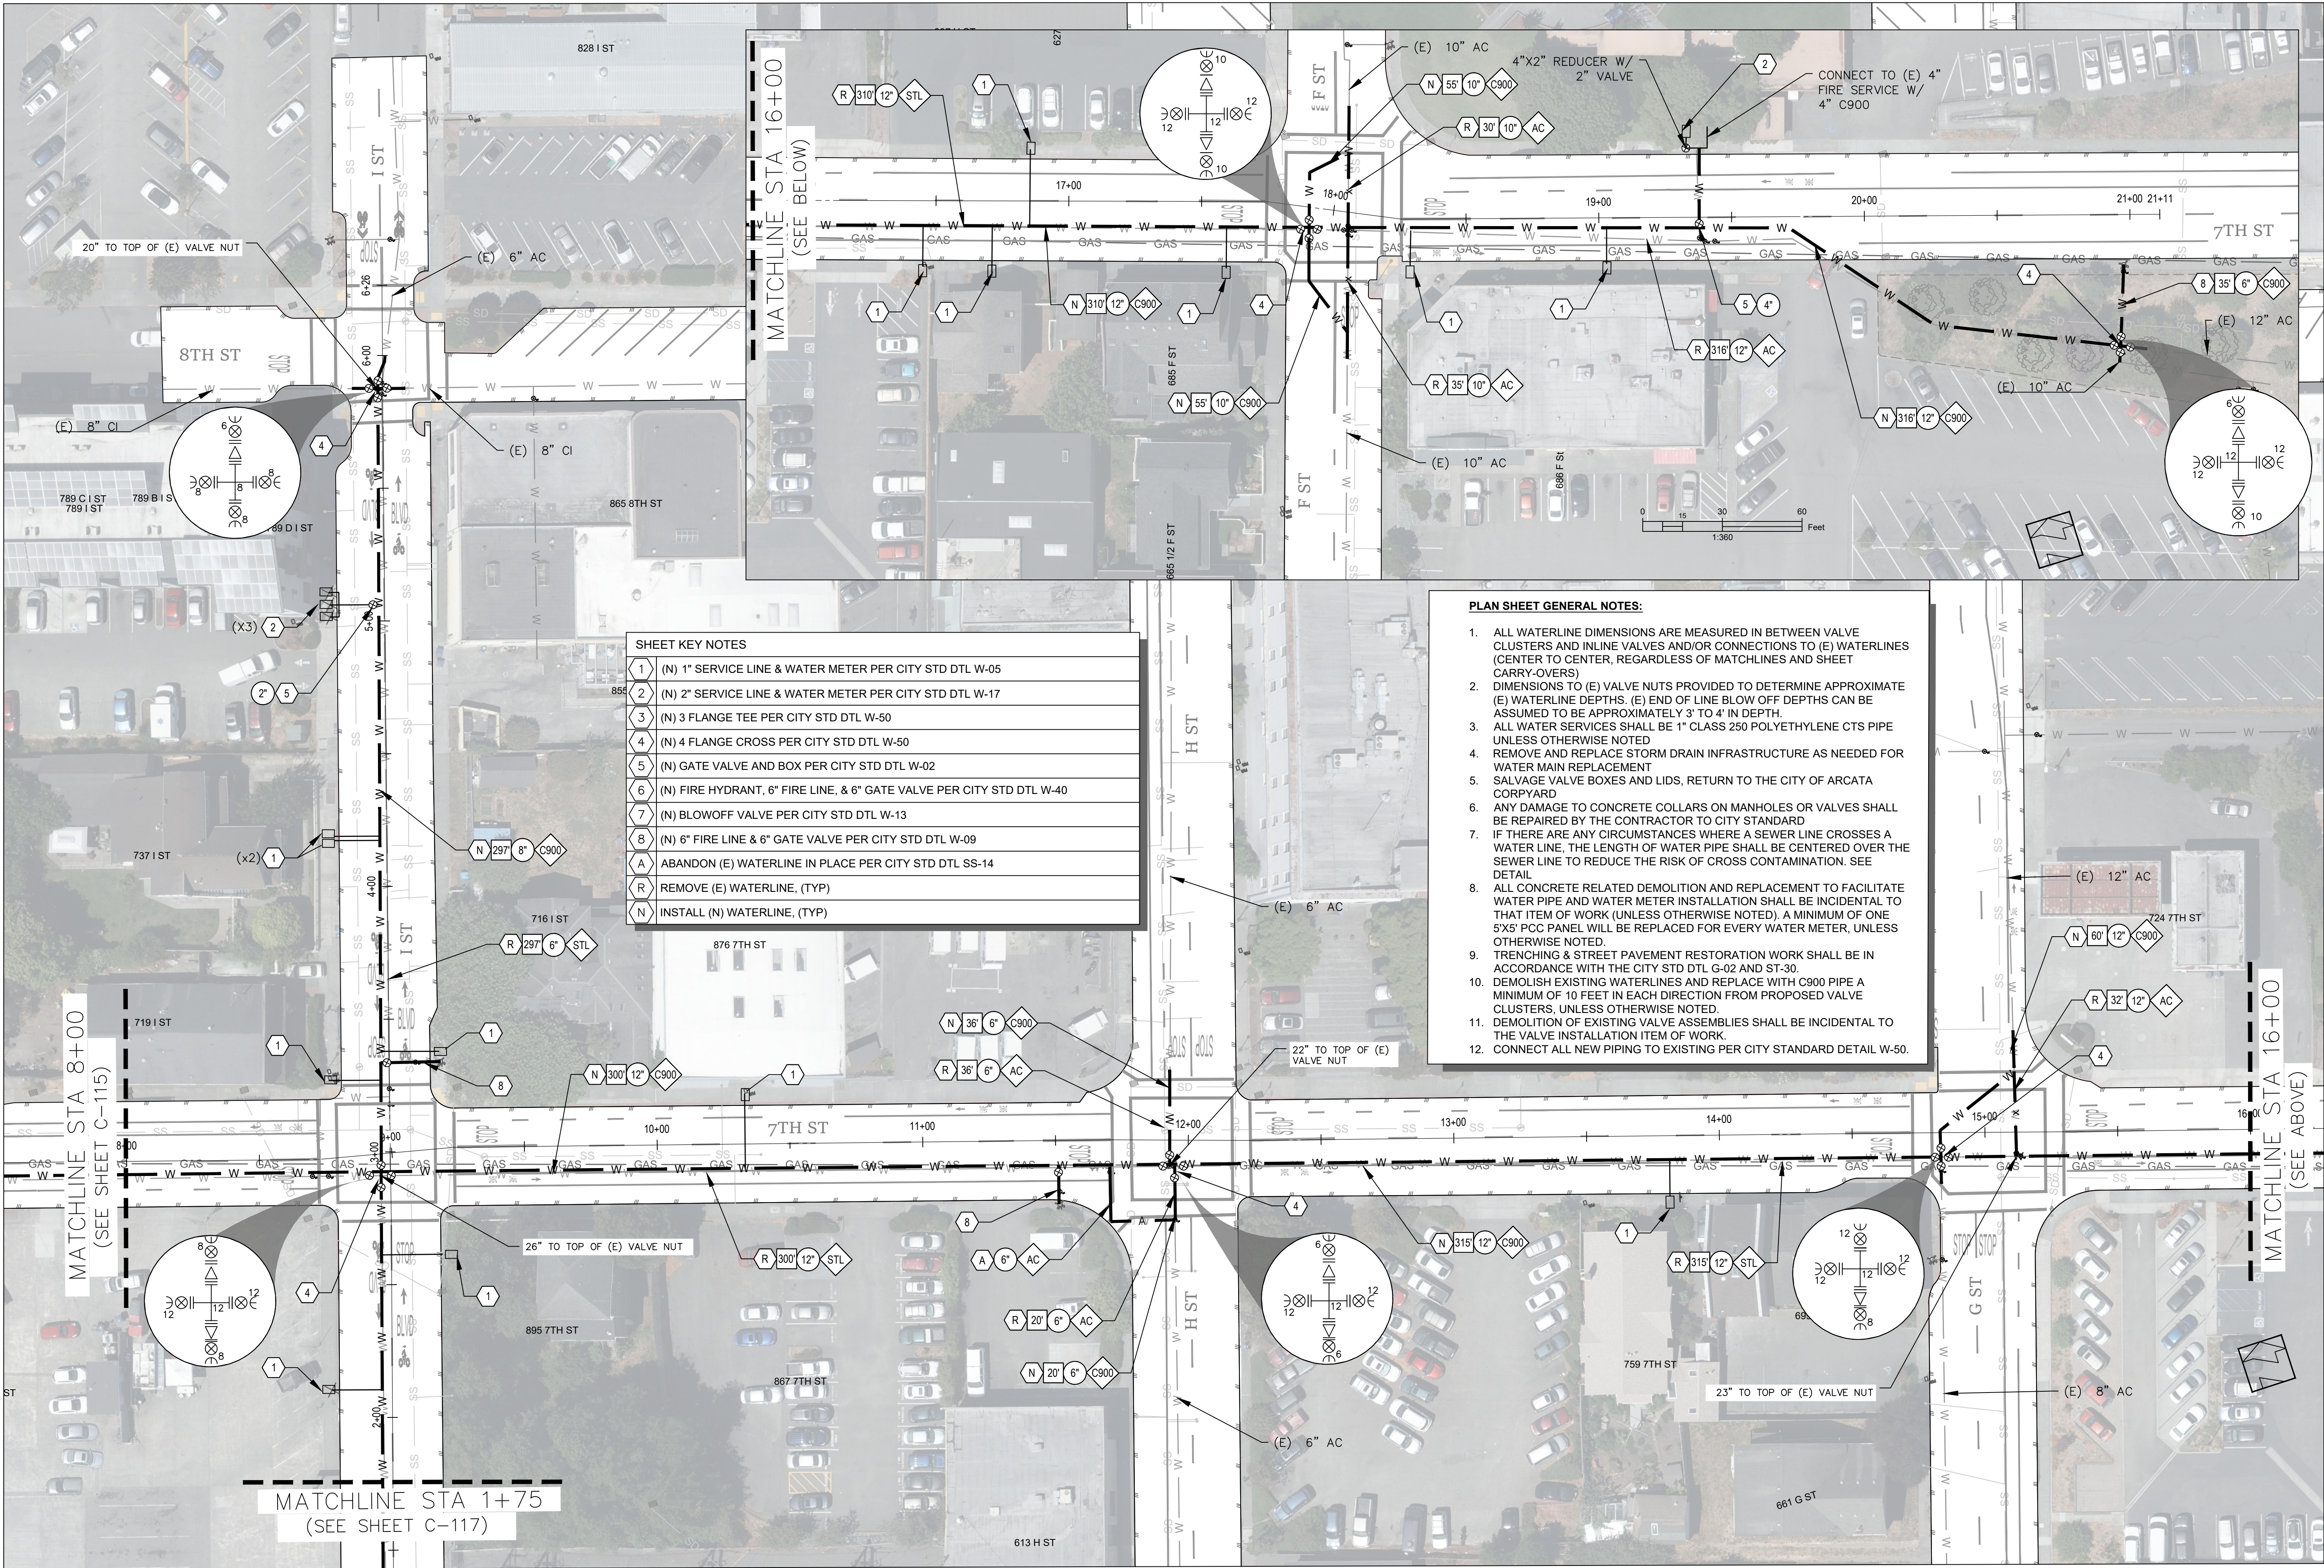

I ST — PLAN VIEW
STATION 1+75 TO 6+26


 
7TH ST — PLAN VIEW
STATION 8+00 TO 21+11

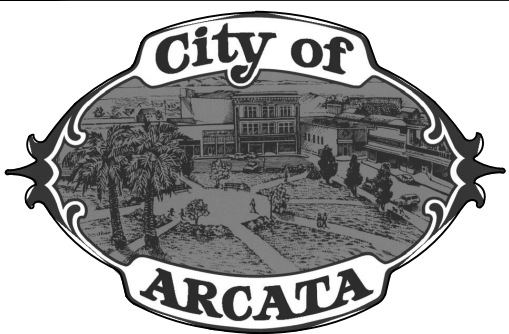

Sheet Title	
I ST & 7TH ST	
Project Name	
STEEL WATERLINE REPLACEMENT PROJECT	

Project Address	
VARIOUS LOCATIONS	
Designed By	JONATHAN A. KIRCHUBEL
Drawn By	JONATHAN A. KIRCHUBEL
Checked By	DAVID CAISSE
Approved By	NETRA B. KHATRI

Date	JANUARY 2025	Sheet	C-116
Scale	1"=30'	Page	21

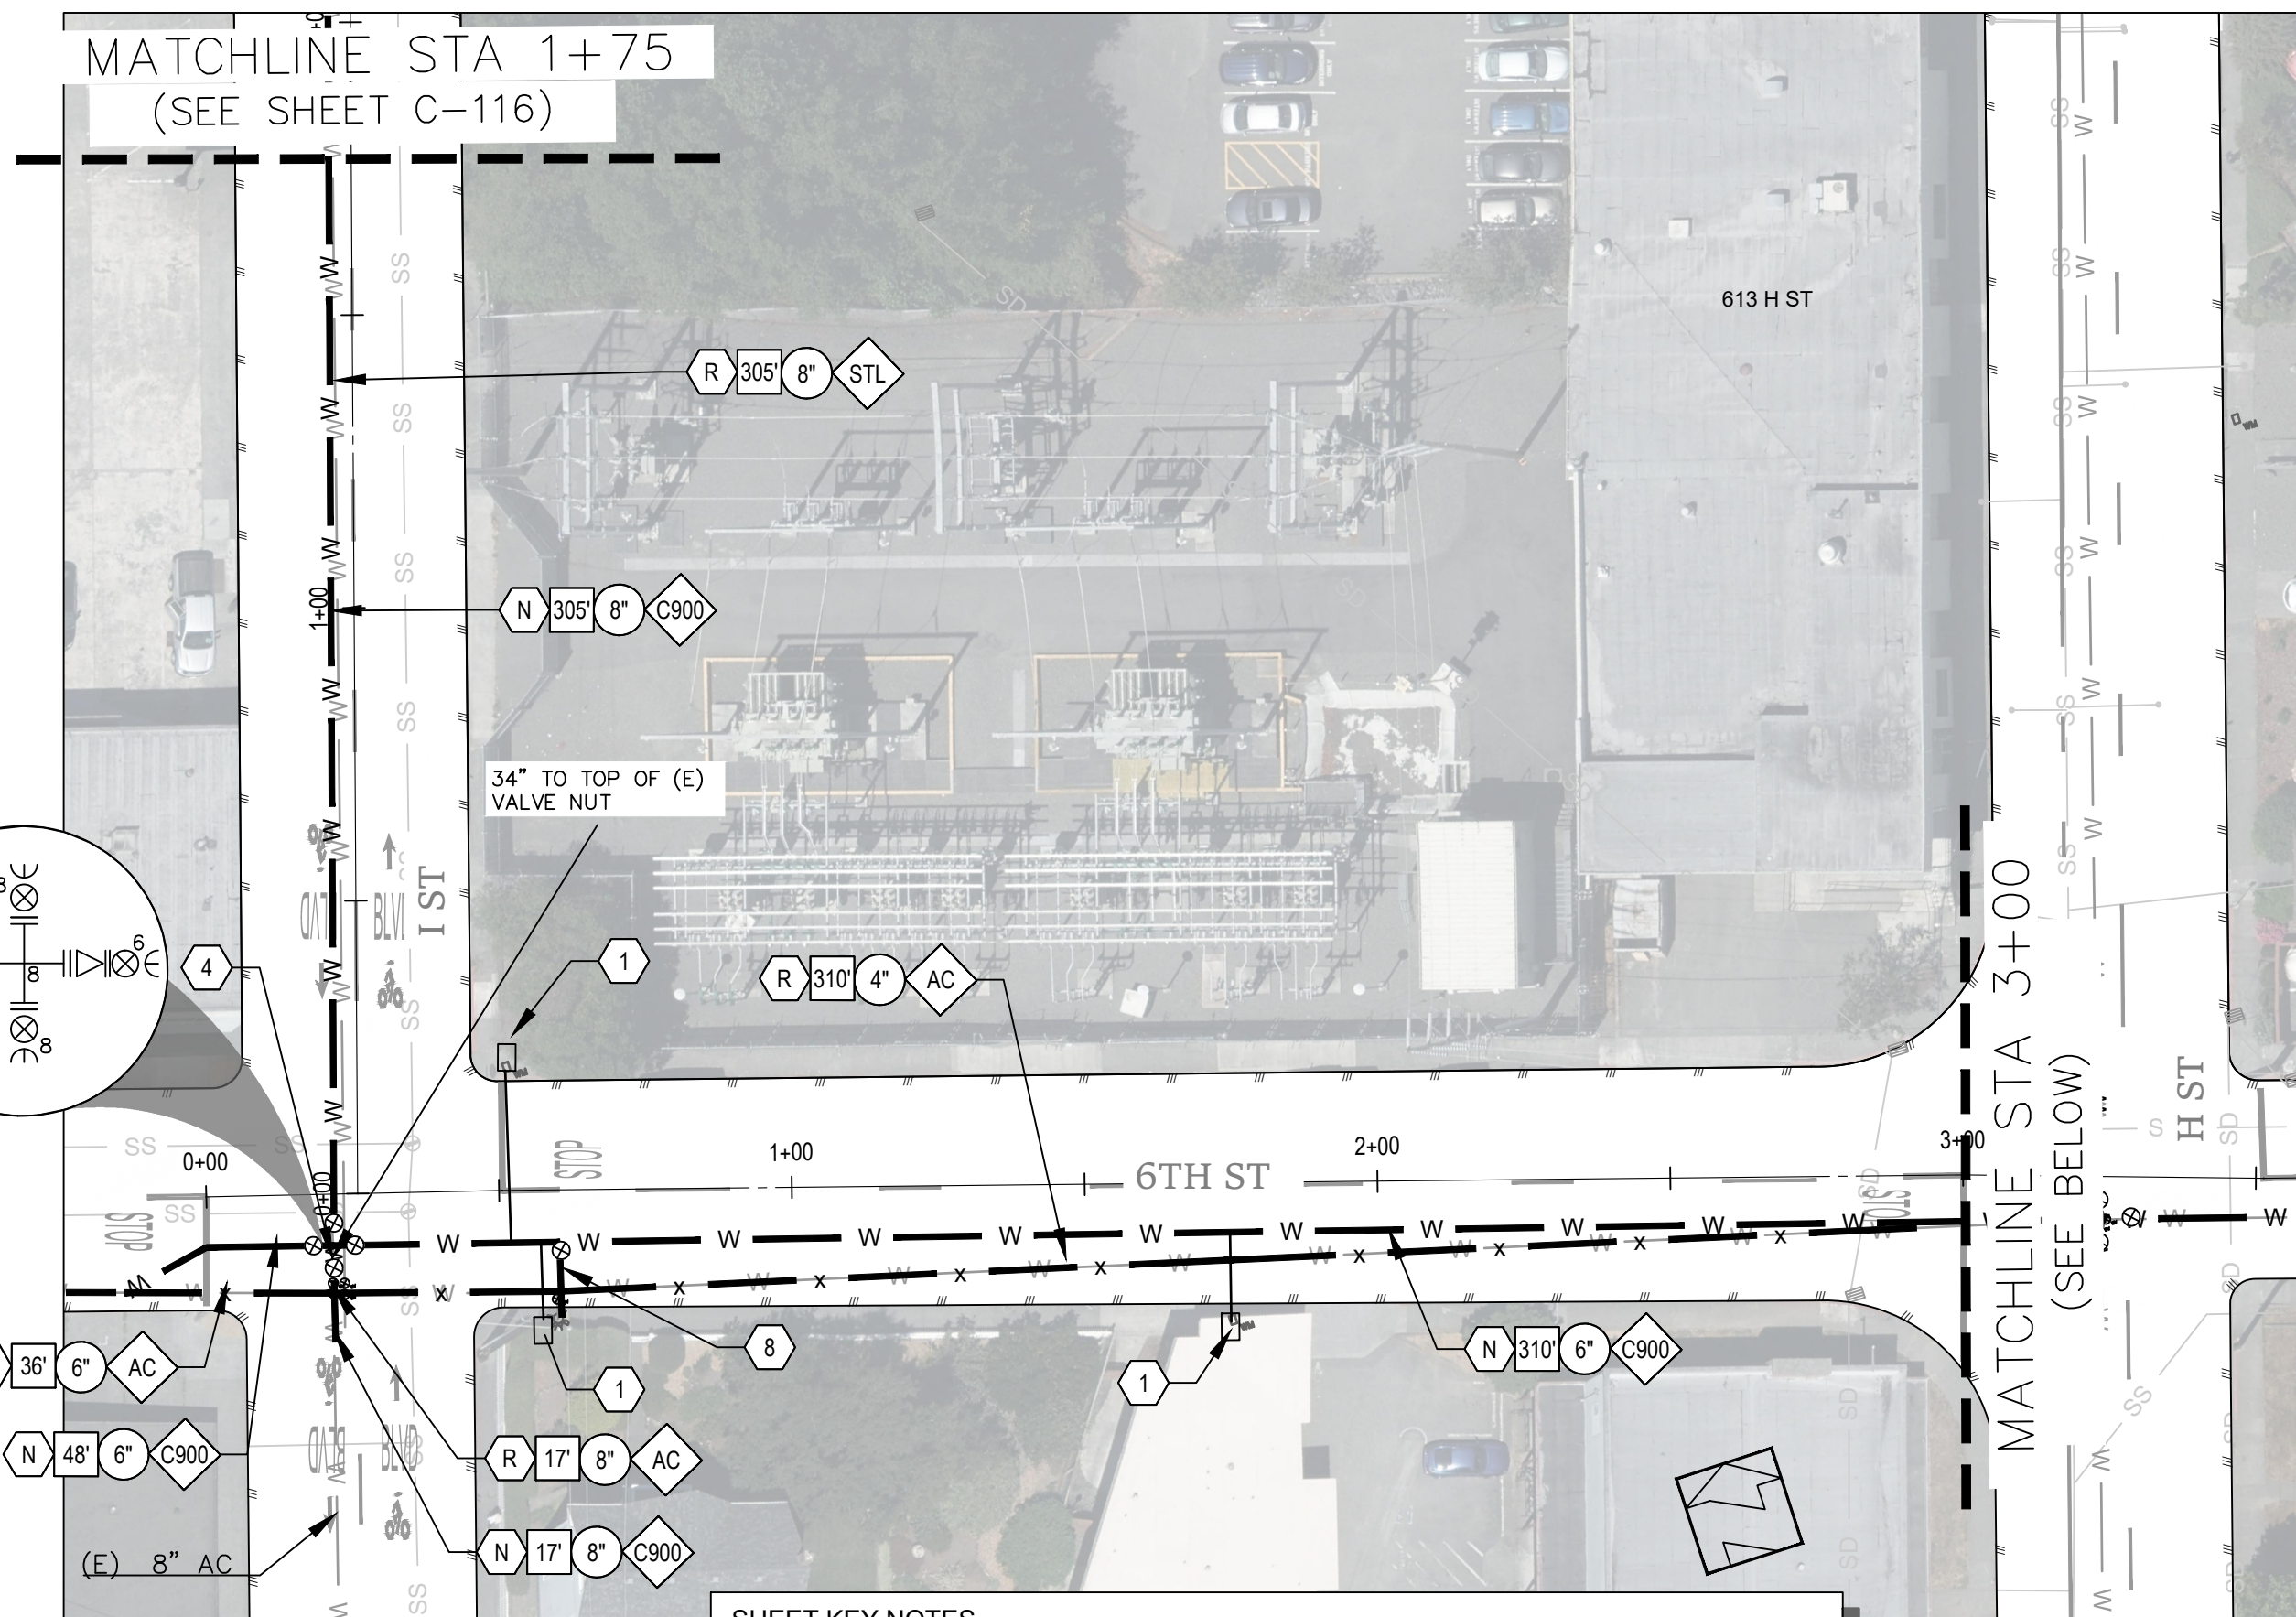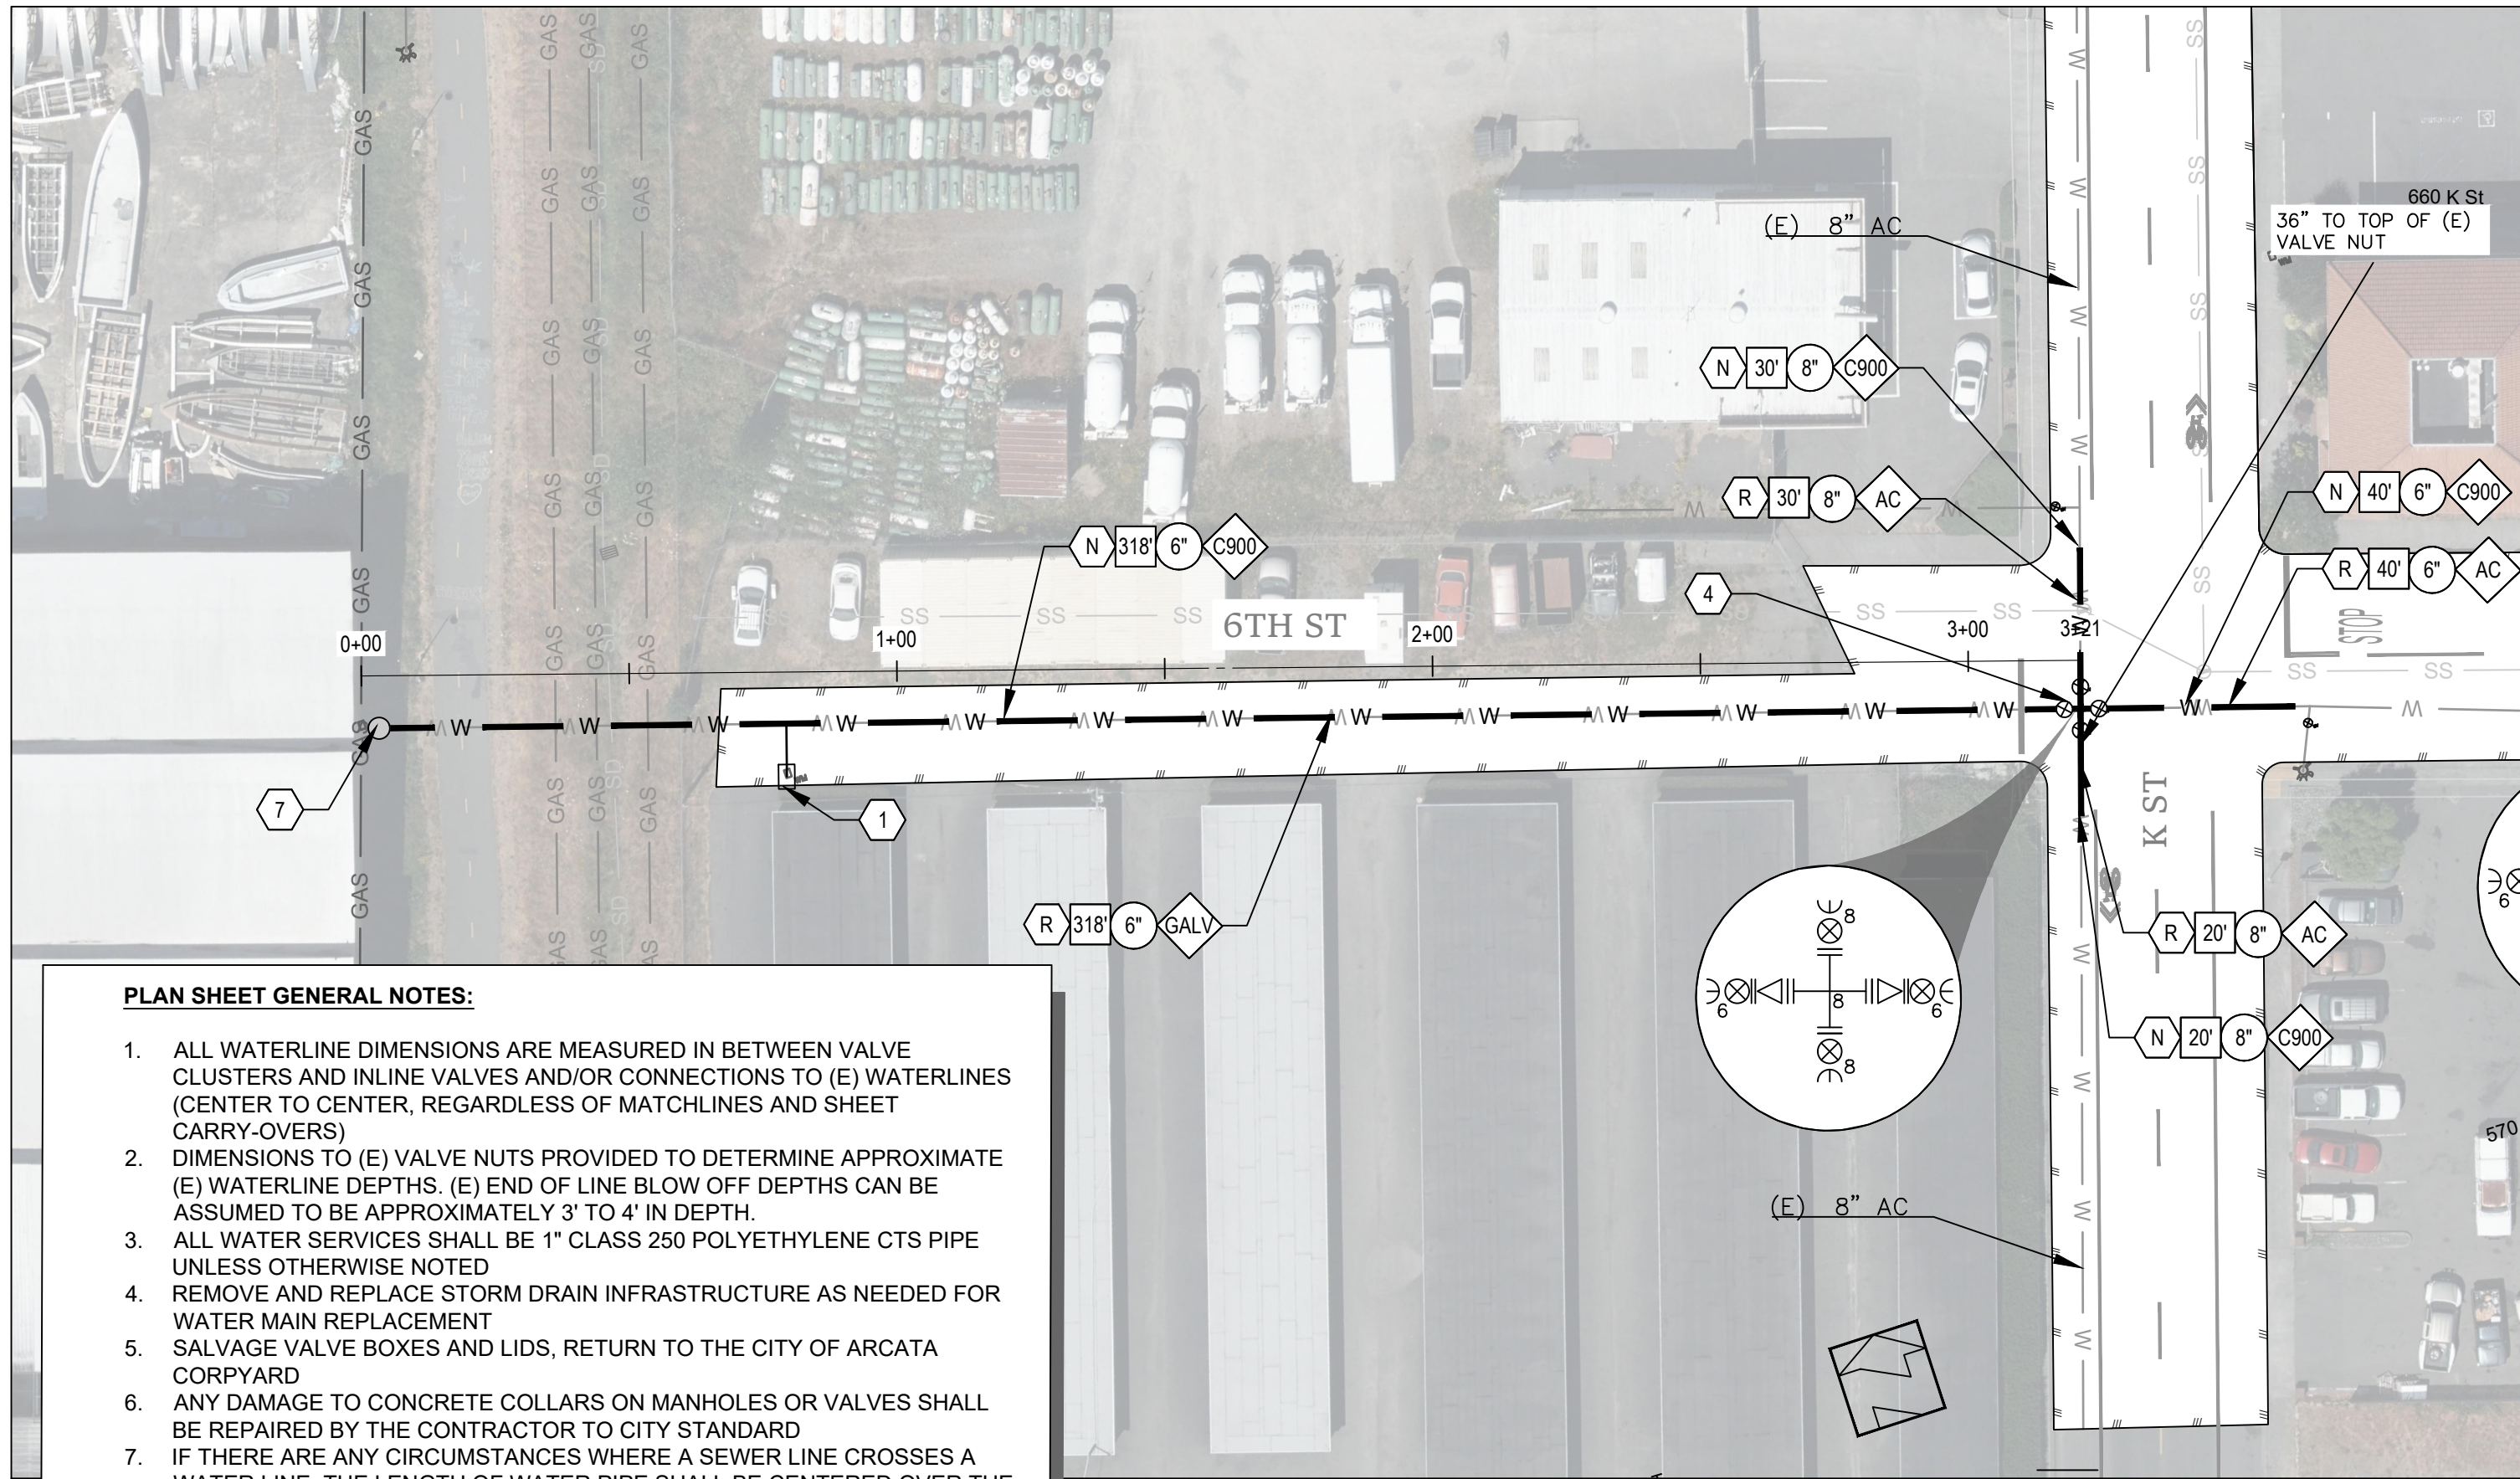


PLAN SHEET GENERAL NOTES:

1. ALL WATERLINE DIMENSIONS ARE MEASURED IN BETWEEN VALVE CLUSTERS AND INLINE VALVES AND/OR CONNECTIONS TO (E) WATERLINES (CENTER TO CENTER, REGARDLESS OF MATCHLINES AND SHEET CARRY-OVERS)
2. DIMENSIONS TO (E) VALVE NUTS PROVIDED TO DETERMINE APPROXIMATE (E) WATERLINE DEPTHS. (E) END OF LINE BLOW OFF DEPTHS CAN BE ASSUMED TO BE APPROXIMATELY 3' TO 4' IN DEPTH.
3. ALL WATER SERVICES SHALL BE 1" CLASS 250 POLYETHYLENE CTS PIPE UNLESS OTHERWISE NOTED
4. REMOVE AND REPLACE STORM DRAIN INFRASTRUCTURE AS NEEDED FOR WATER MAIN REPLACEMENT
5. SALVAGE VALVE BOXES AND LIDS, RETURN TO THE CITY OF ARCATA CORPYARD
6. ANY DAMAGE TO CONCRETE COLLARS ON MANHOLES OR VALVES SHALL BE REPAIRED BY THE CONTRACTOR TO CITY STANDARD
7. IF THERE ARE ANY CIRCUMSTANCES WHERE A SEWER LINE CROSSES A WATER LINE, THE LENGTH OF WATER PIPE SHALL BE CENTERED OVER THE SEWER LINE TO REDUCE THE RISK OF CROSS CONTAMINATION. SEE DETAIL
8. ALL CONCRETE RELATED DEMOLITION AND REPLACEMENT TO FACILITATE WATER PIPE AND WATER METER INSTALLATION SHALL BE INCIDENTAL TO THAT ITEM OF WORK (UNLESS OTHERWISE NOTED). A MINIMUM OF ONE 5'X5' PCC PANEL WILL BE REPLACED FOR EVERY WATER METER, UNLESS OTHERWISE NOTED.
9. TRENCHING & STREET PAVEMENT RESTORATION WORK SHALL BE IN ACCORDANCE WITH THE CITY STD DTL G-02 AND ST-30.
10. DEMOLISH EXISTING WATERLINES AND REPLACE WITH C900 PIPE A MINIMUM OF 10 FEET IN EACH DIRECTION FROM PROPOSED VALVE CLUSTERS, UNLESS OTHERWISE NOTED.
11. DEMOLITION OF EXISTING VALVE ASSEMBLIES SHALL BE INCIDENTAL TO THE VALVE INSTALLATION ITEM OF WORK.
12. CONNECT ALL NEW PIPING TO EXISTING PER CITY STANDARD DETAIL W-50.



SHEET KEY NOTES

- | | |
|---|---|
| 1 | (N) 1" SERVICE LINE & WATER METER PER CITY STD DTL W-05 |
| 2 | (N) 2" SERVICE LINE & WATER METER PER CITY STD DTL W-17 |
| 3 | (N) 3 FLANGE TEE PER CITY STD DTL W-50 |
| 4 | (N) 4 FLANGE CROSS PER CITY STD DTL W-50 |
| 5 | (N) GATE VALVE AND BOX PER CITY STD DTL W-02 |
| 6 | (N) FIRE HYDRANT, 6" FIRE LINE, & 6" GATE VALVE PER CITY STD DTL W-40 |
| 7 | (N) BLOWOFF VALVE PER CITY STD DTL W-13 |
| 8 | (N) 6" FIRE LINE & 6" GATE VALVE PER CITY STD DTL W-09 |
| A | ABANDON (E) WATERLINE IN PLACE PER CITY STD DTL SS-14 |
| R | REMOVE (E) WATERLINE, (TYP) |
| N | INSTALL (N) WATERLINE, (TYP) |

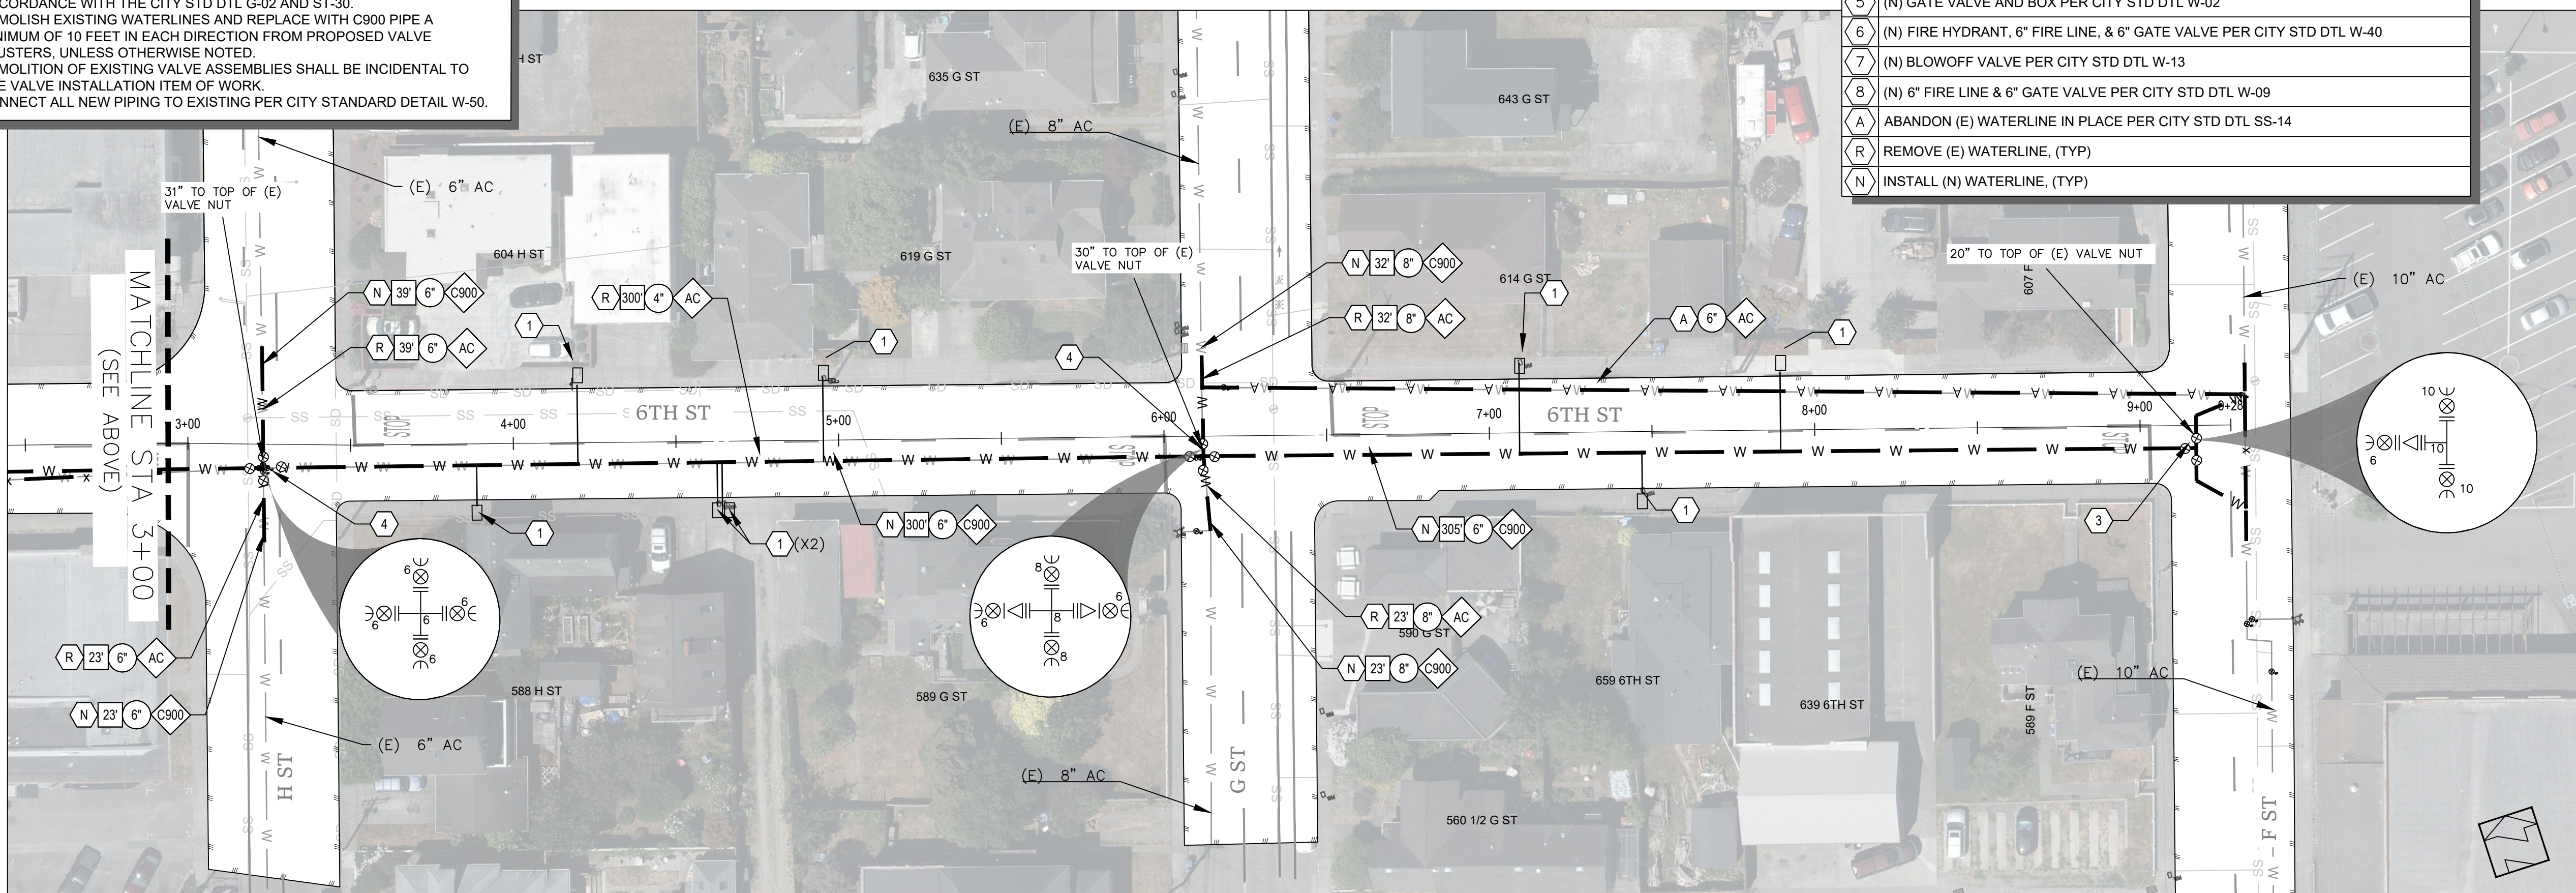

6TH ST (WEST OF K ST) – PLAN VIEW
STATION 0+00 TO 3+21

 6TH ST (EAST OF I ST) – PLAN VIEW
STATION 0+00 TO 9+28

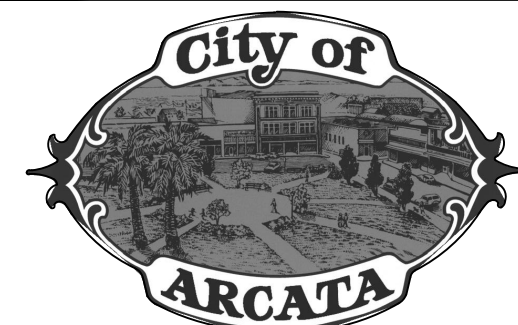

6TH ST

STEEL WATERLINE REPLACEMENT PROJECT

Project Address

VARIOUS LOCATIONS

Designed By

JONATHAN A. KIRCHUBEL

Drawn By

JONATHAN A. KIRCHUBEL

Checked By

DAVID CAISSE

Approved By

NETRA B. KHATRI

Date

JANUARY 2025

Sheet



C-117

Scale

1"=30'

Page

22

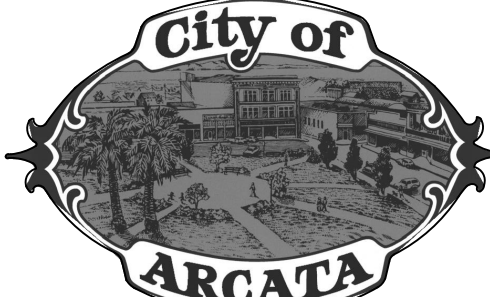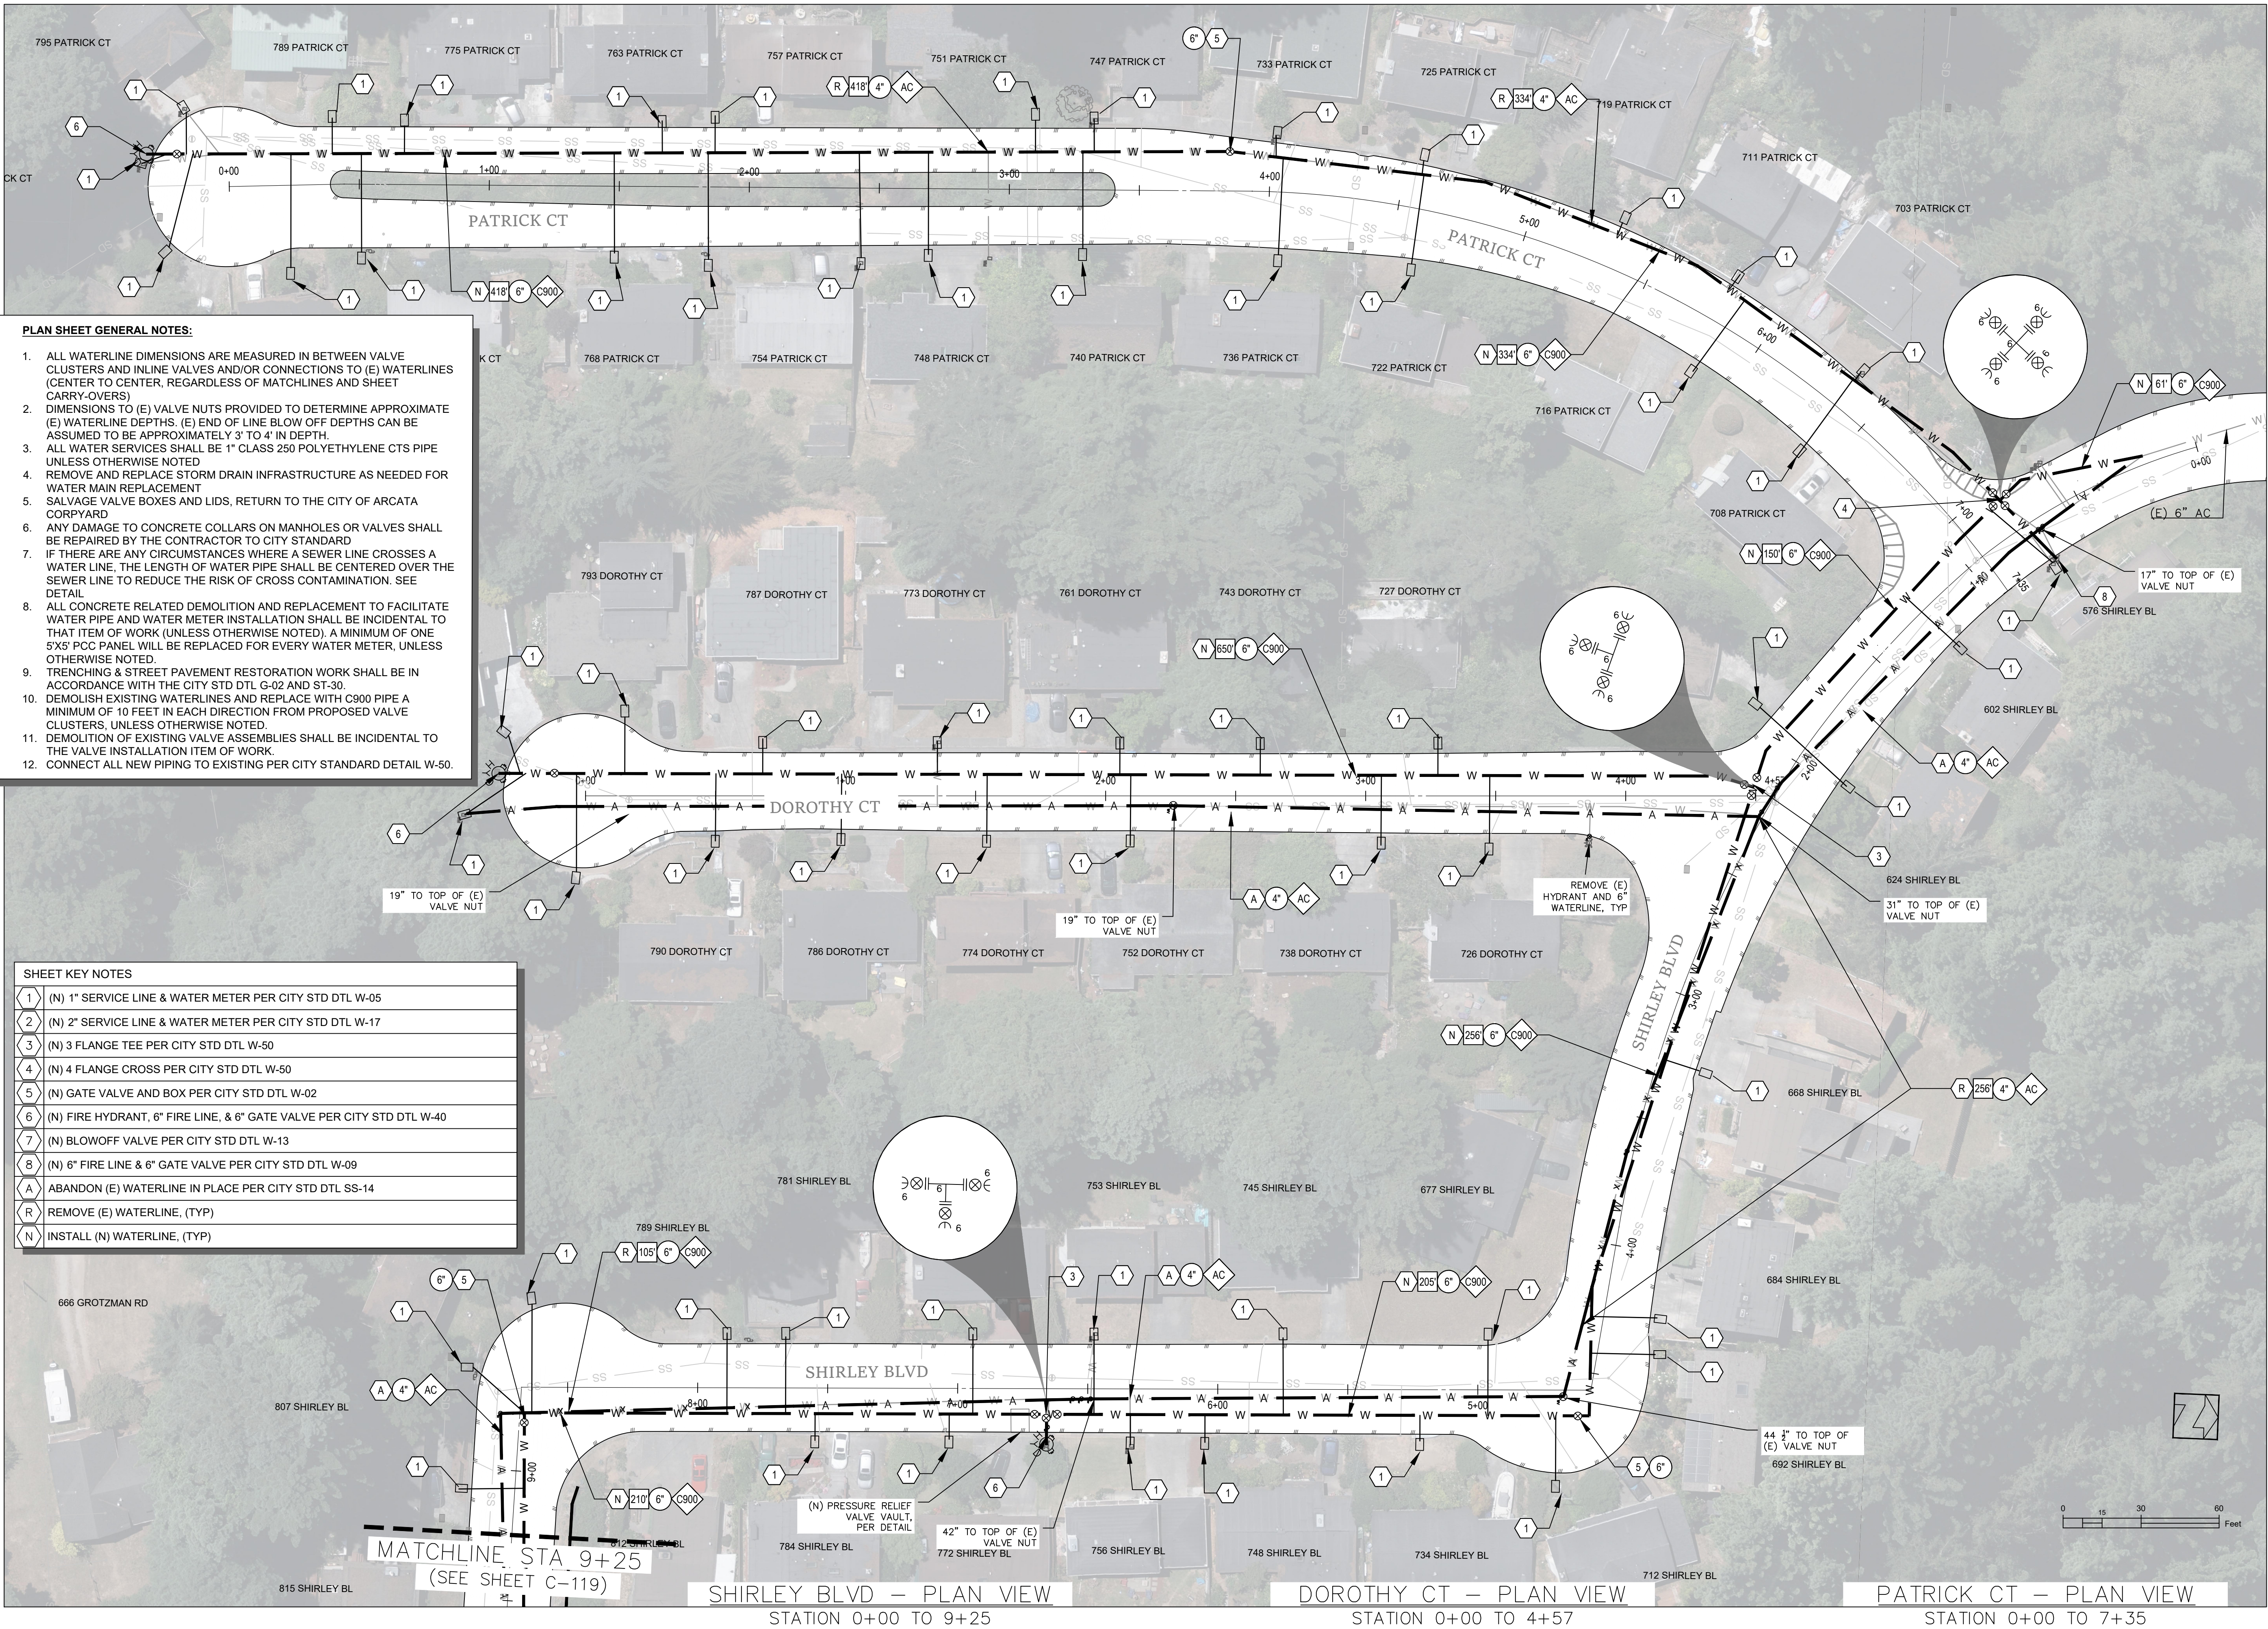


PATRICK CT, DOROTHY COURT, &
SHIRLEY BLVD

STEEL WATERLINE REPLACEMENT PROJECT

Project Address
VARIOUS LOCATIONS

Designed By
JONATHAN A. KIRCHUBEL
Drawn By
JONATHAN A. KIRCHUBEL
Checked By
DAVID CAISSE
Approved By
NETRA B. KHATRI


Date JANUARY 2025	Sheet C-118
Scale 1"=30'	Page 23

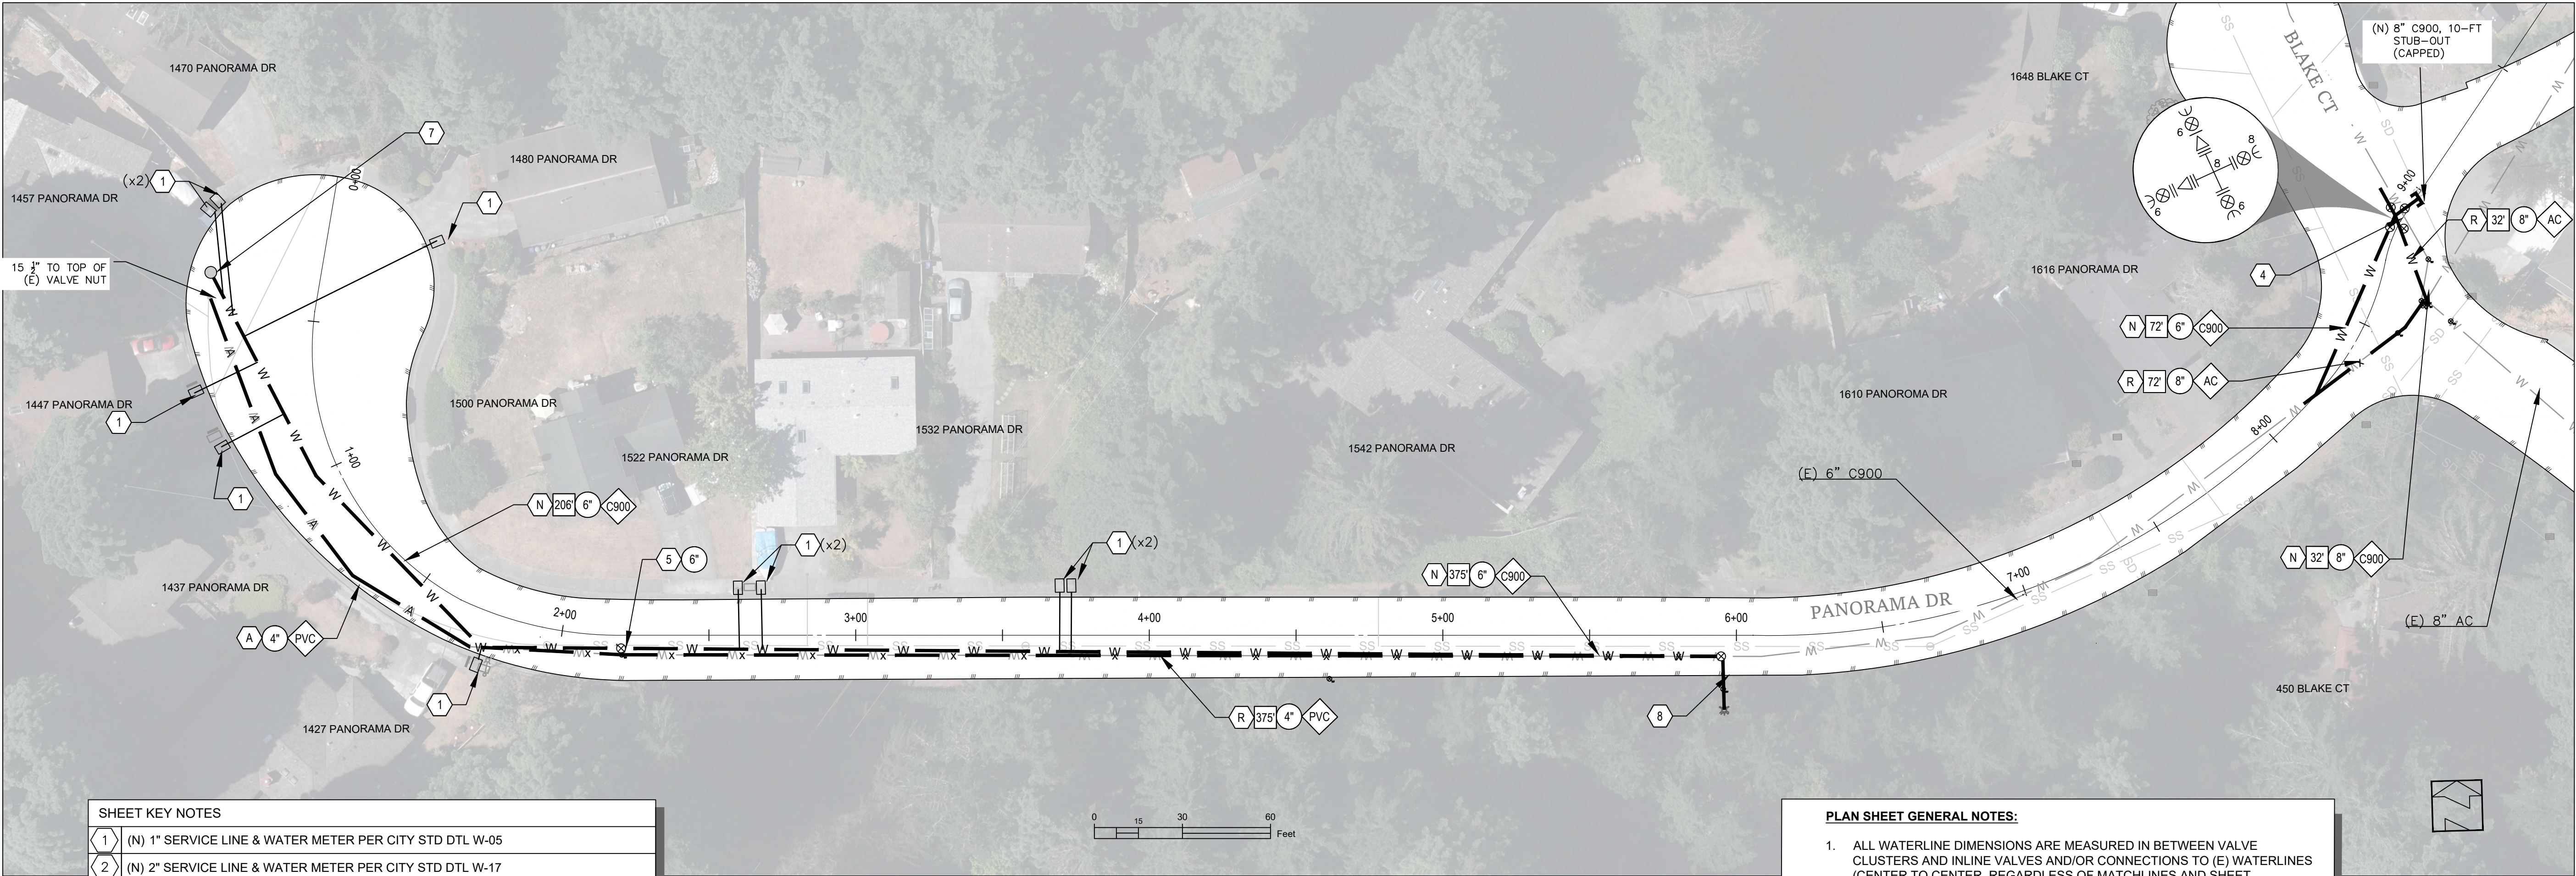

SHEET KEY NOTES	
1	(N) 1" SERVICE LINE & WATER METER PER CITY STD DTL W-05
2	(N) 2" SERVICE LINE & WATER METER PER CITY STD DTL W-17
3	(N) 3 FLANGE TEE PER CITY STD DTL W-50
4	(N) 4 FLANGE CROSS PER CITY STD DTL W-50
5	(N) GATE VALVE AND BOX PER CITY STD DTL W-02
6	(N) FIRE HYDRANT, 6" FIRE LINE, & 6" GATE VALVE PER CITY STD DTL W-40
7	(N) BLOWOFF VALVE PER CITY STD DTL W-13
8	(N) 6" FIRE LINE & 6" GATE VALVE PER CITY STD DTL W-09
A	ABANDON (E) WATERLINE IN PLACE PER CITY STD DTL SS-14
R	REMOVE (E) WATERLINE, (TYP)
N	INSTALL (N) WATERLINE, (TYP)

PANORAMA DR – PLAN VIEW
STATION 0+00 TO 9+00

- PLAN SHEET GENERAL NOTES:**
- ALL WATERLINE DIMENSIONS ARE MEASURED IN BETWEEN VALVE CLUSTERS AND INLINE VALVES AND/OR CONNECTIONS TO (E) WATERLINES (CENTER TO CENTER, REGARDLESS OF MATCHLINES AND SHEET CARRY-OVERS)
 - DIMENSIONS TO (E) VALVE NUTS PROVIDED TO DETERMINE APPROXIMATE (E) WATERLINE DEPTHS. (E) END OF LINE BLOW OFF DEPTHS CAN BE ASSUMED TO BE APPROXIMATELY 3' TO 4' IN DEPTH.
 - ALL WATER SERVICES SHALL BE 1" CLASS 250 POLYETHYLENE CTS PIPE UNLESS OTHERWISE NOTED
 - REMOVE AND REPLACE STORM DRAIN INFRASTRUCTURE AS NEEDED FOR WATER MAIN REPLACEMENT
 - SALVAGE VALVE BOXES AND LIDS, RETURN TO THE CITY OF ARCATA CORPYARD
 - ANY DAMAGE TO CONCRETE COLLARS ON MANHOLES OR VALVES SHALL BE REPAIRED BY THE CONTRACTOR TO CITY STANDARD
 - IF THERE ARE ANY CIRCUMSTANCES WHERE A SEWER LINE CROSSES A WATER LINE, THE LENGTH OF WATER PIPE SHALL BE CENTERED OVER THE SEWER LINE TO REDUCE THE RISK OF CROSS CONTAMINATION. SEE DETAIL.
 - ALL CONCRETE RELATED DEMOLITION AND REPLACEMENT TO FACILITATE WATER PIPE AND WATER METER INSTALLATION SHALL BE INCIDENTAL TO THAT ITEM OF WORK (UNLESS OTHERWISE NOTED), A MINIMUM OF ONE 5'X5' PCC PANEL WILL BE REPLACED FOR EVERY WATER METER, UNLESS OTHERWISE NOTED.
 - TRENCHING & STREET PAVEMENT RESTORATION WORK SHALL BE IN ACCORDANCE WITH THE CITY STD DTL G-02 AND ST-30.
 - DEMOLISH EXISTING WATERLINES AND REPLACE WITH C900 PIPE A MINIMUM OF 10 FEET IN EACH DIRECTION FROM PROPOSED VALVE CLUSTERS, UNLESS OTHERWISE NOTED.
 - DEMOLITION OF EXISTING VALVE ASSEMBLIES SHALL BE INCIDENTAL TO THE VALVE INSTALLATION ITEM OF WORK.
 - CONNECT ALL NEW PIPING TO EXISTING PER CITY STANDARD DETAIL W-50.





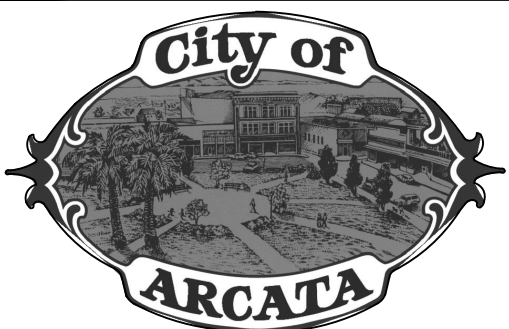


PANORAMA DR

STEEL WATERLINE REPLACEMENT PROJECT

Project Address	
VARIOUS LOCATIONS	
Designed By	JONATHAN A. KIRCHUBEL
Drawn By	JONATHAN A. KIRCHUBEL
Checked By	DAVID CAISSE
Approved By	NETRA B. KHATRI

Date	JANUARY 2025	Sheet	C-120
Scale	1"=30'	Page	25

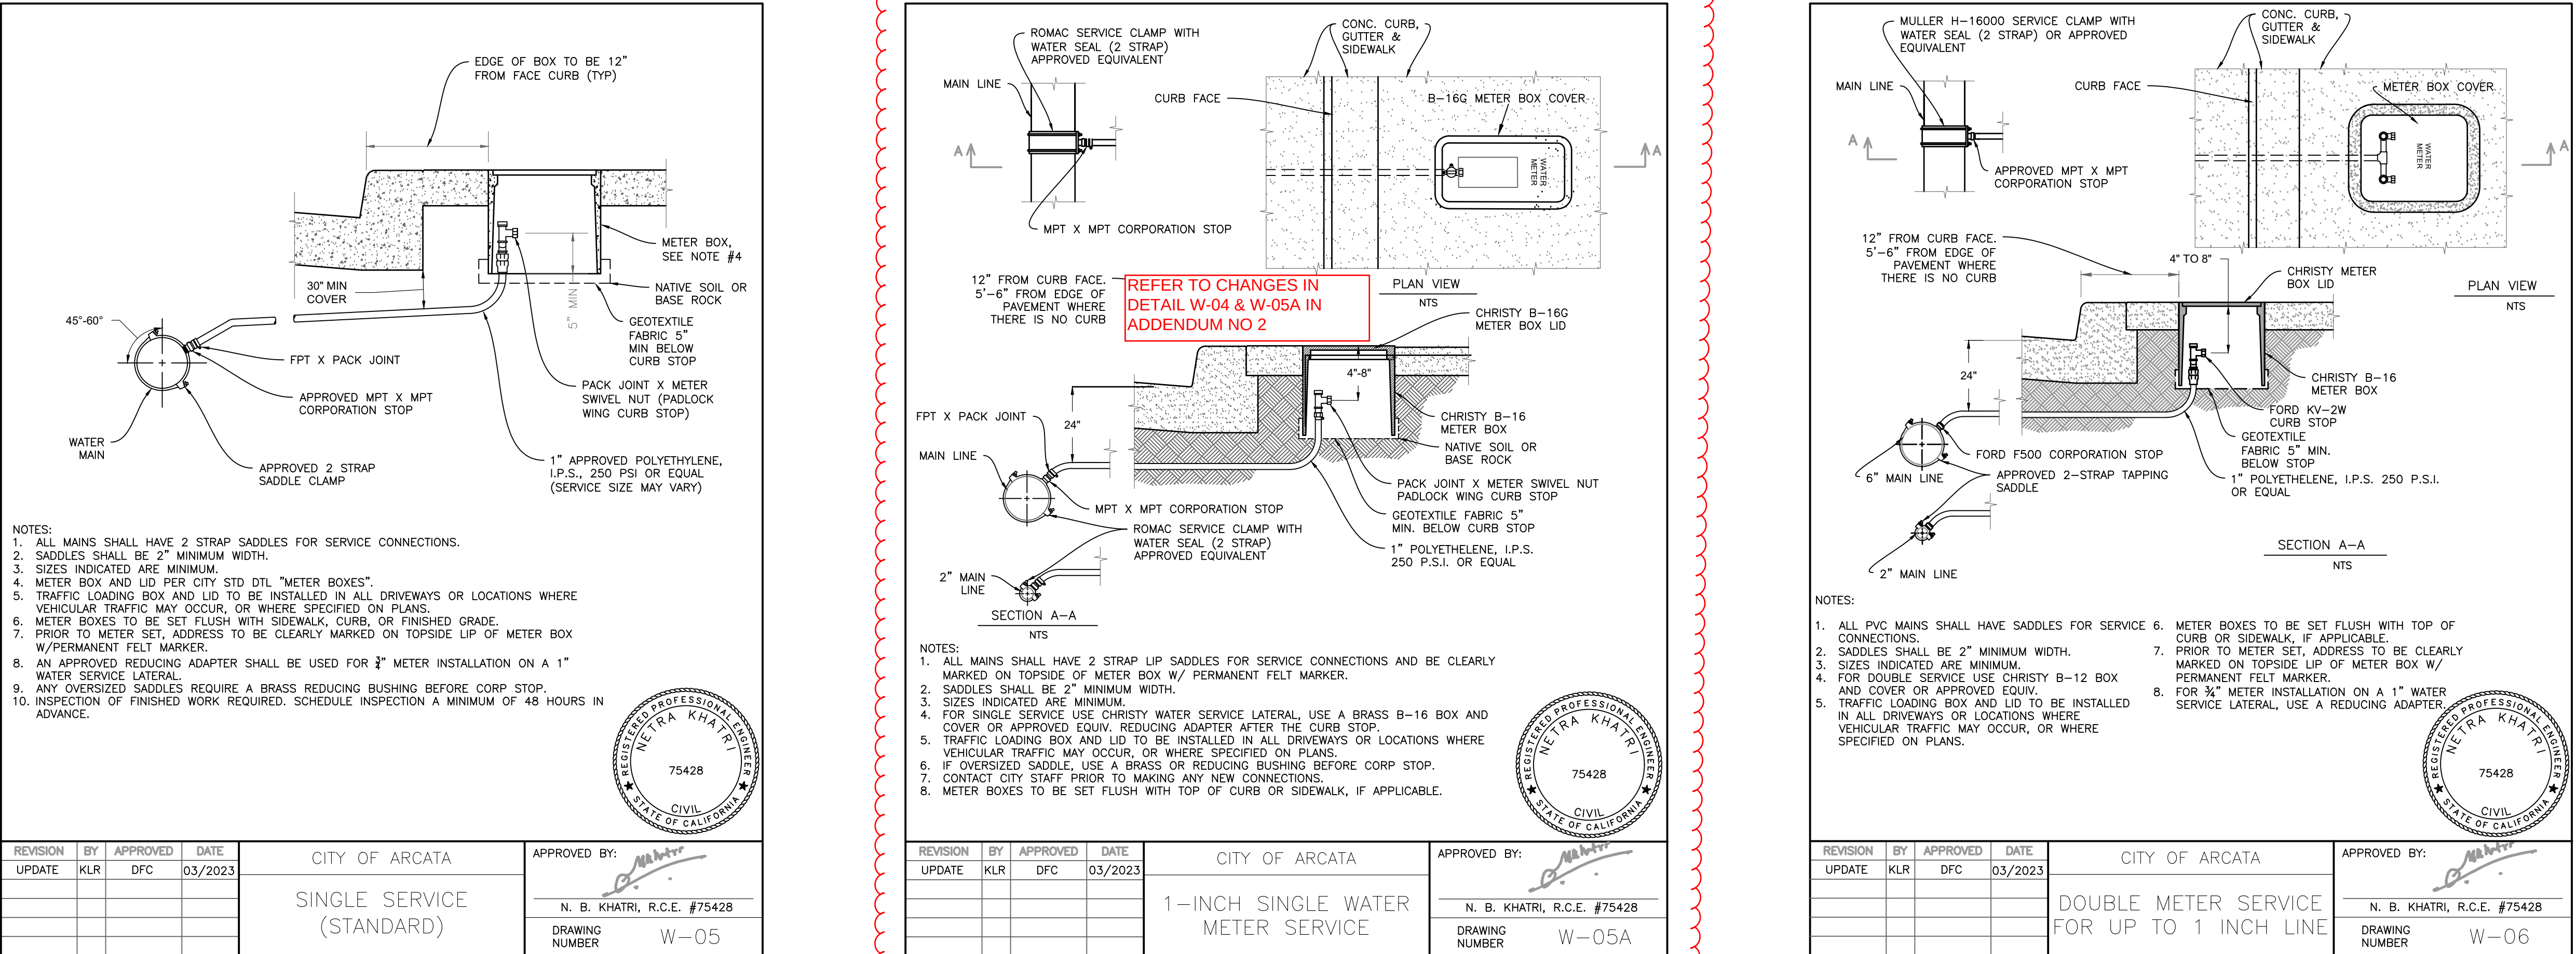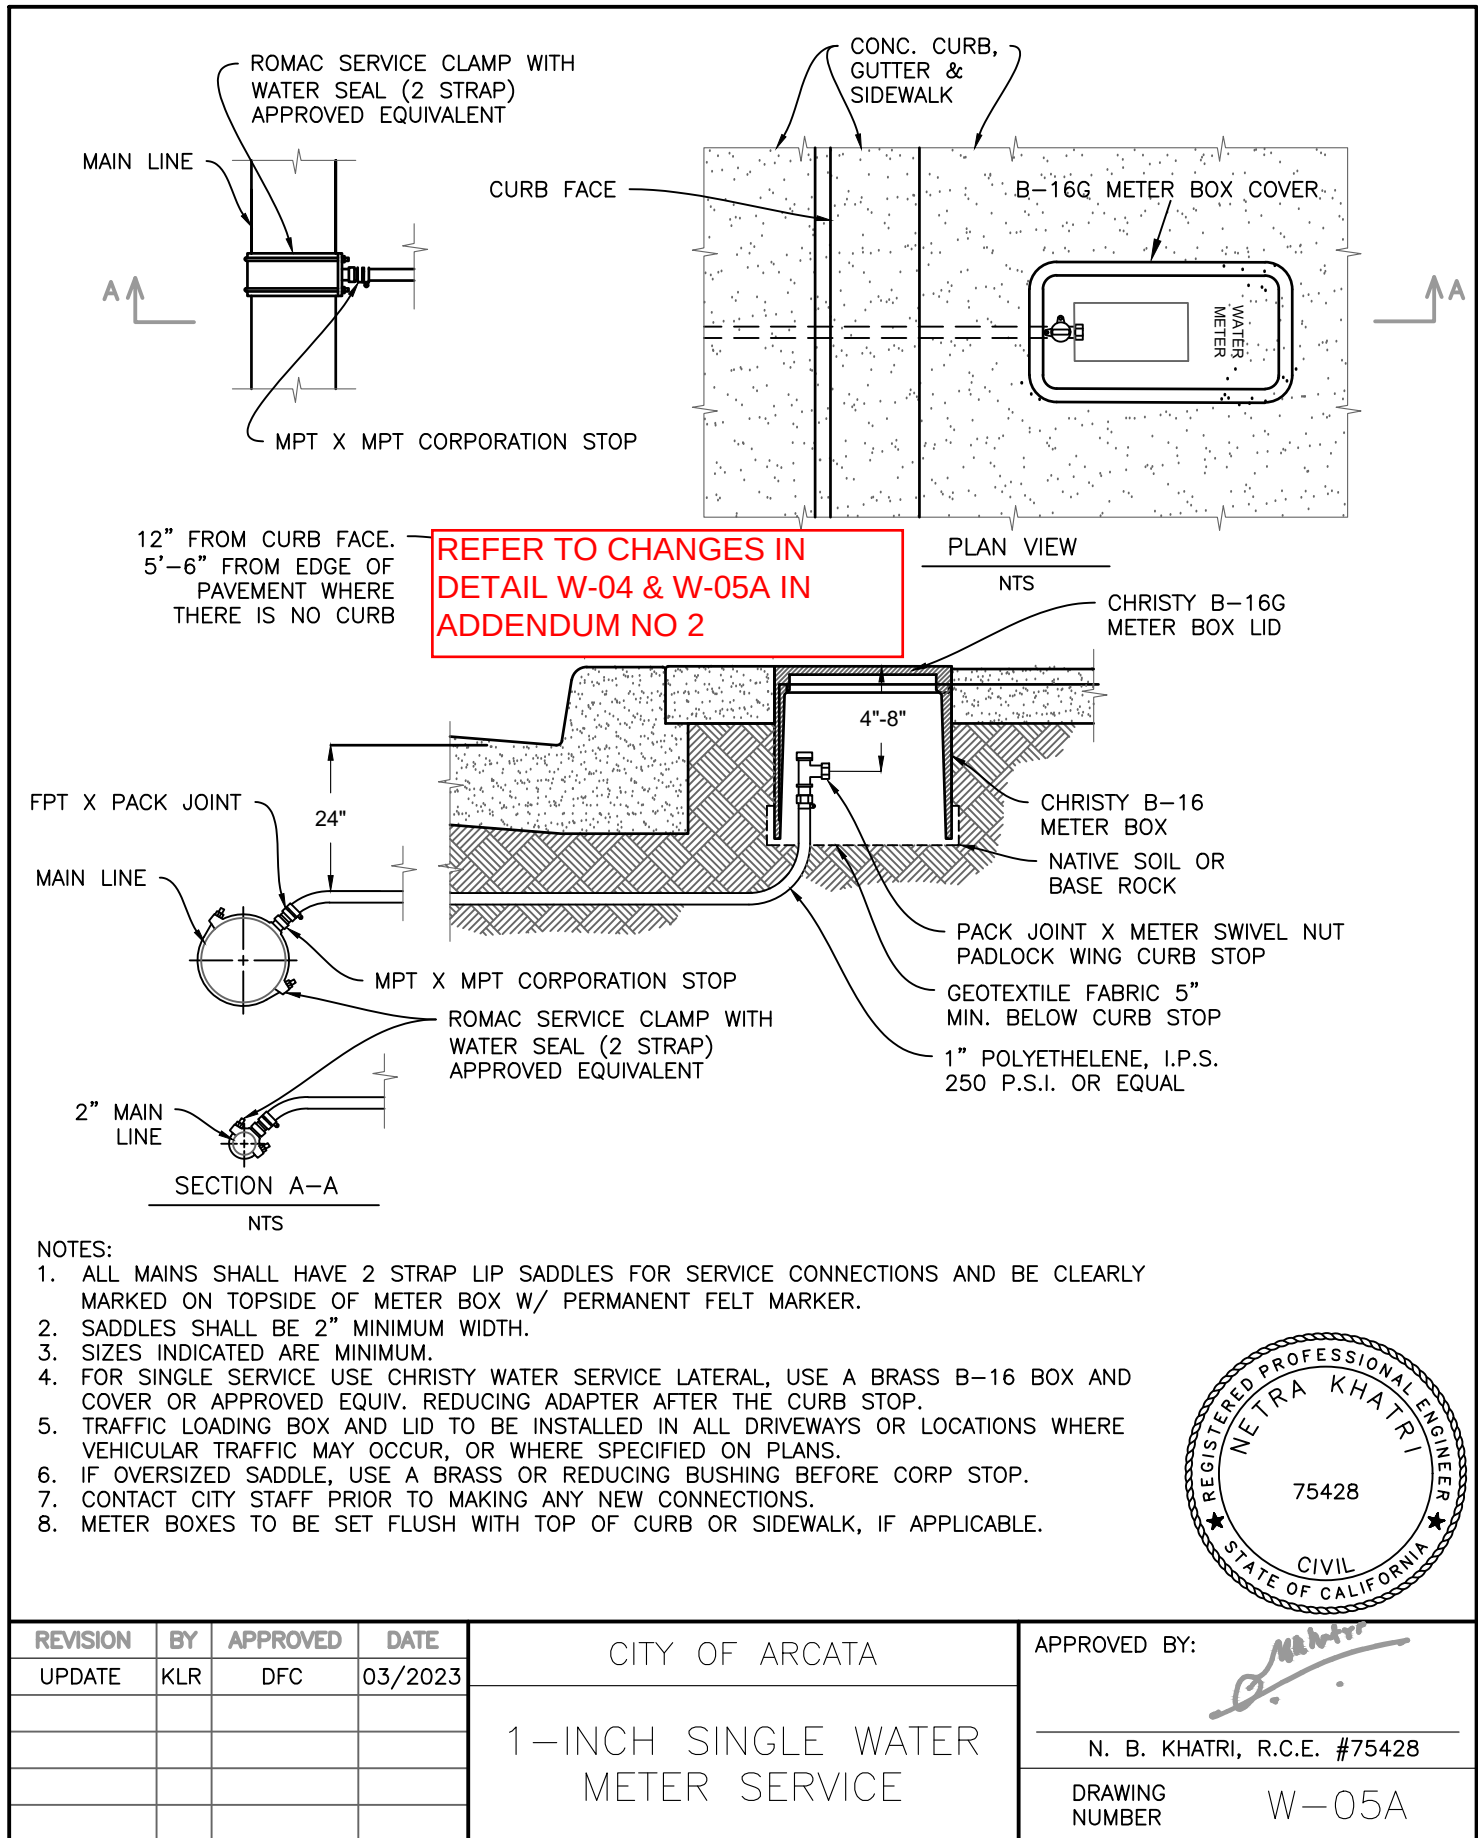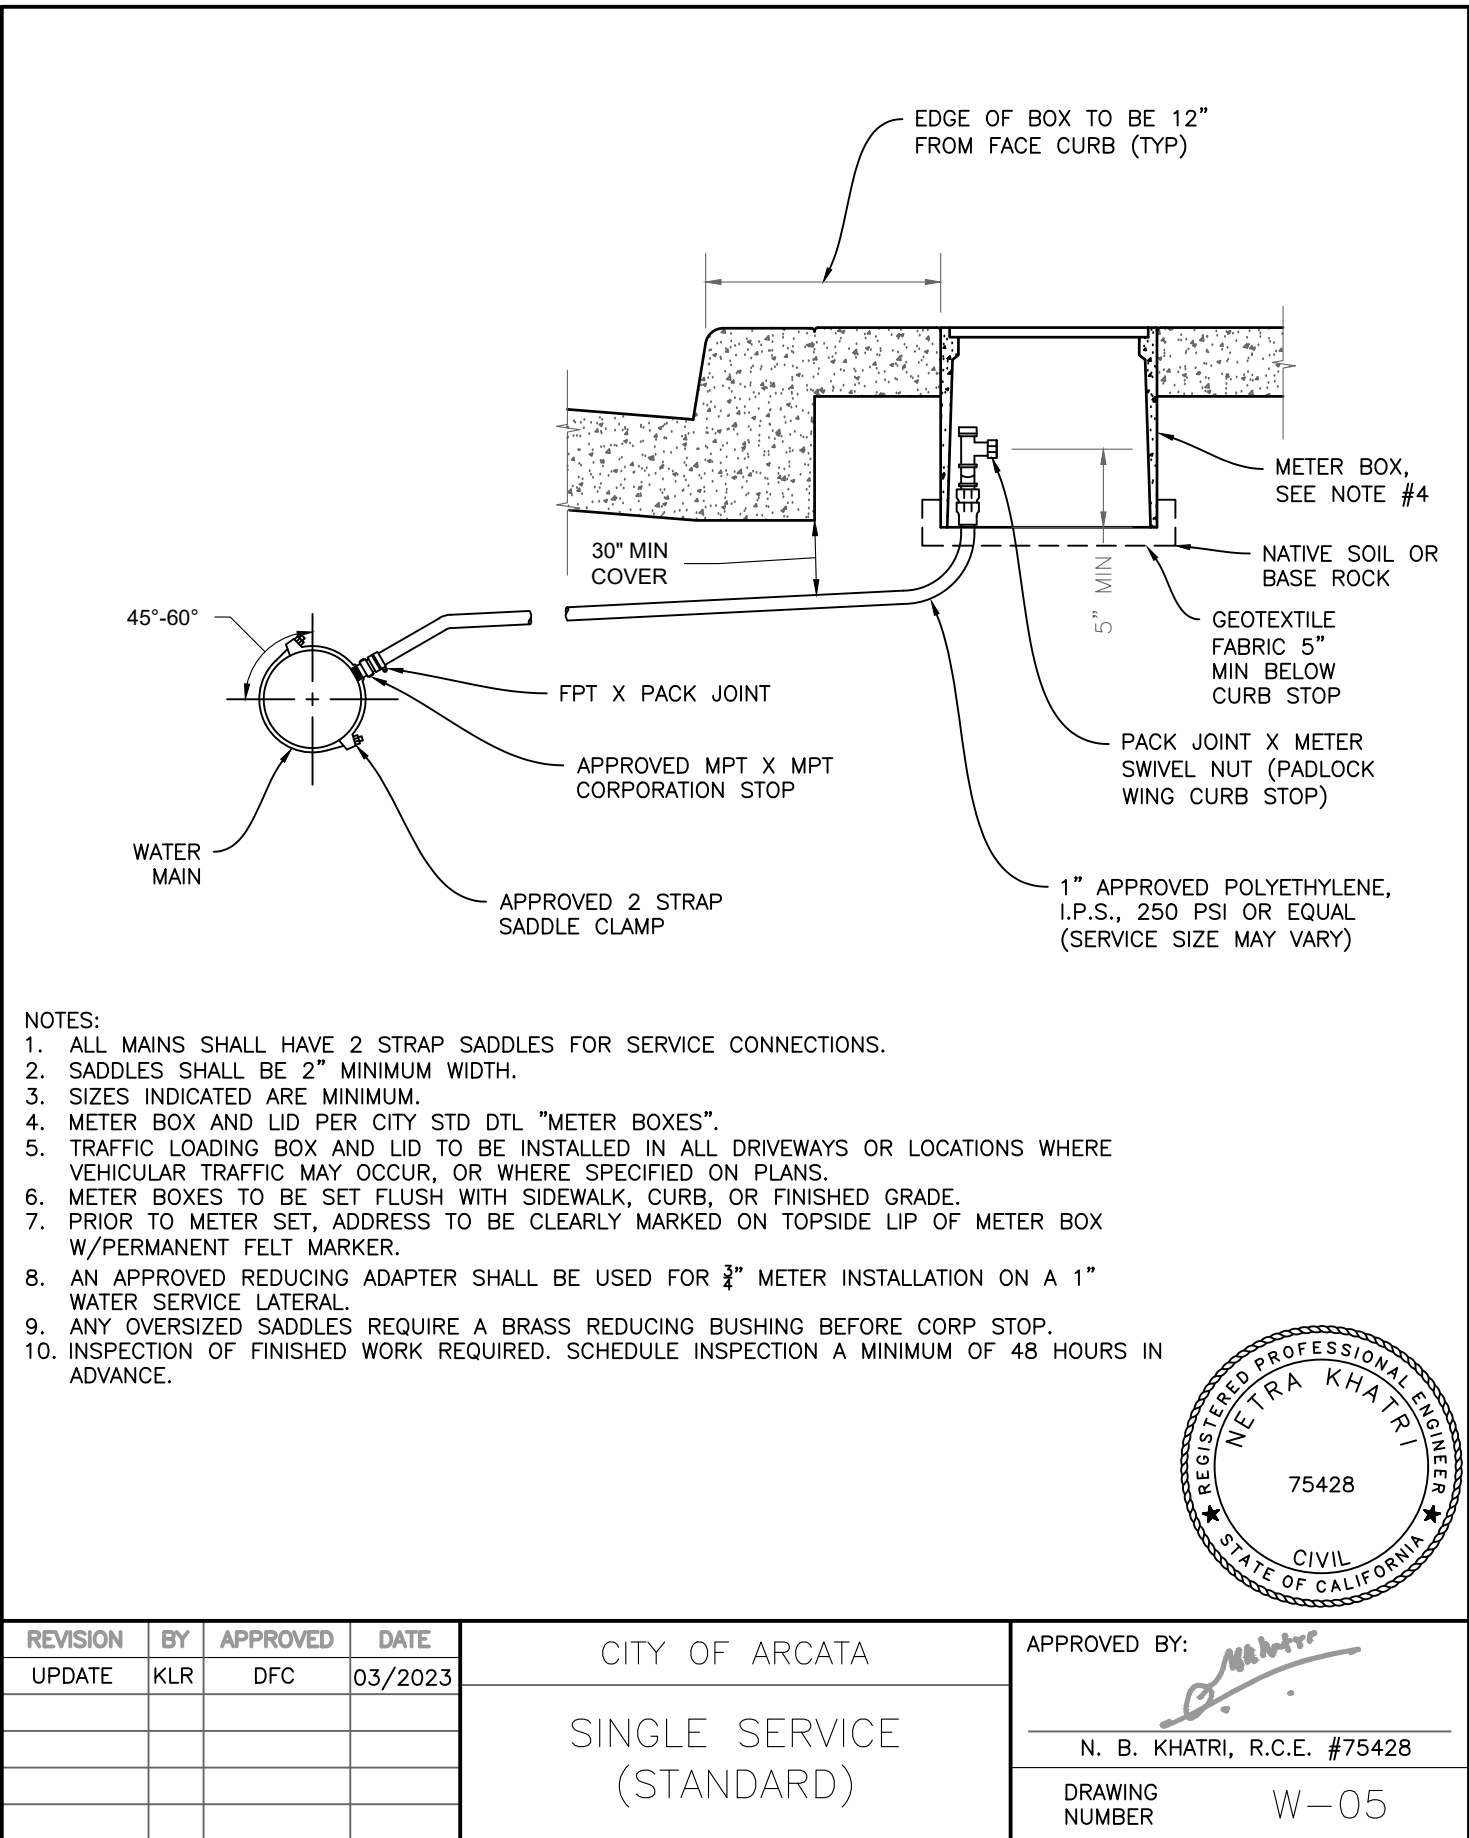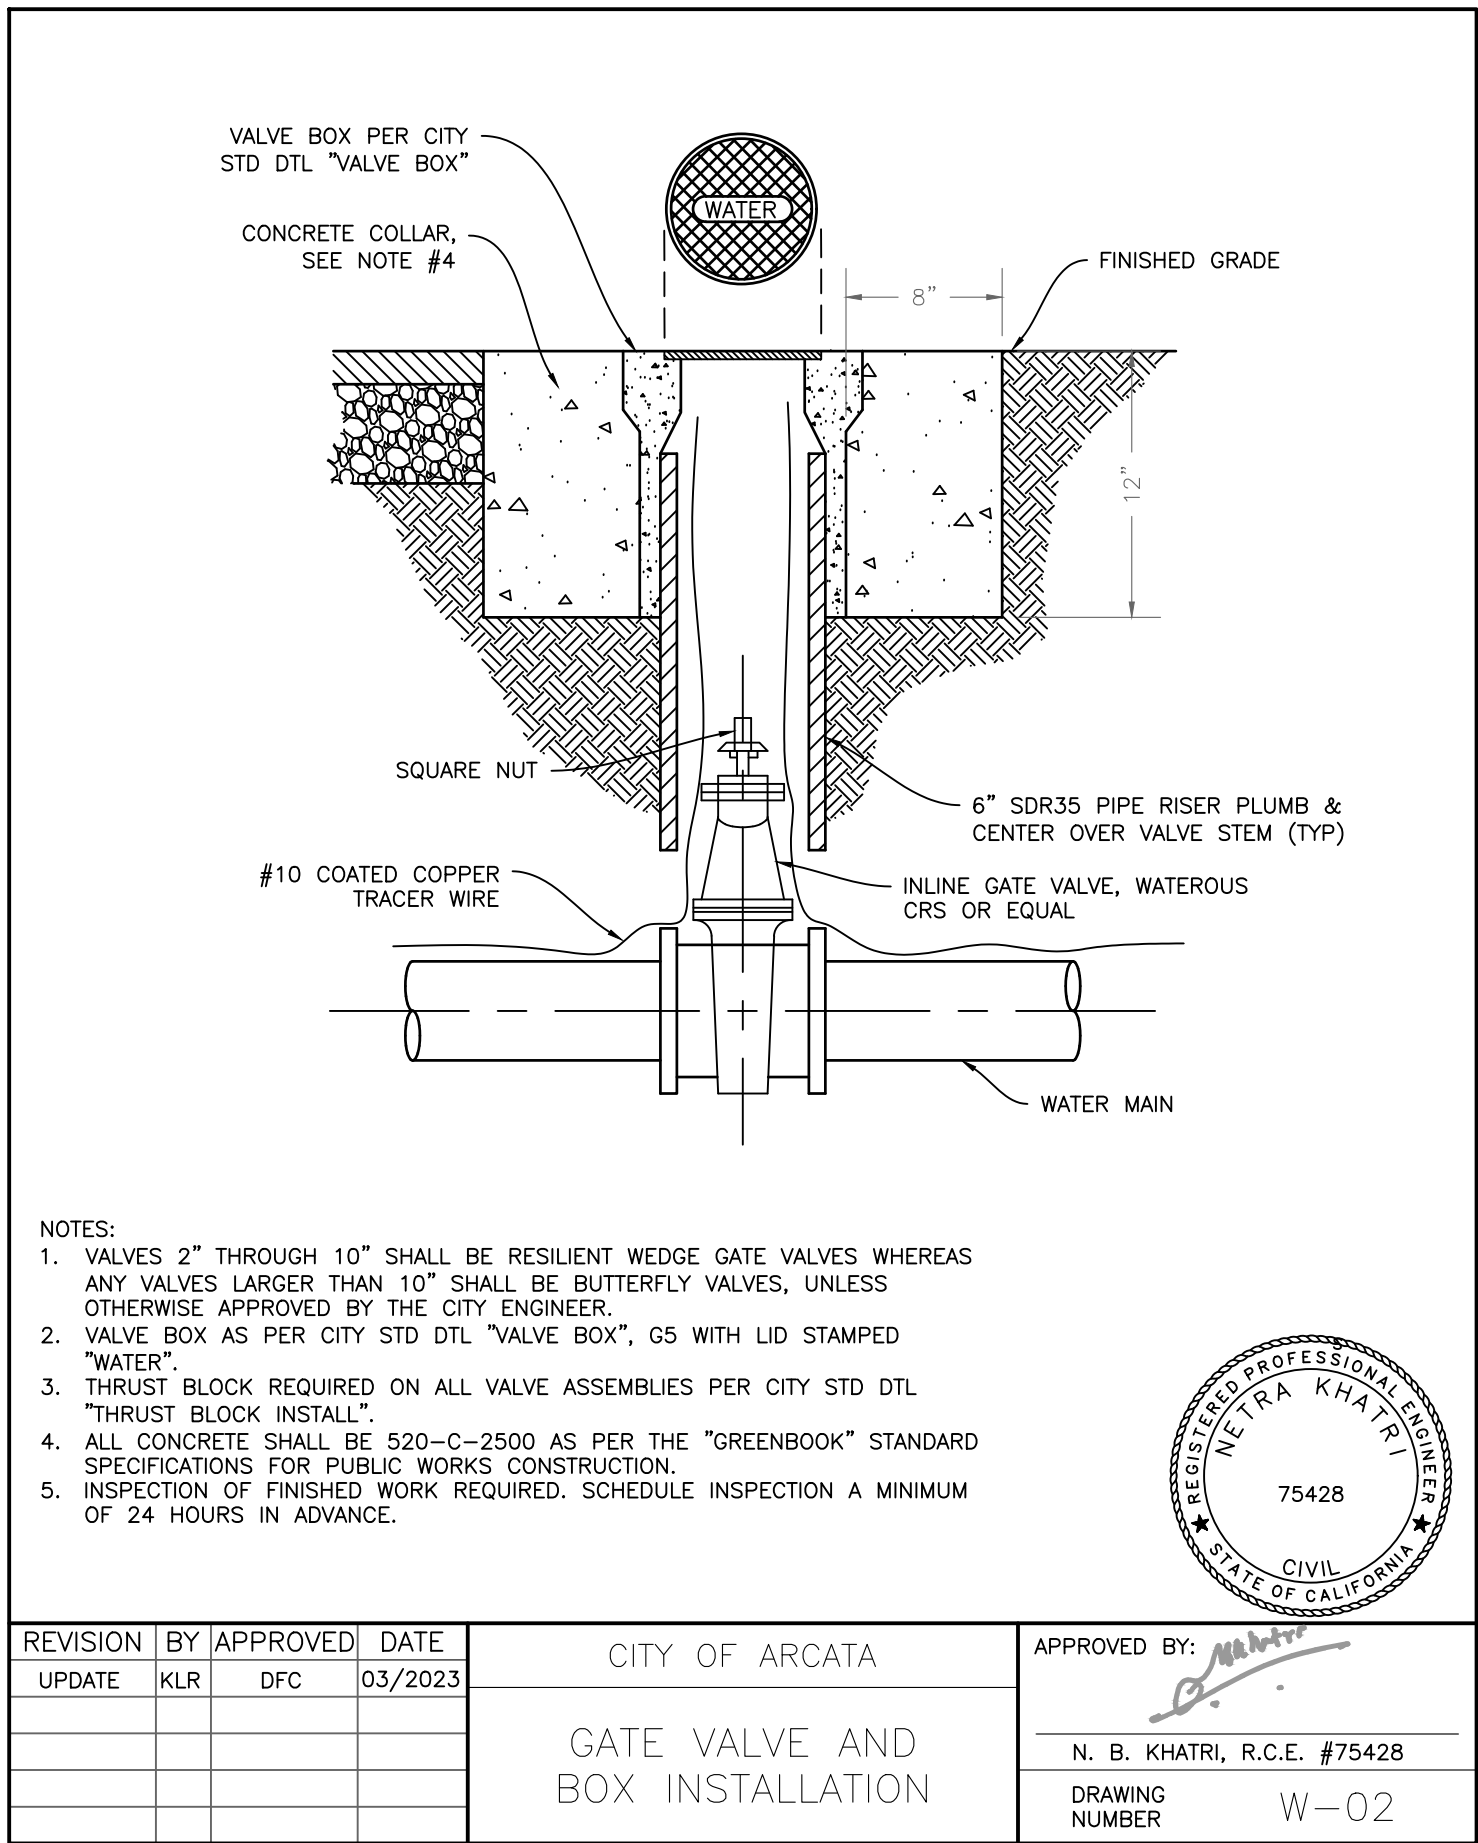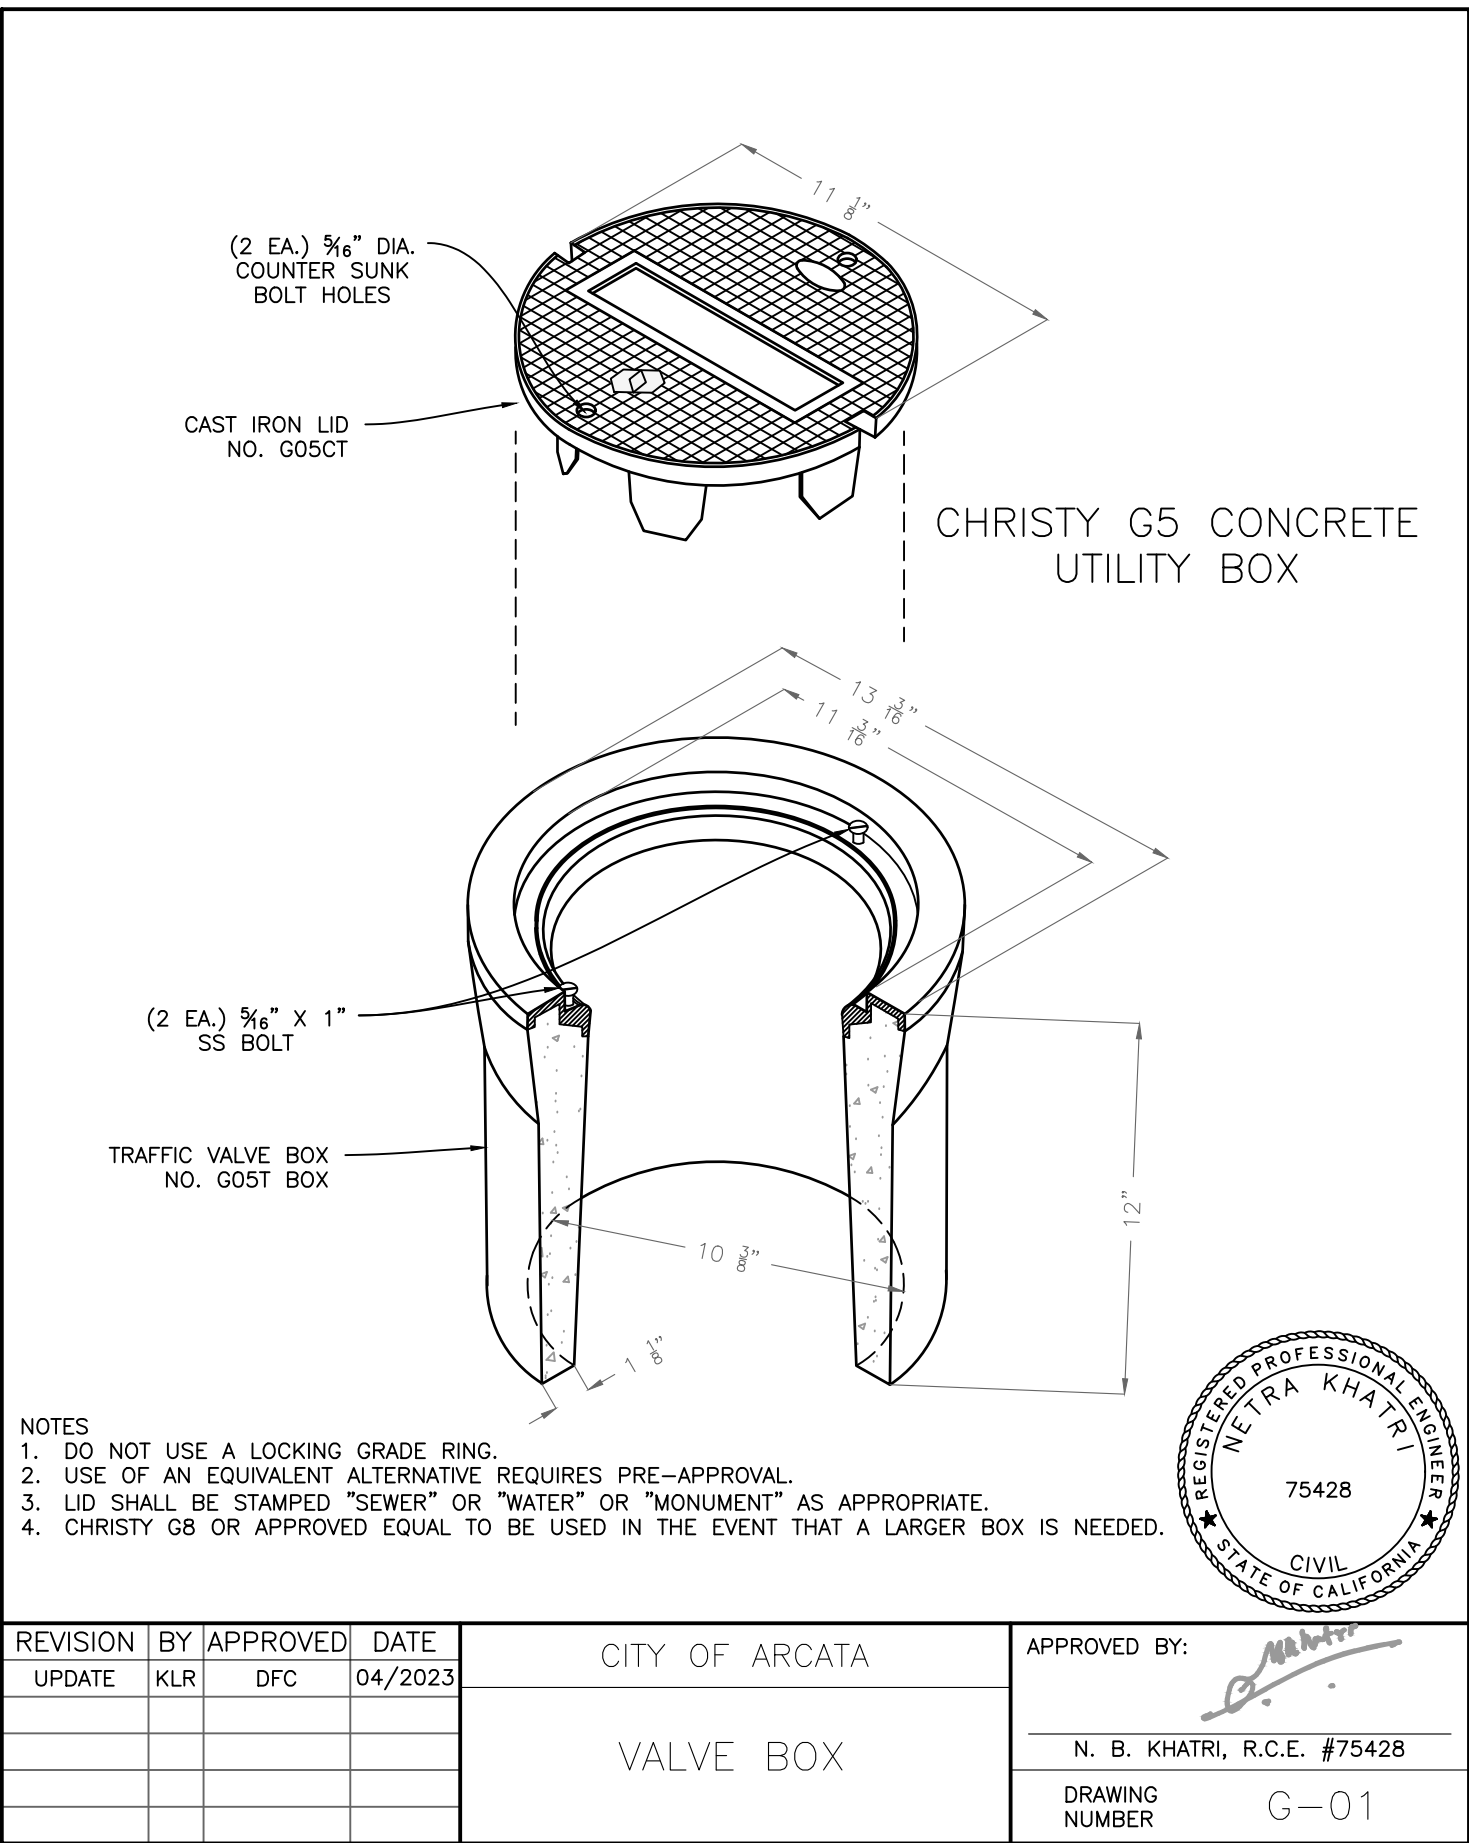

REGISTERED PROFESSIONAL ENGINEER
NETRA KHATRI
75428
CIVIL
STATE OF CALIFORNIA

City of
ARCATA








STANDARD DETAILS
STEEL WATERLINE REPLACEMENT PROJECT

Project Address
VARIOUS LOCATIONS

Designed By
JONATHAN A. KIRCHUBEL
Drawn By
JONATHAN A. KIRCHUBEL
Checked By
DAVID CAISSE
Approved By
NETRA B. KHATRI

Date
JANUARY 2025
Scale
N/A

Sheet
C-501
Page
26

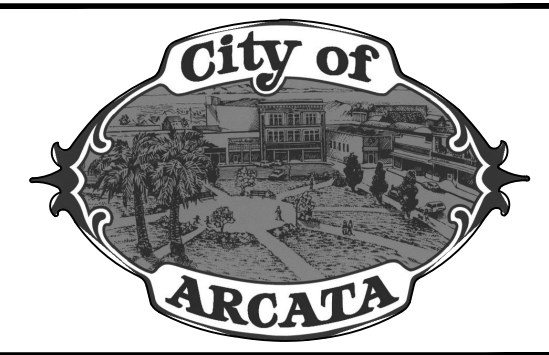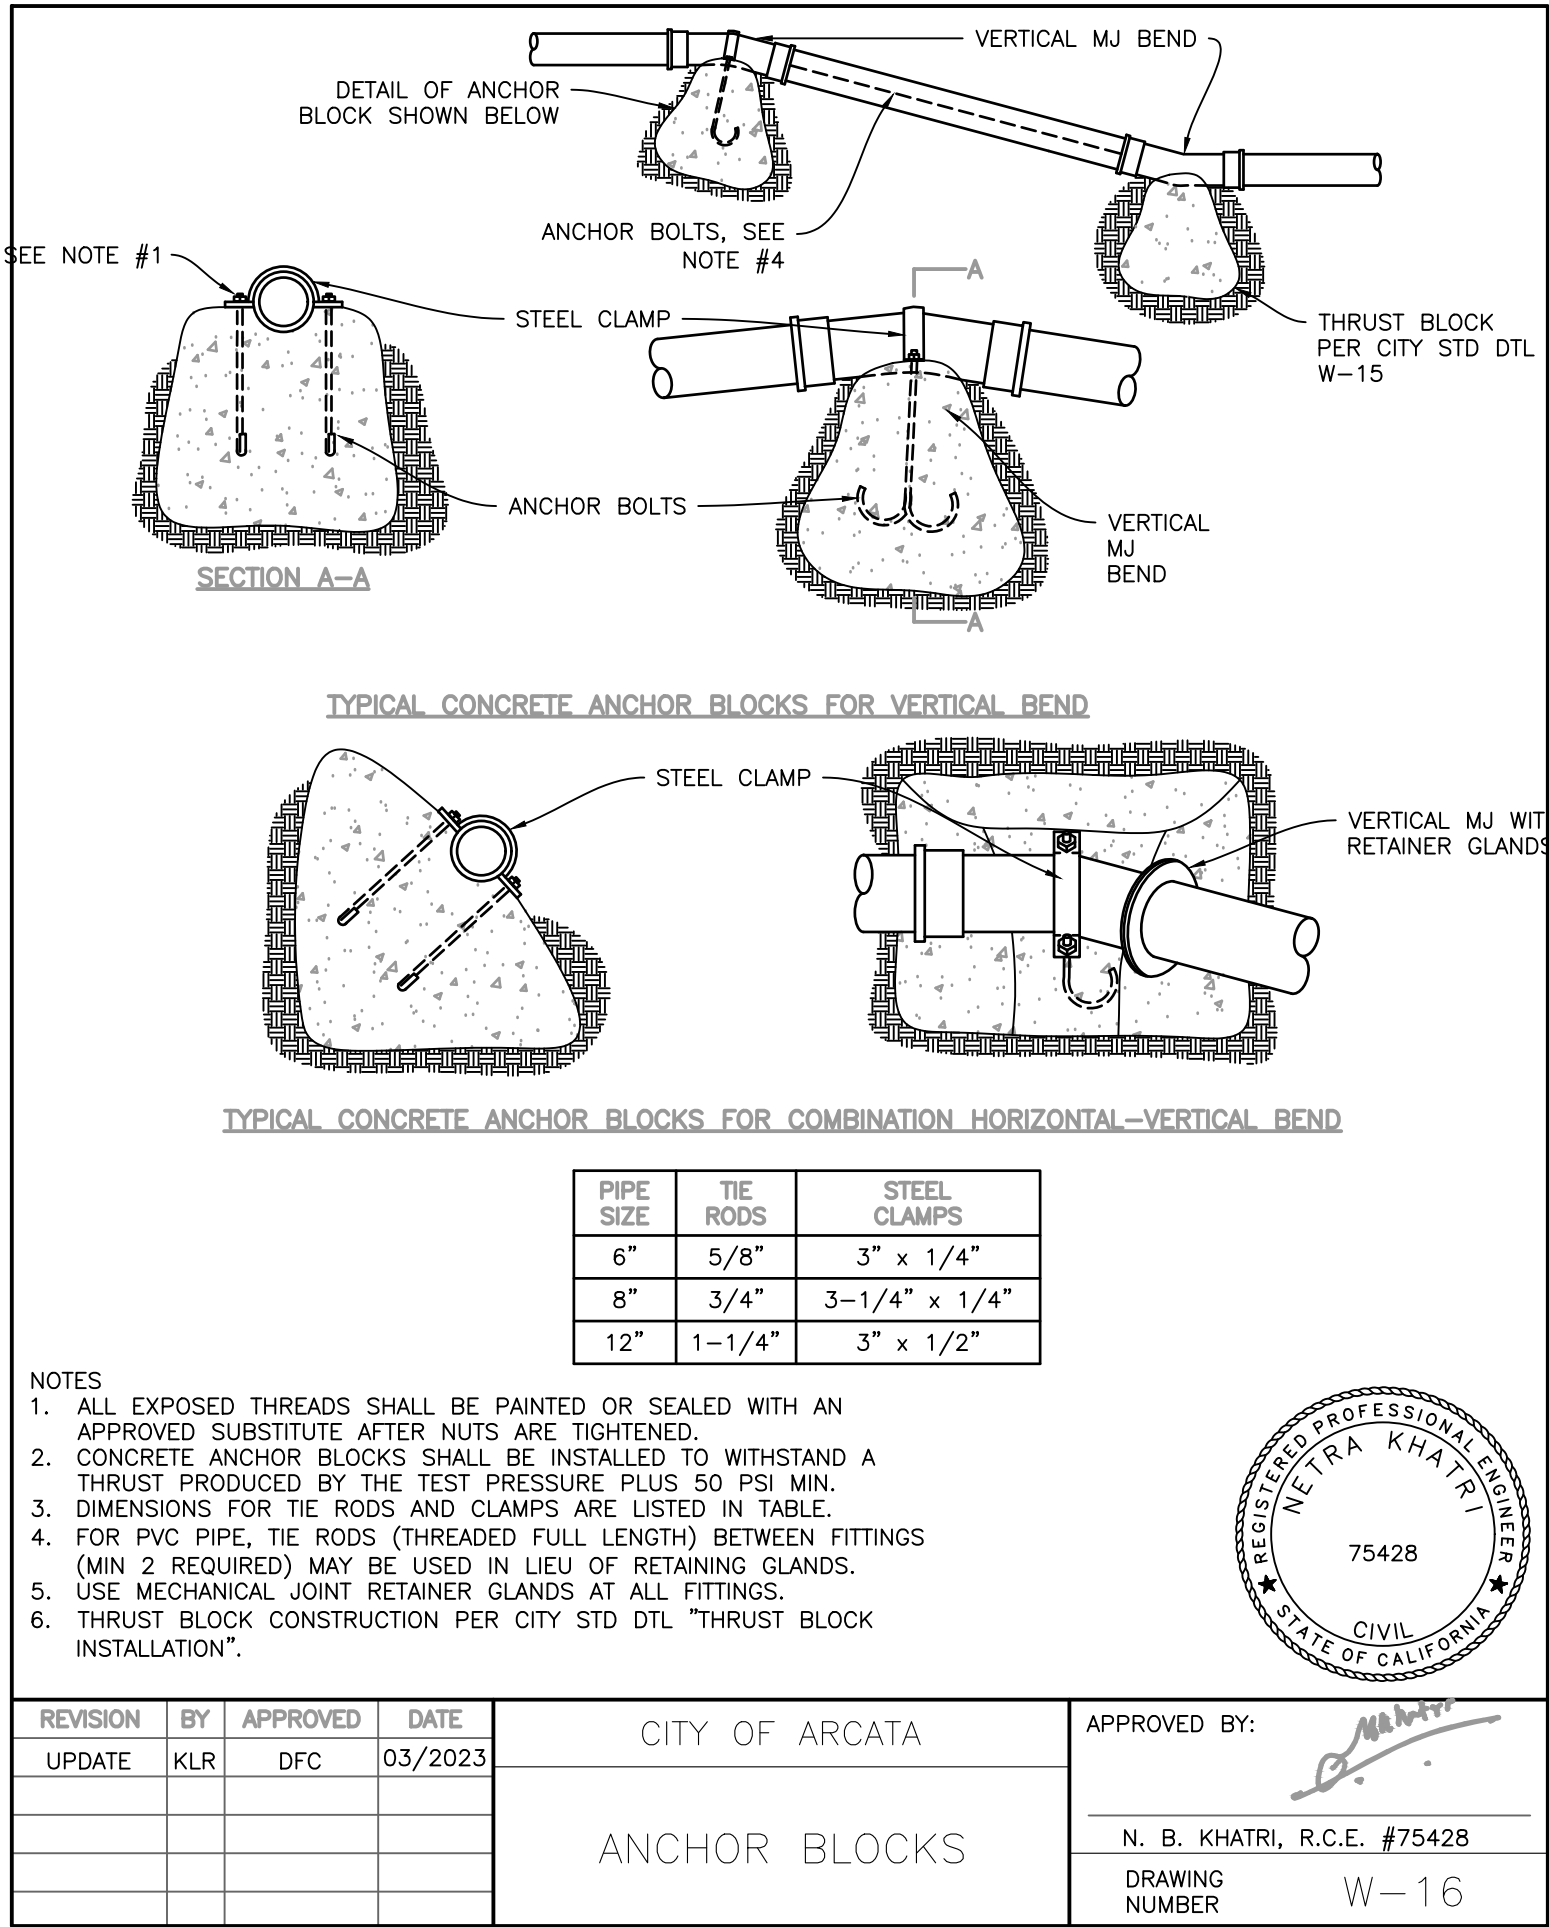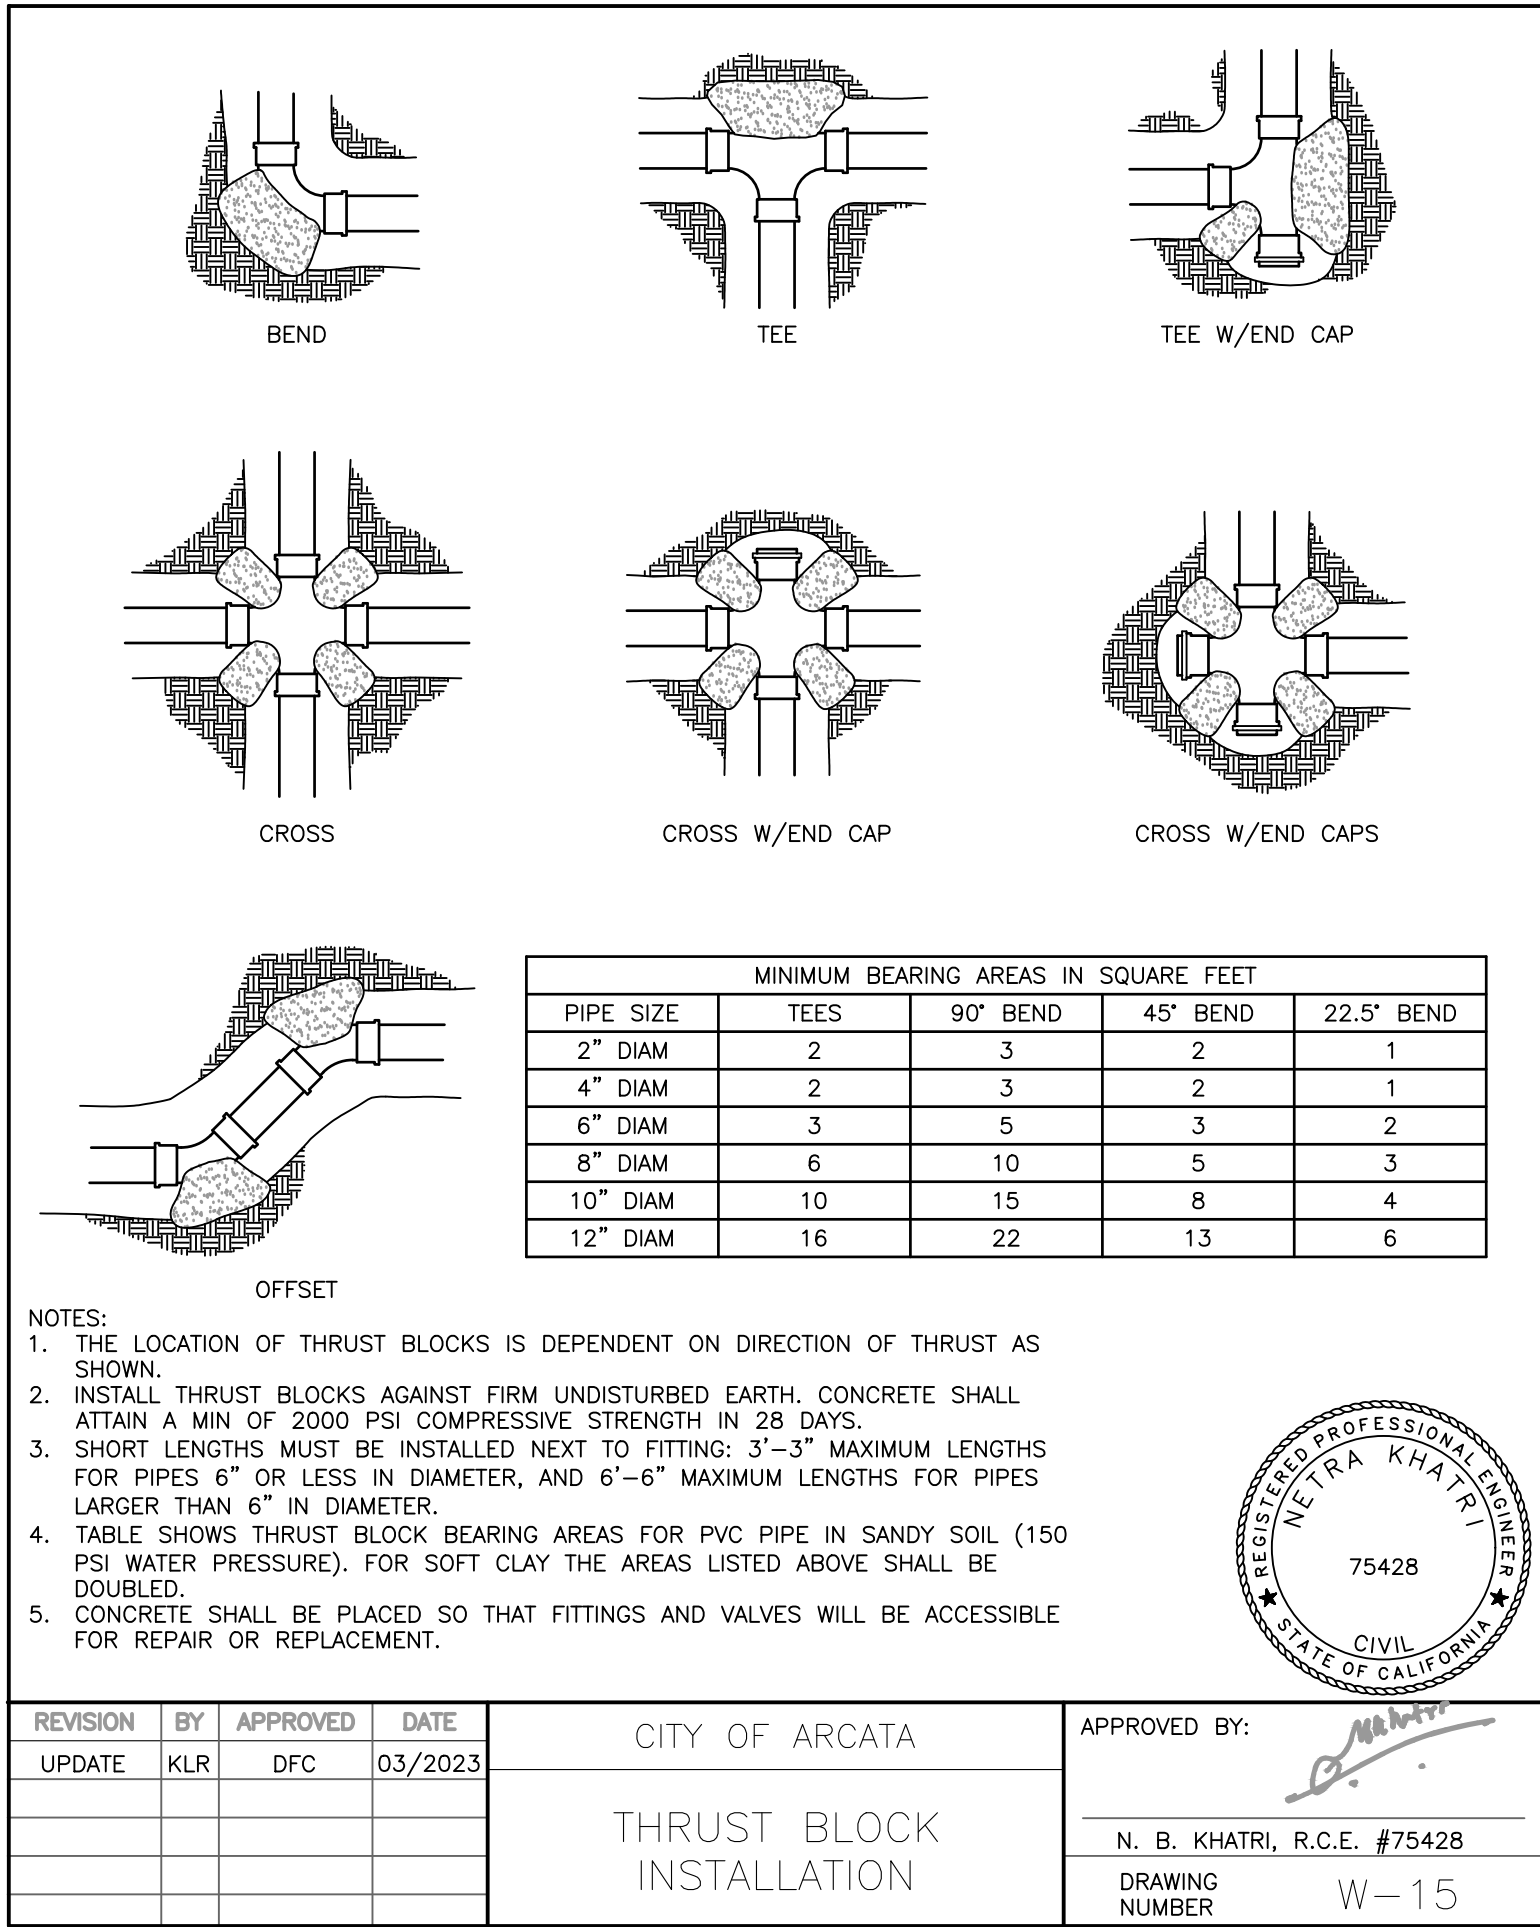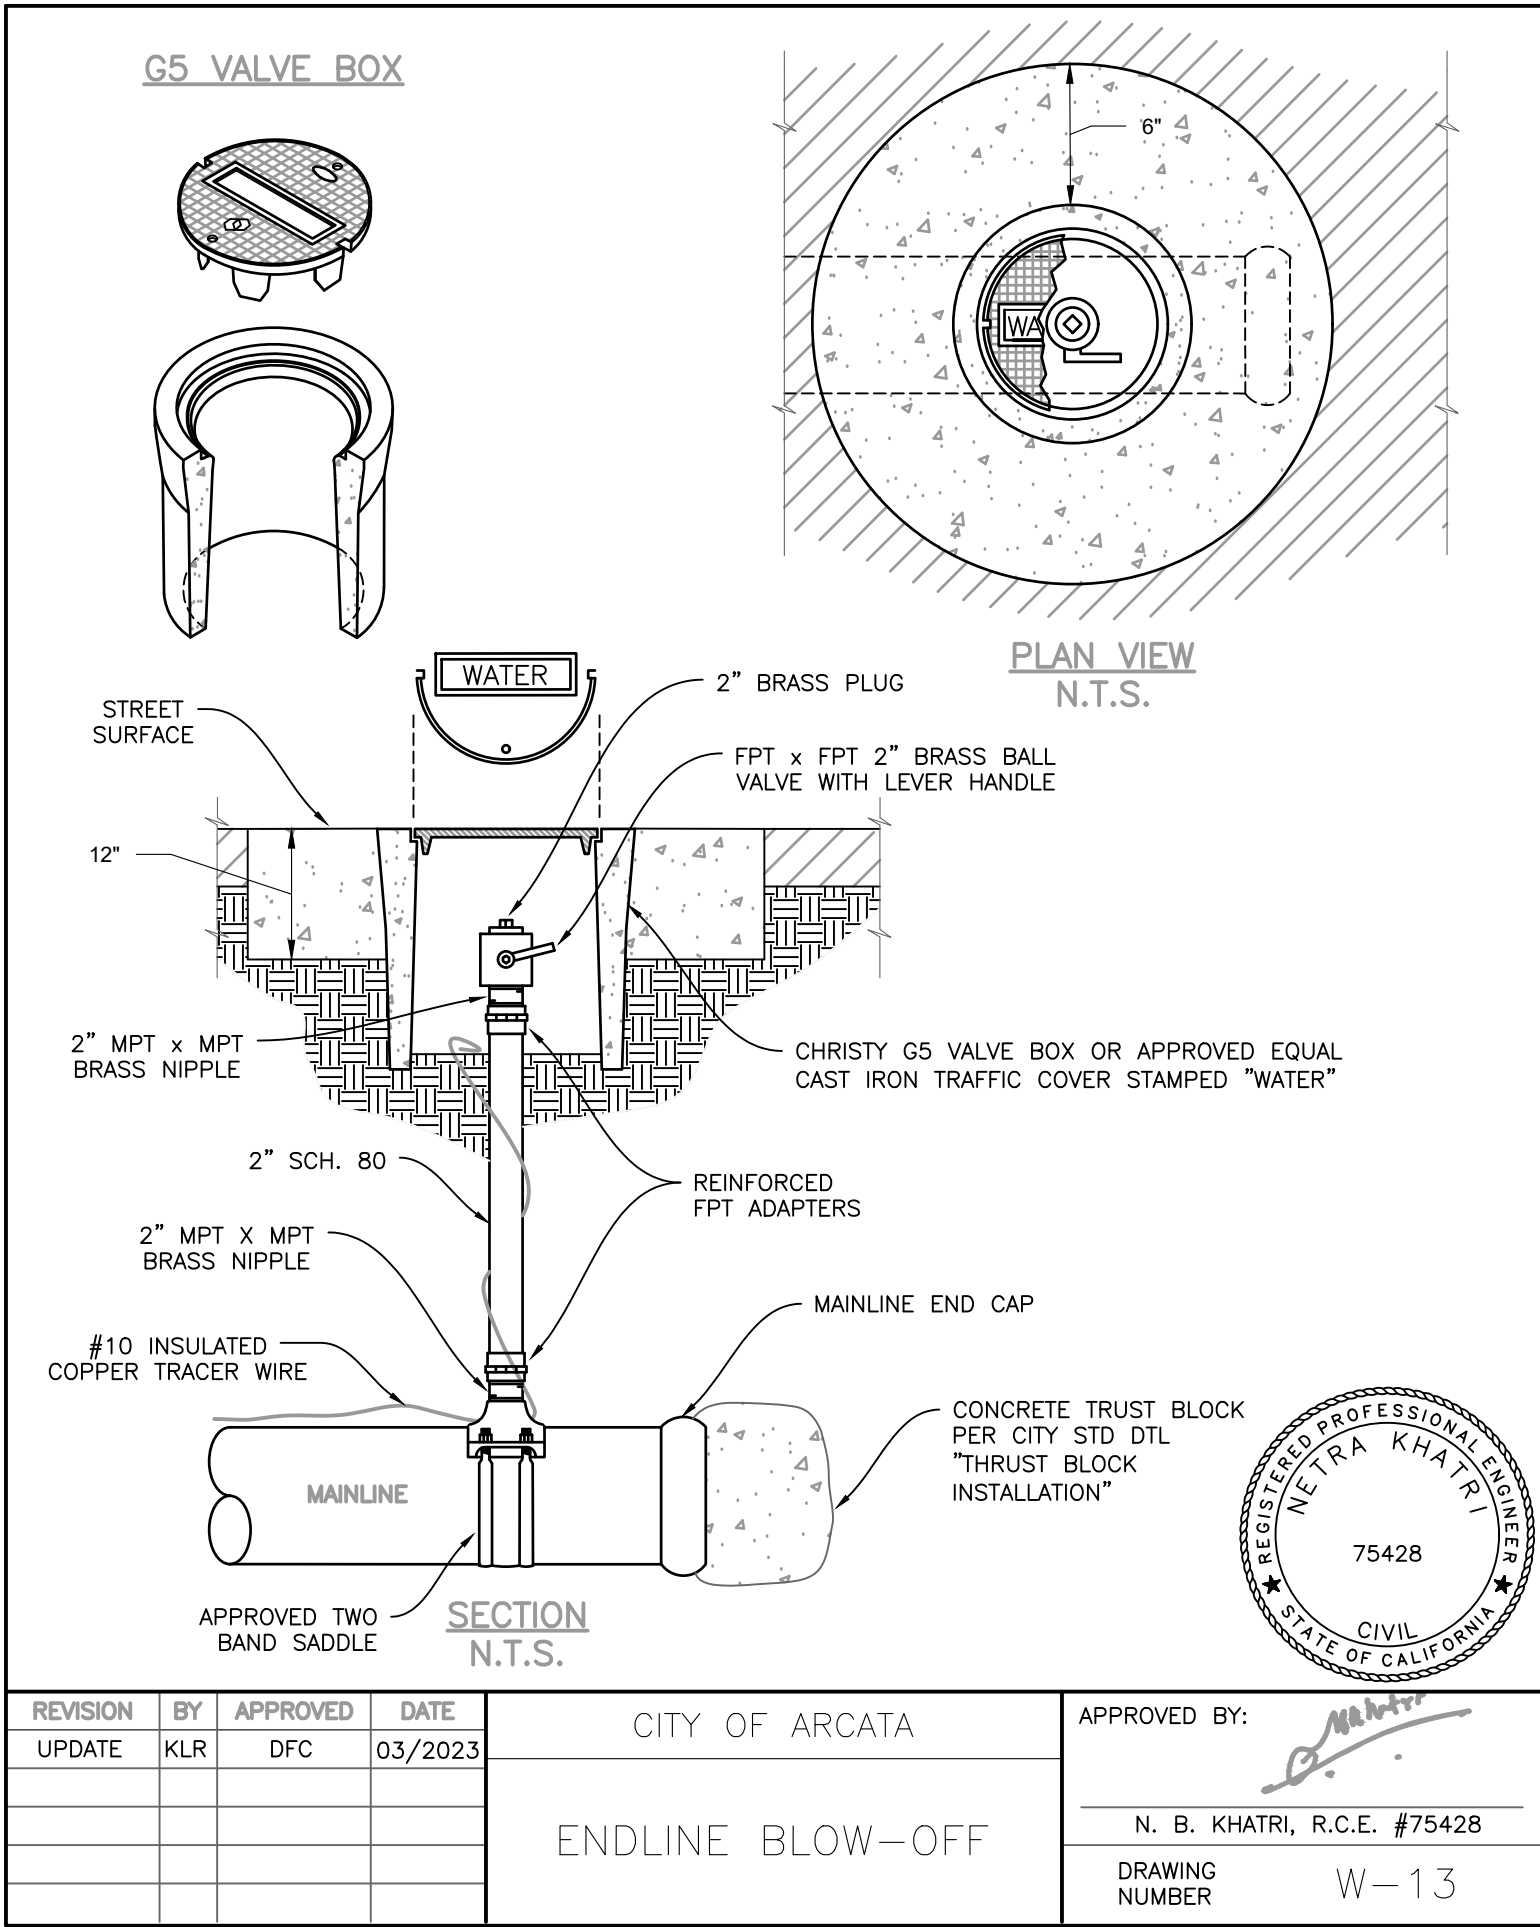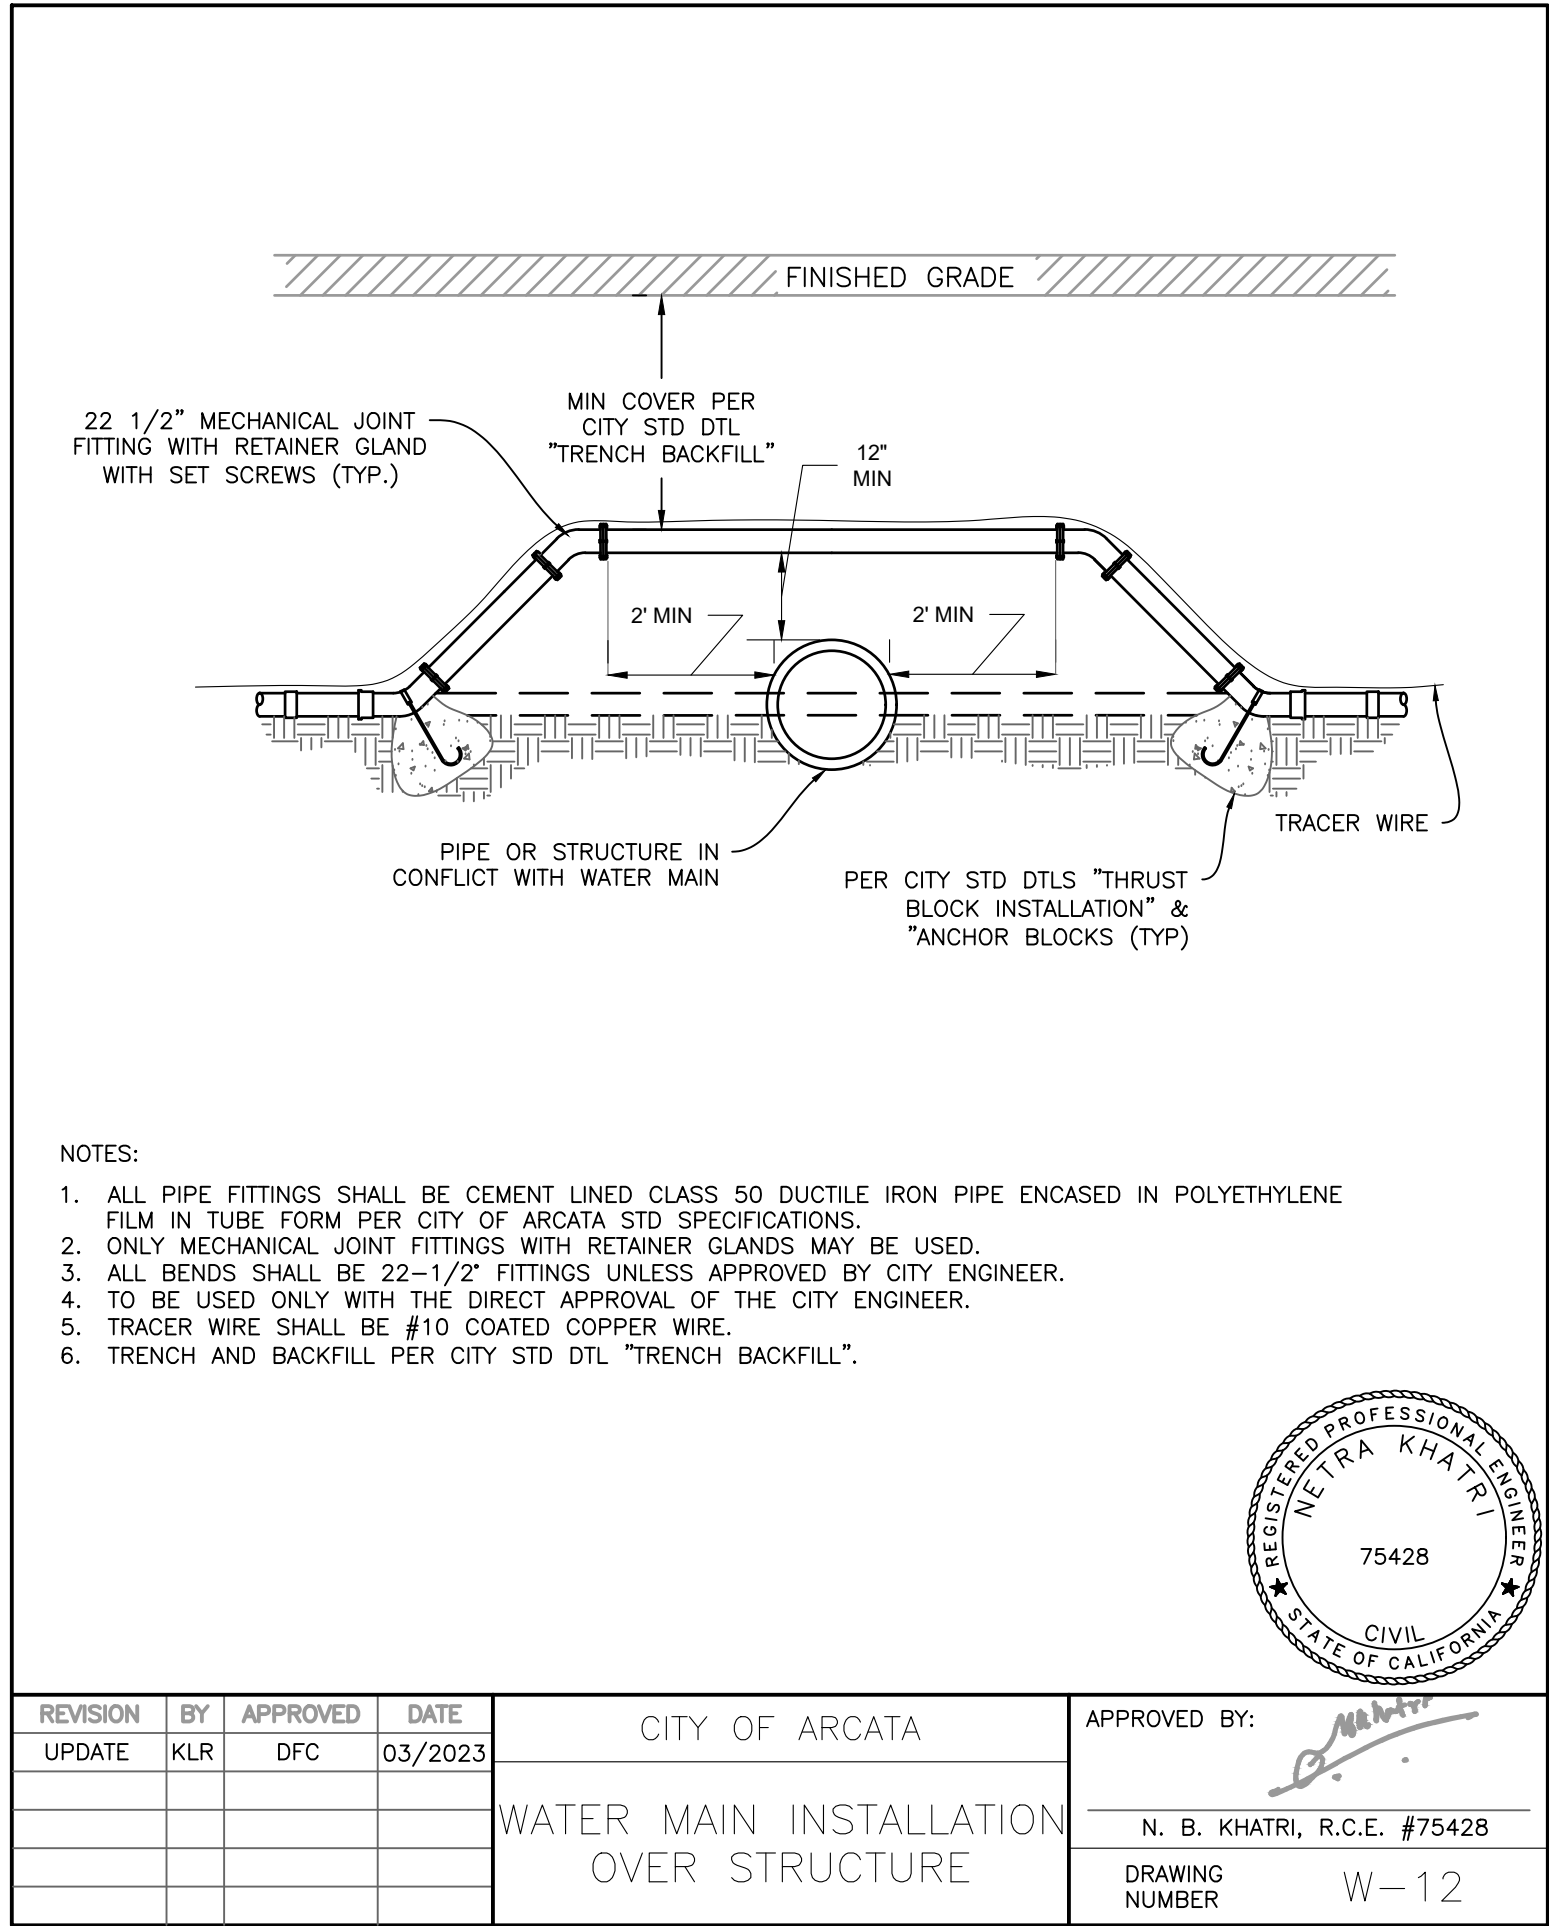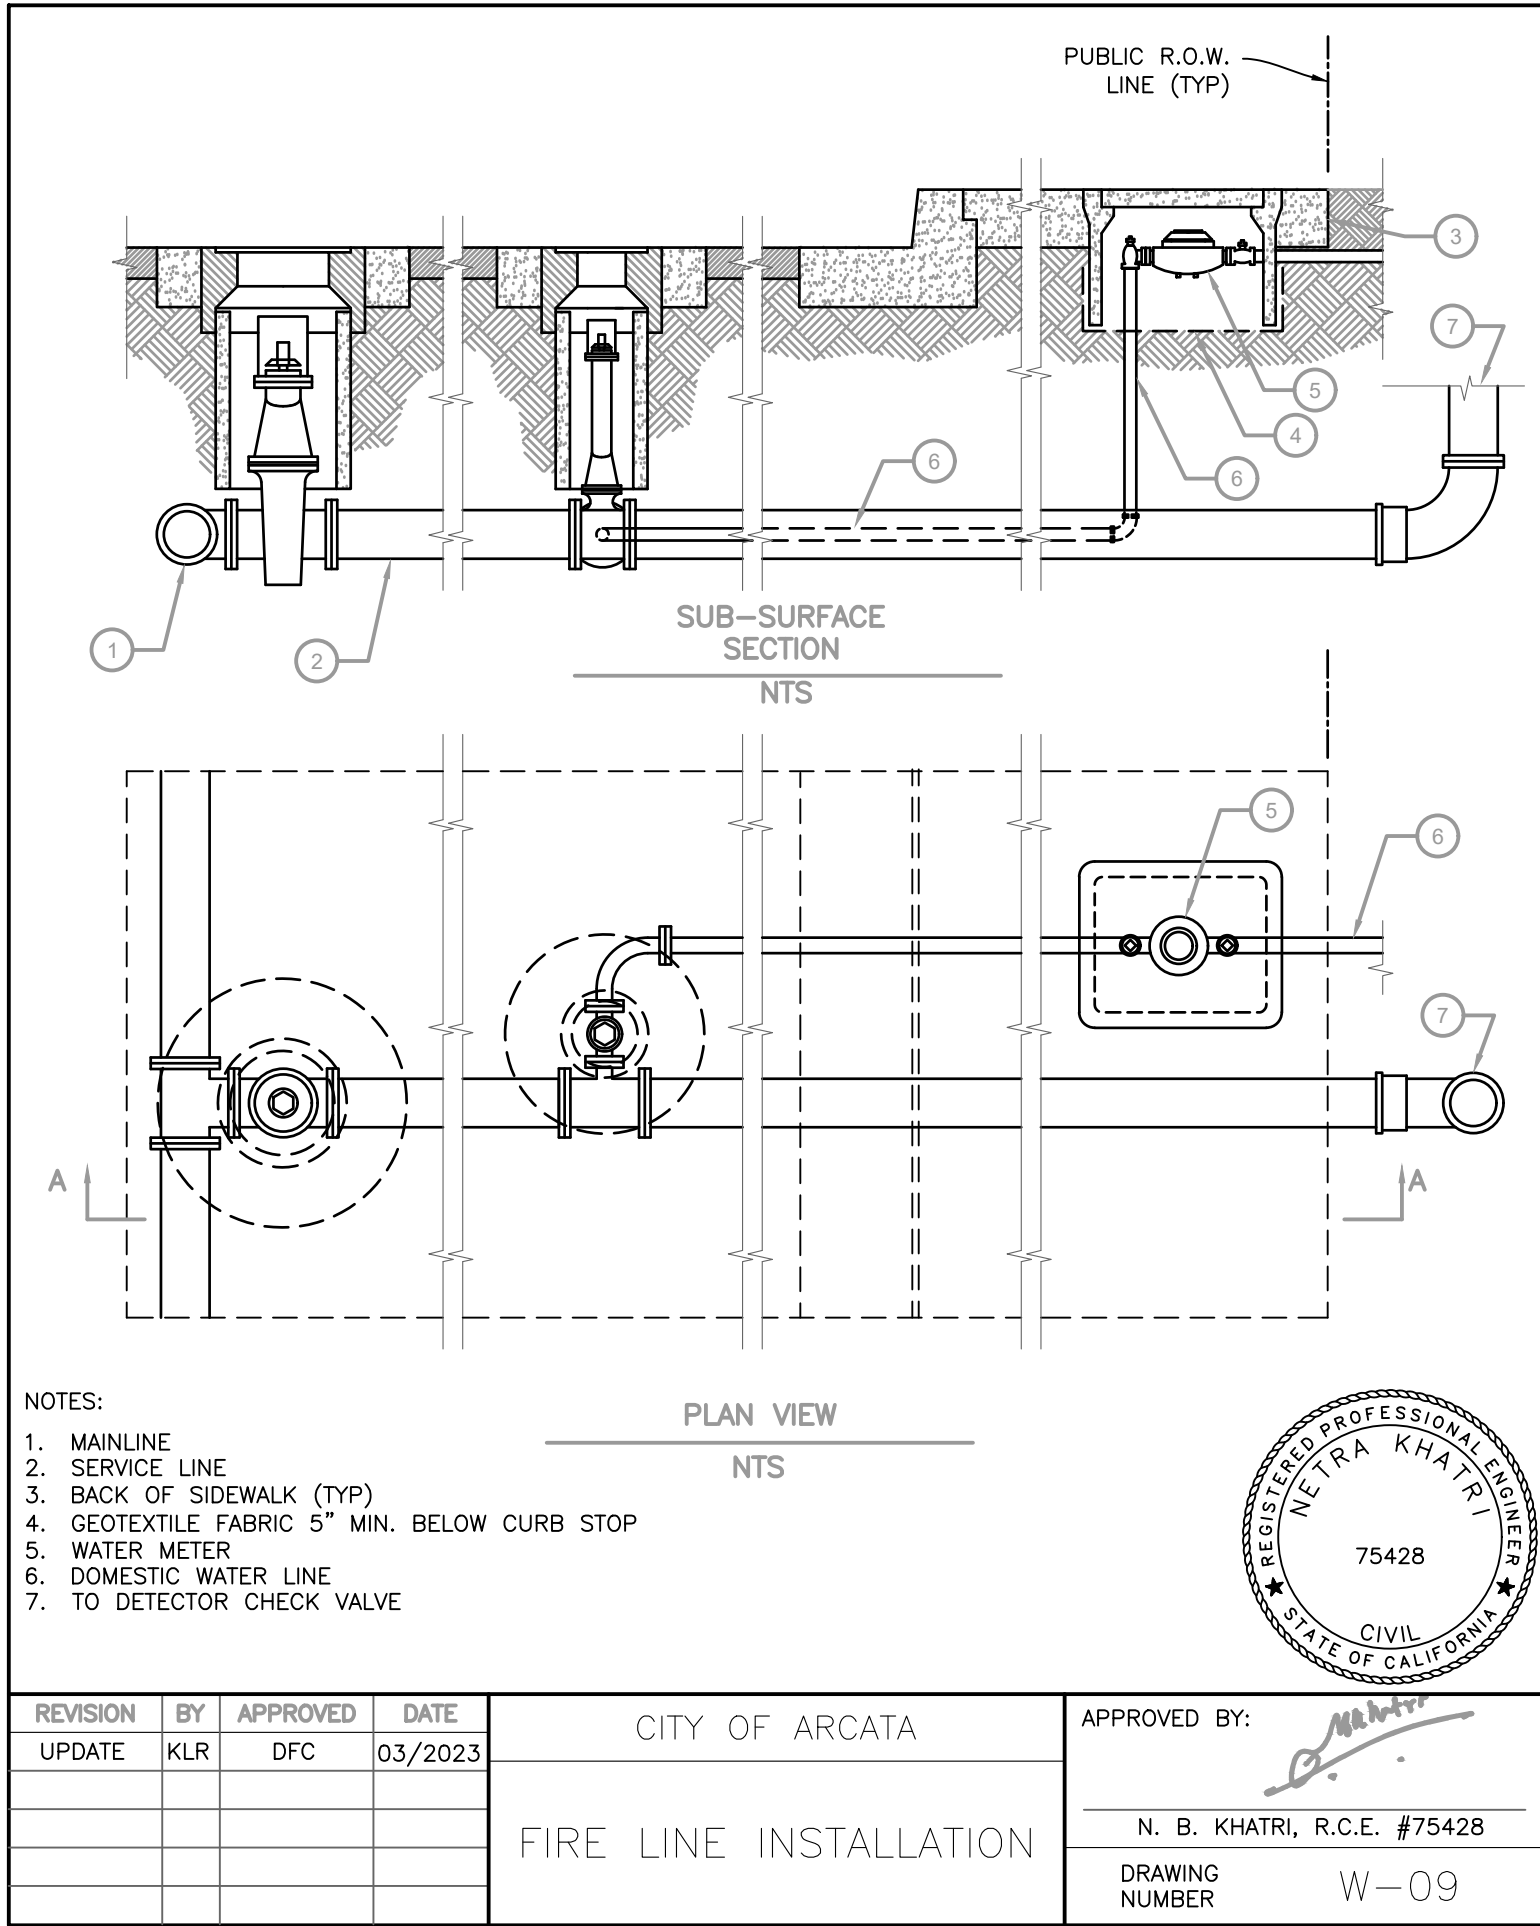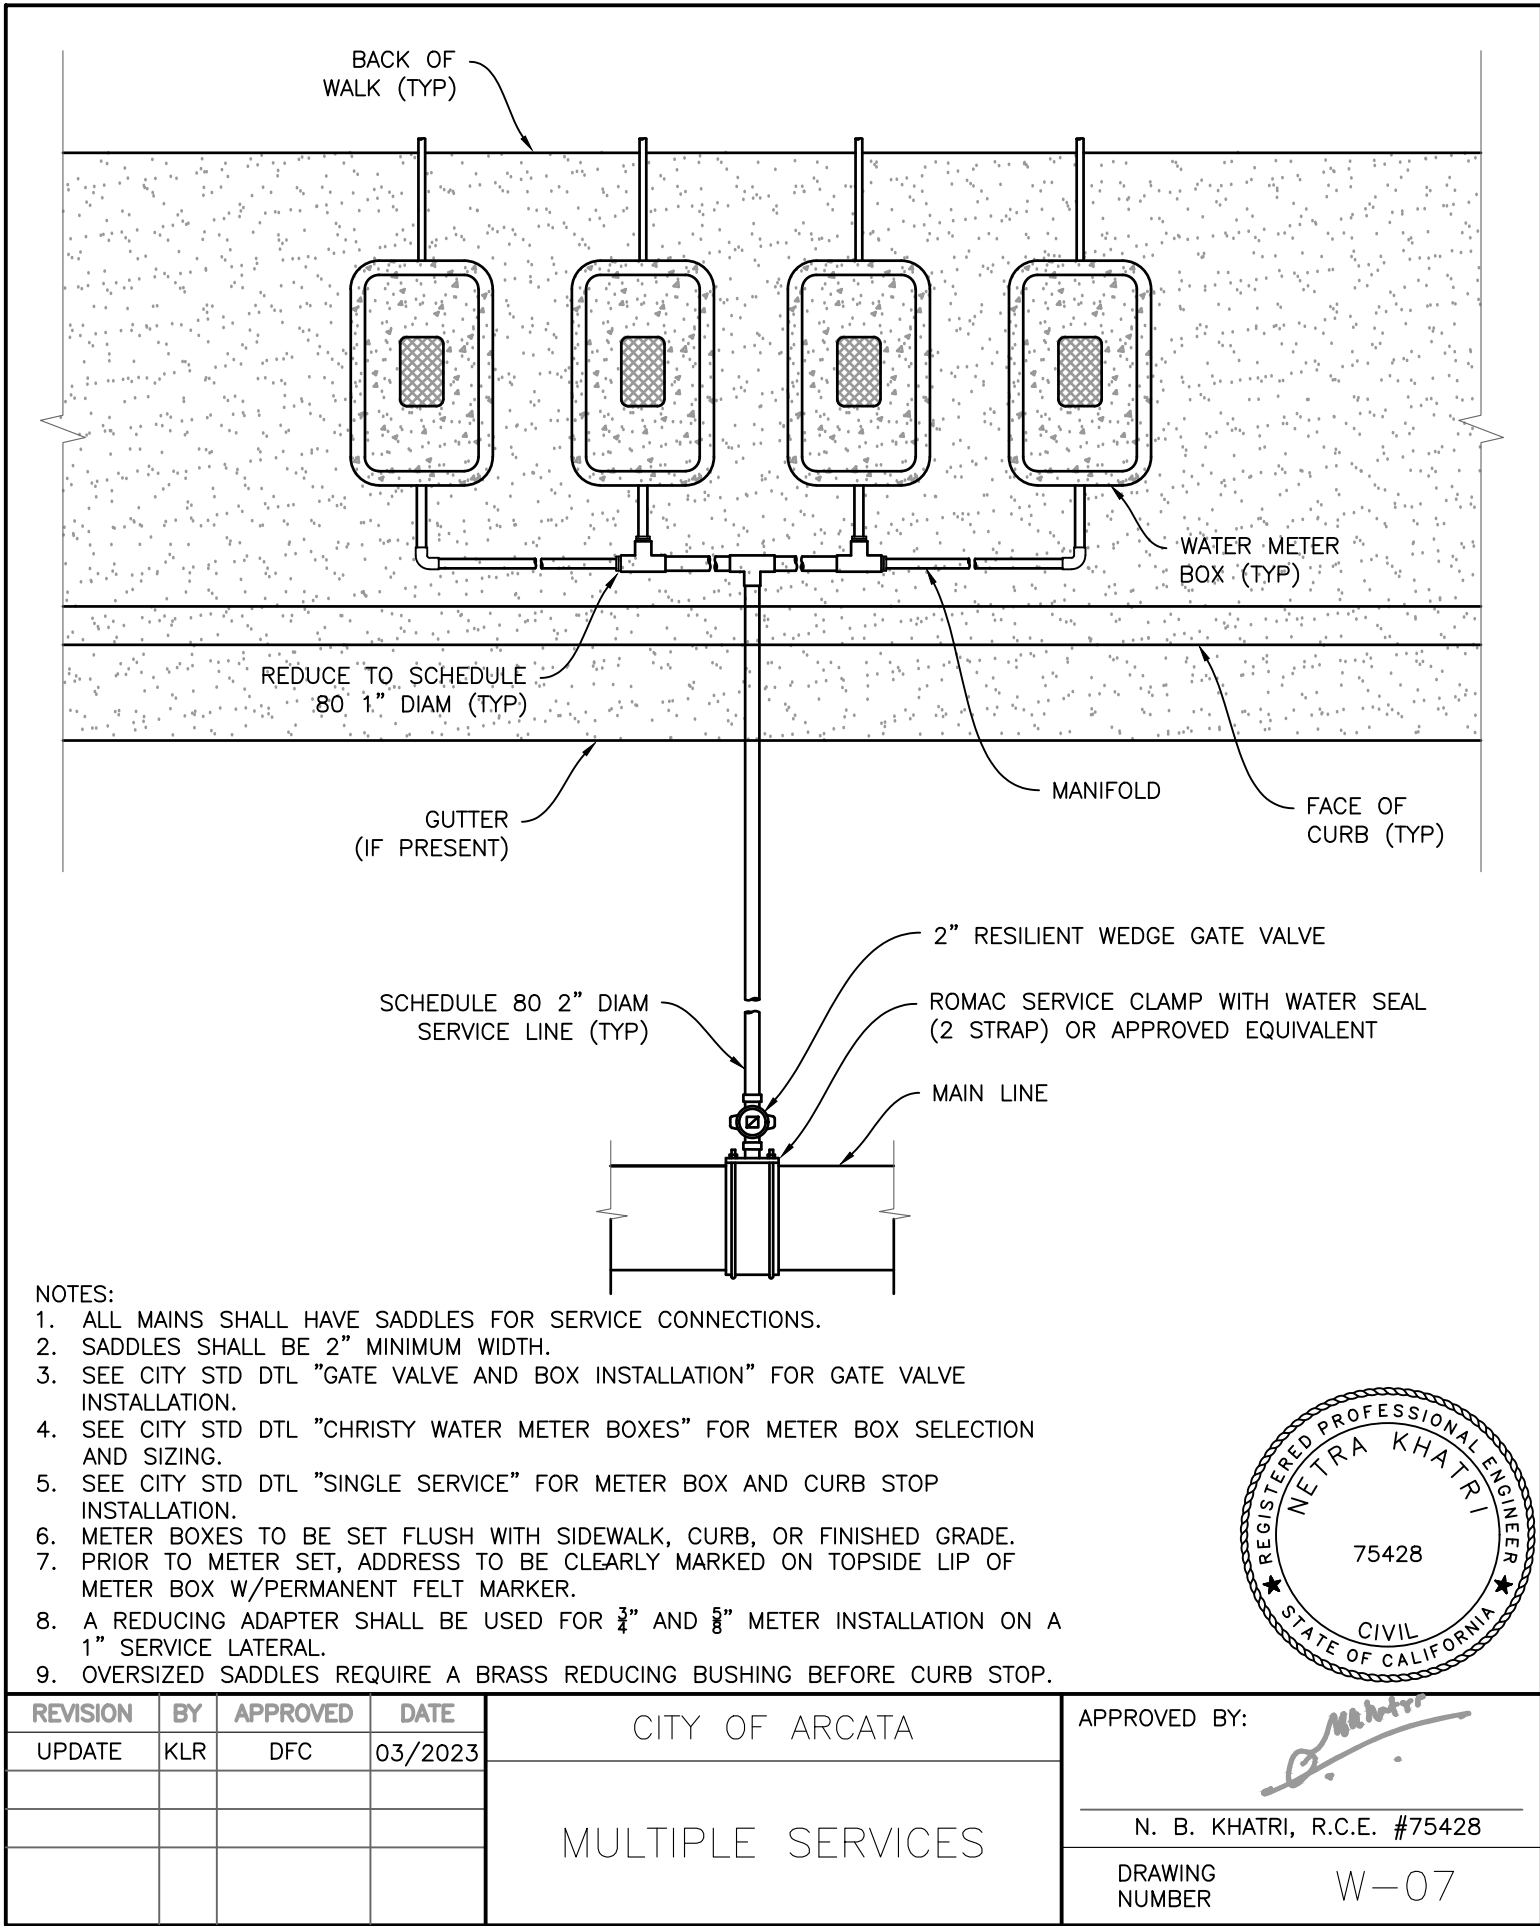

STANDARD DETAILS

STEEL WATERLINE REPLACEMENT PROJECT

Project Address

VARIOUS LOCATIONS

Designed By

JONATHAN A. KIRCHUBEL

Drawn By

JONATHAN A. KIRCHUBEL

Checked By

DAVID CAISSE

Approved By

NETRA B. KHATRI

Date

JANUARY 2025

Sheet







C-502

Scale

N/A

Page

27

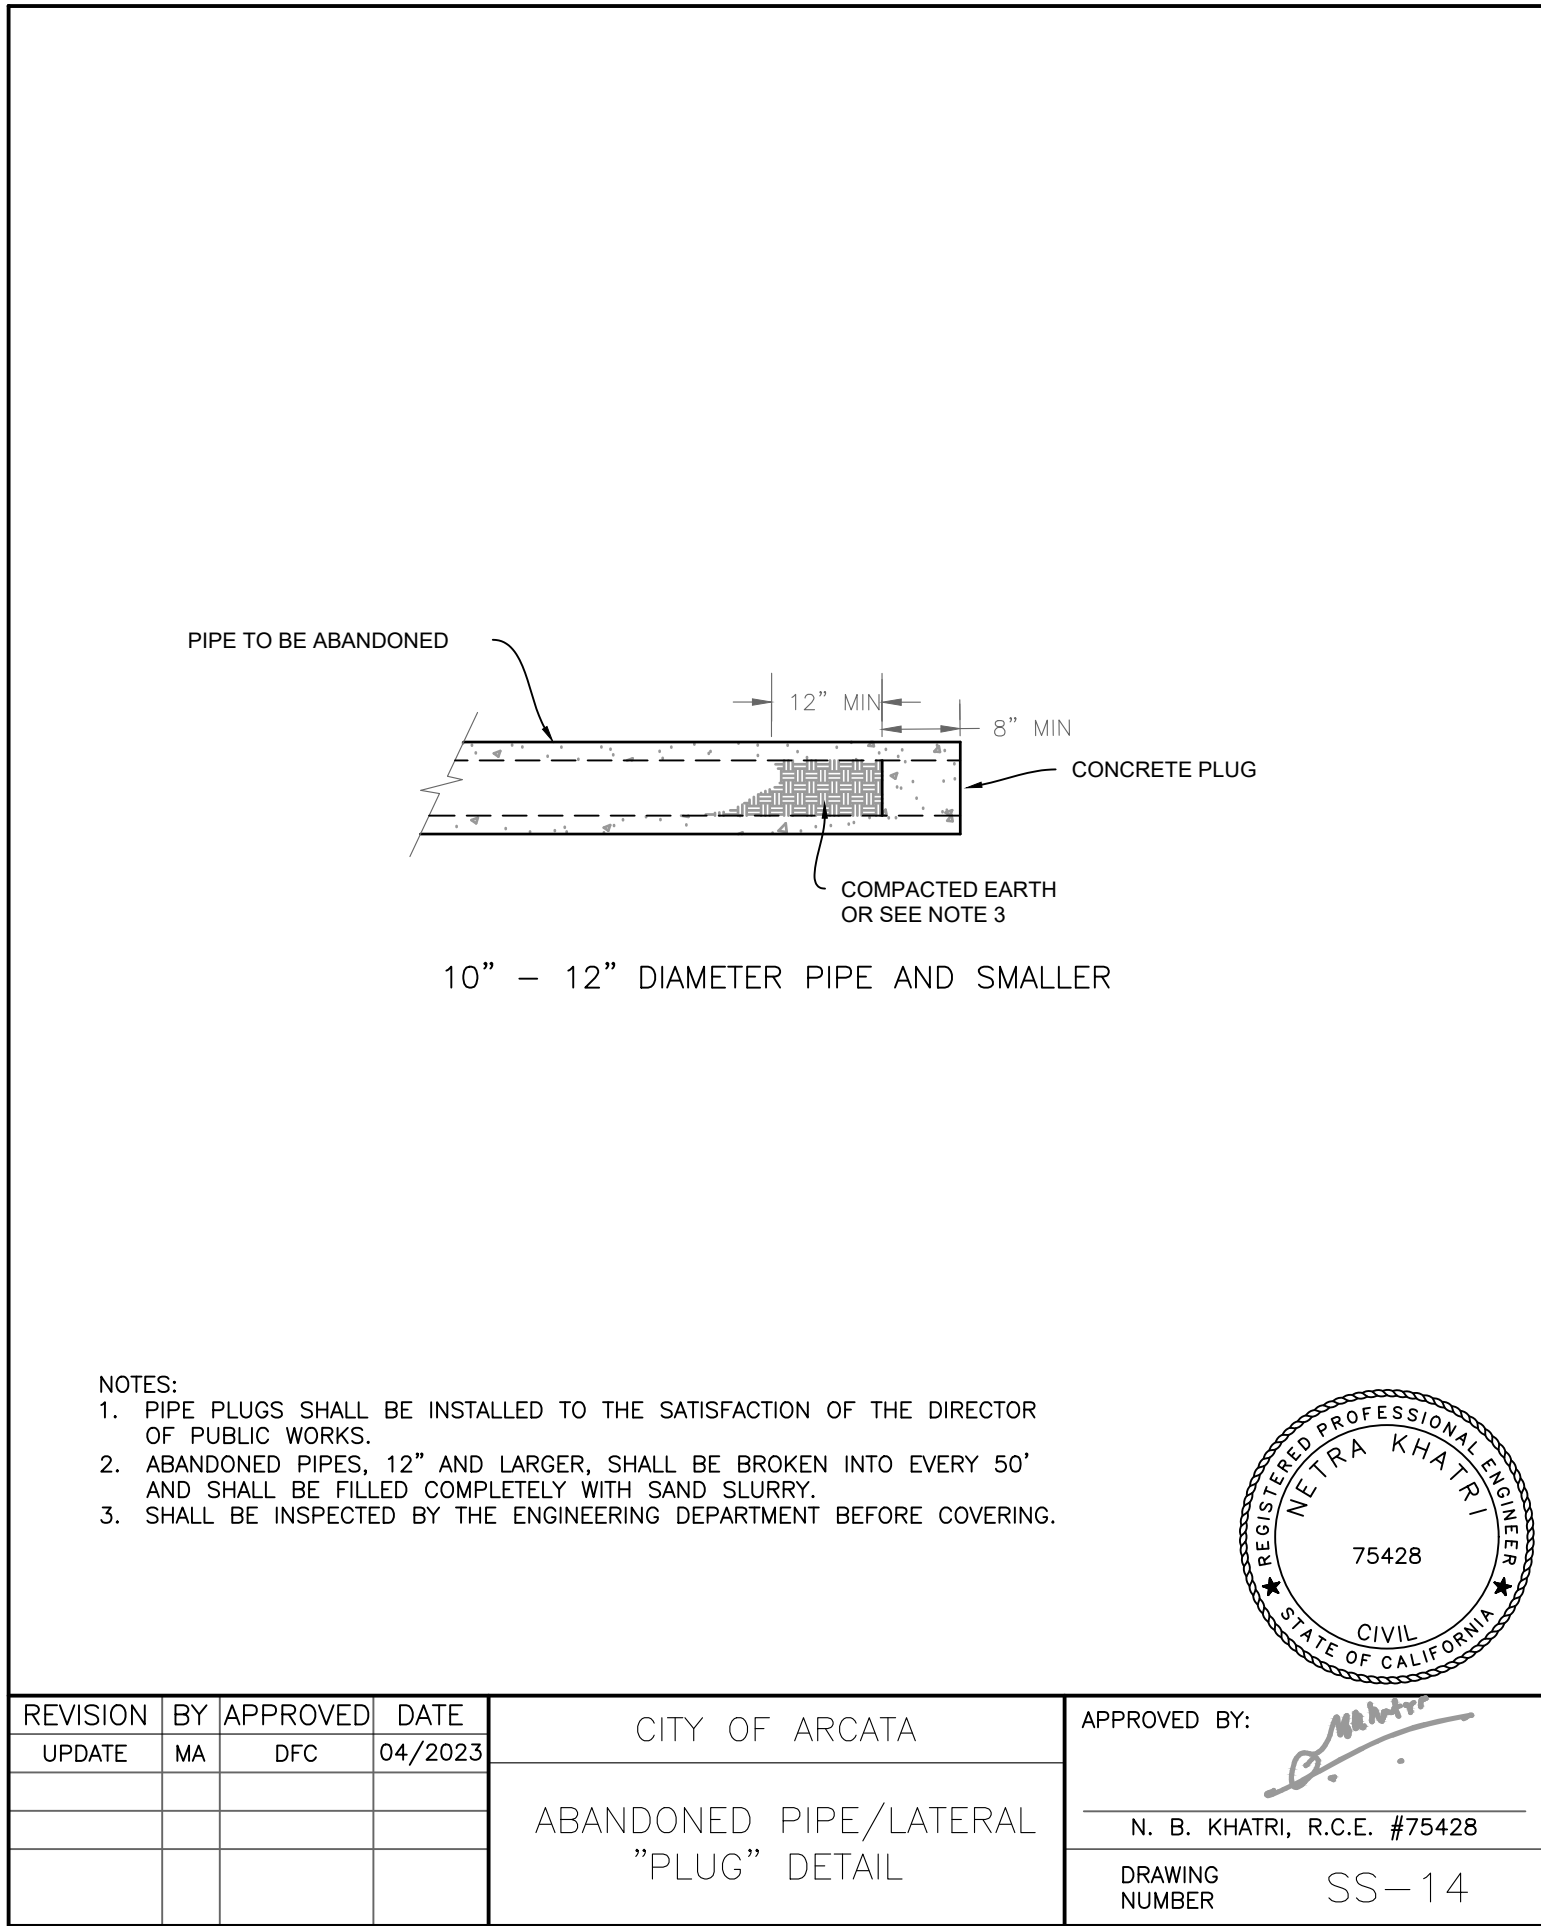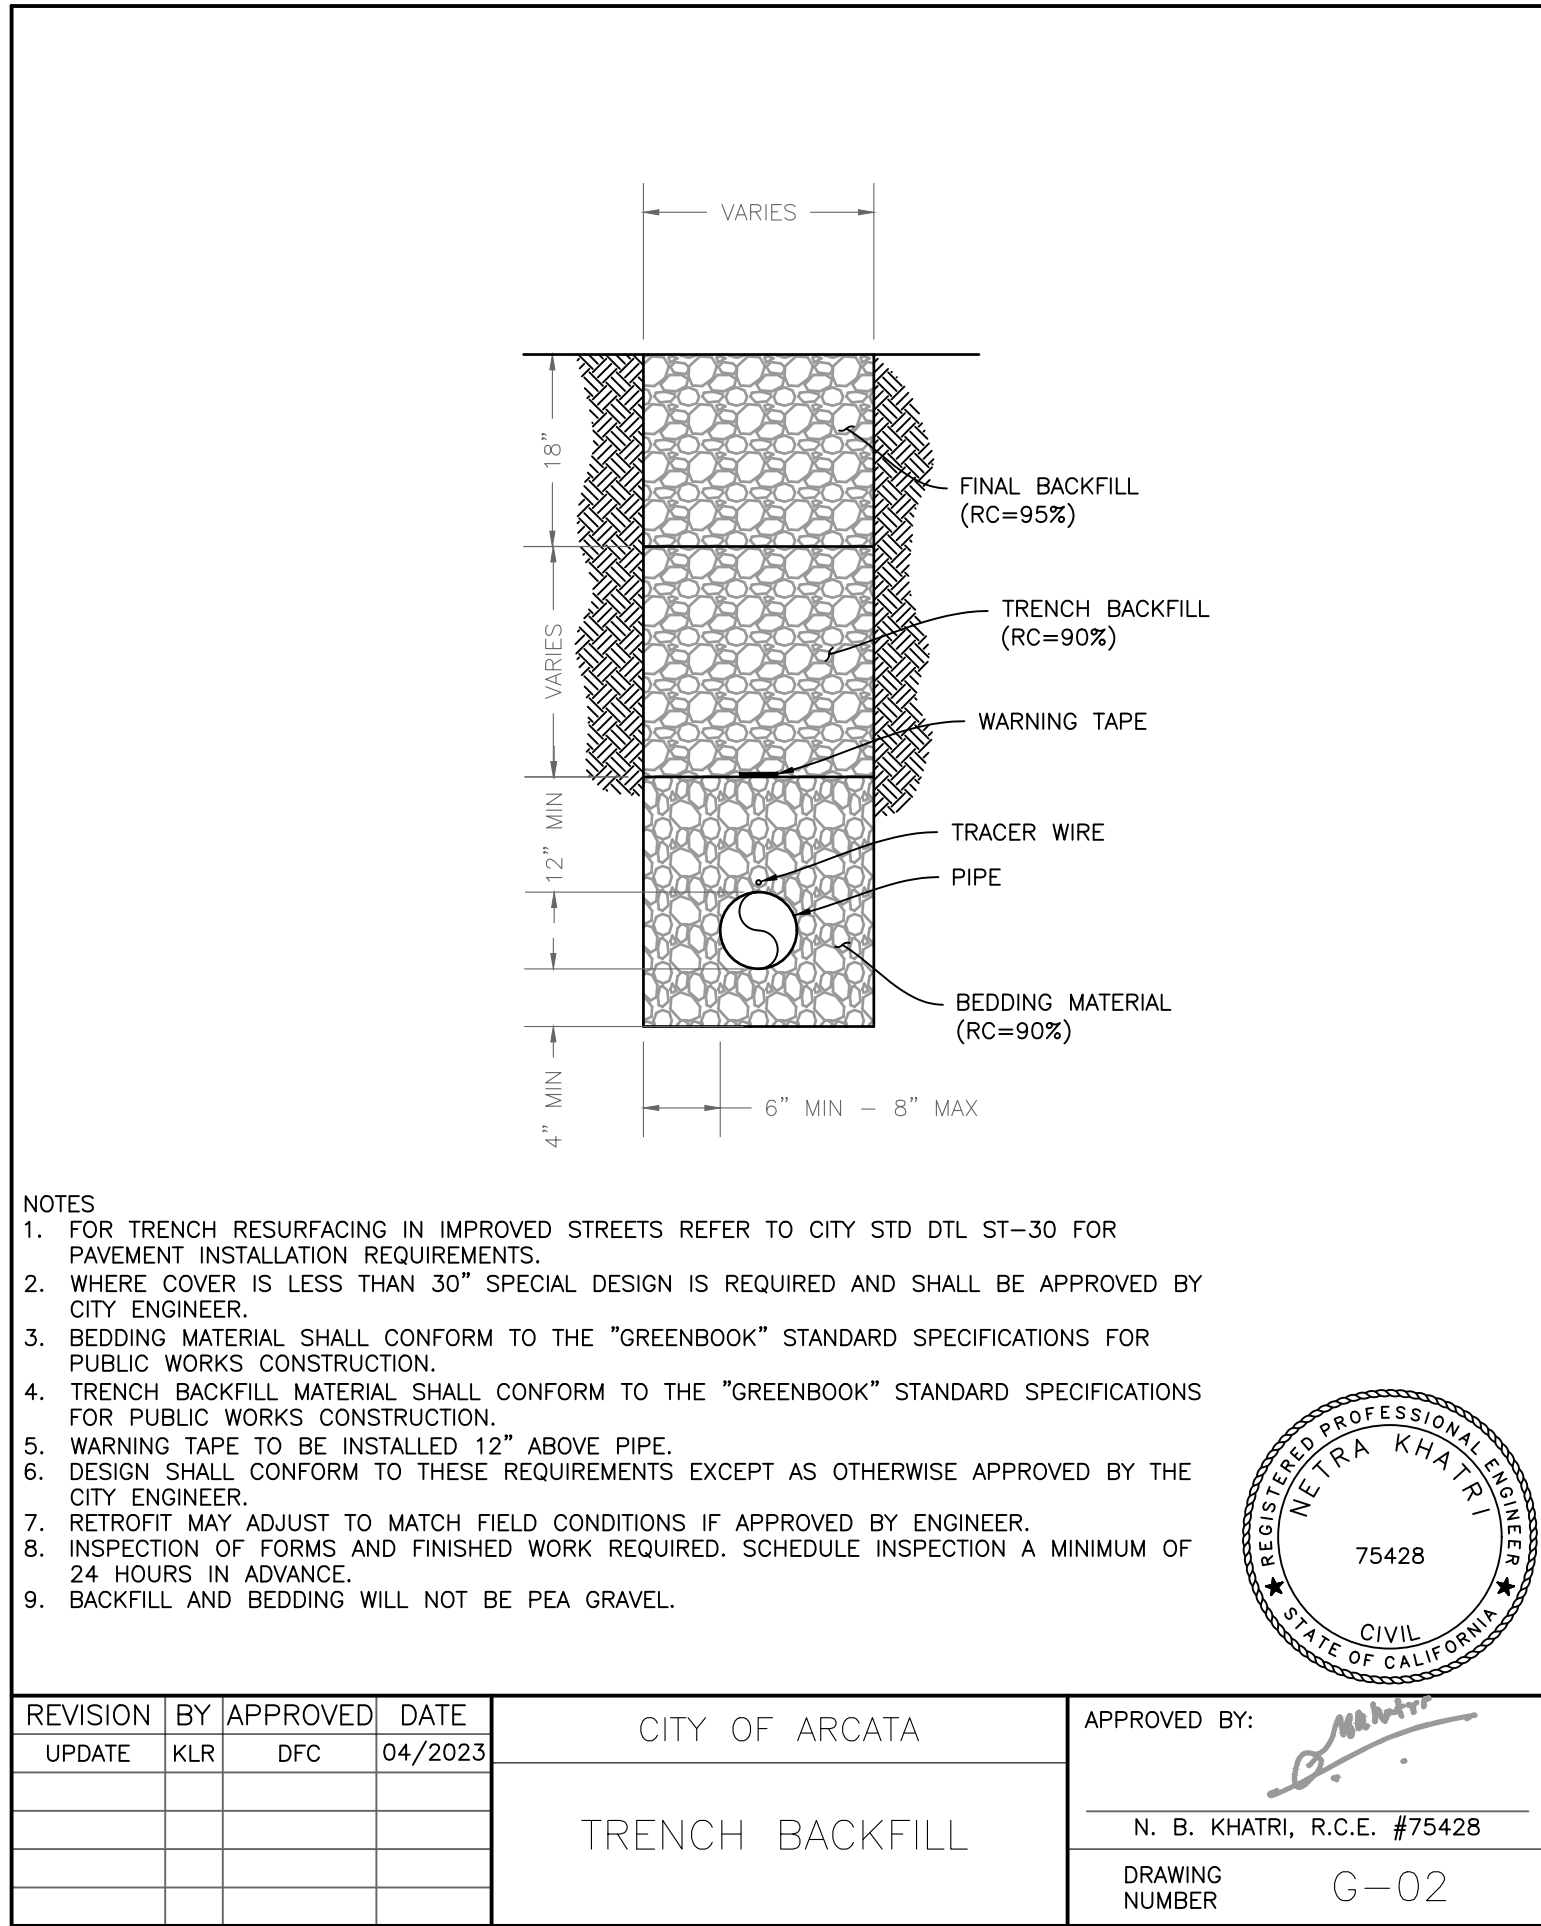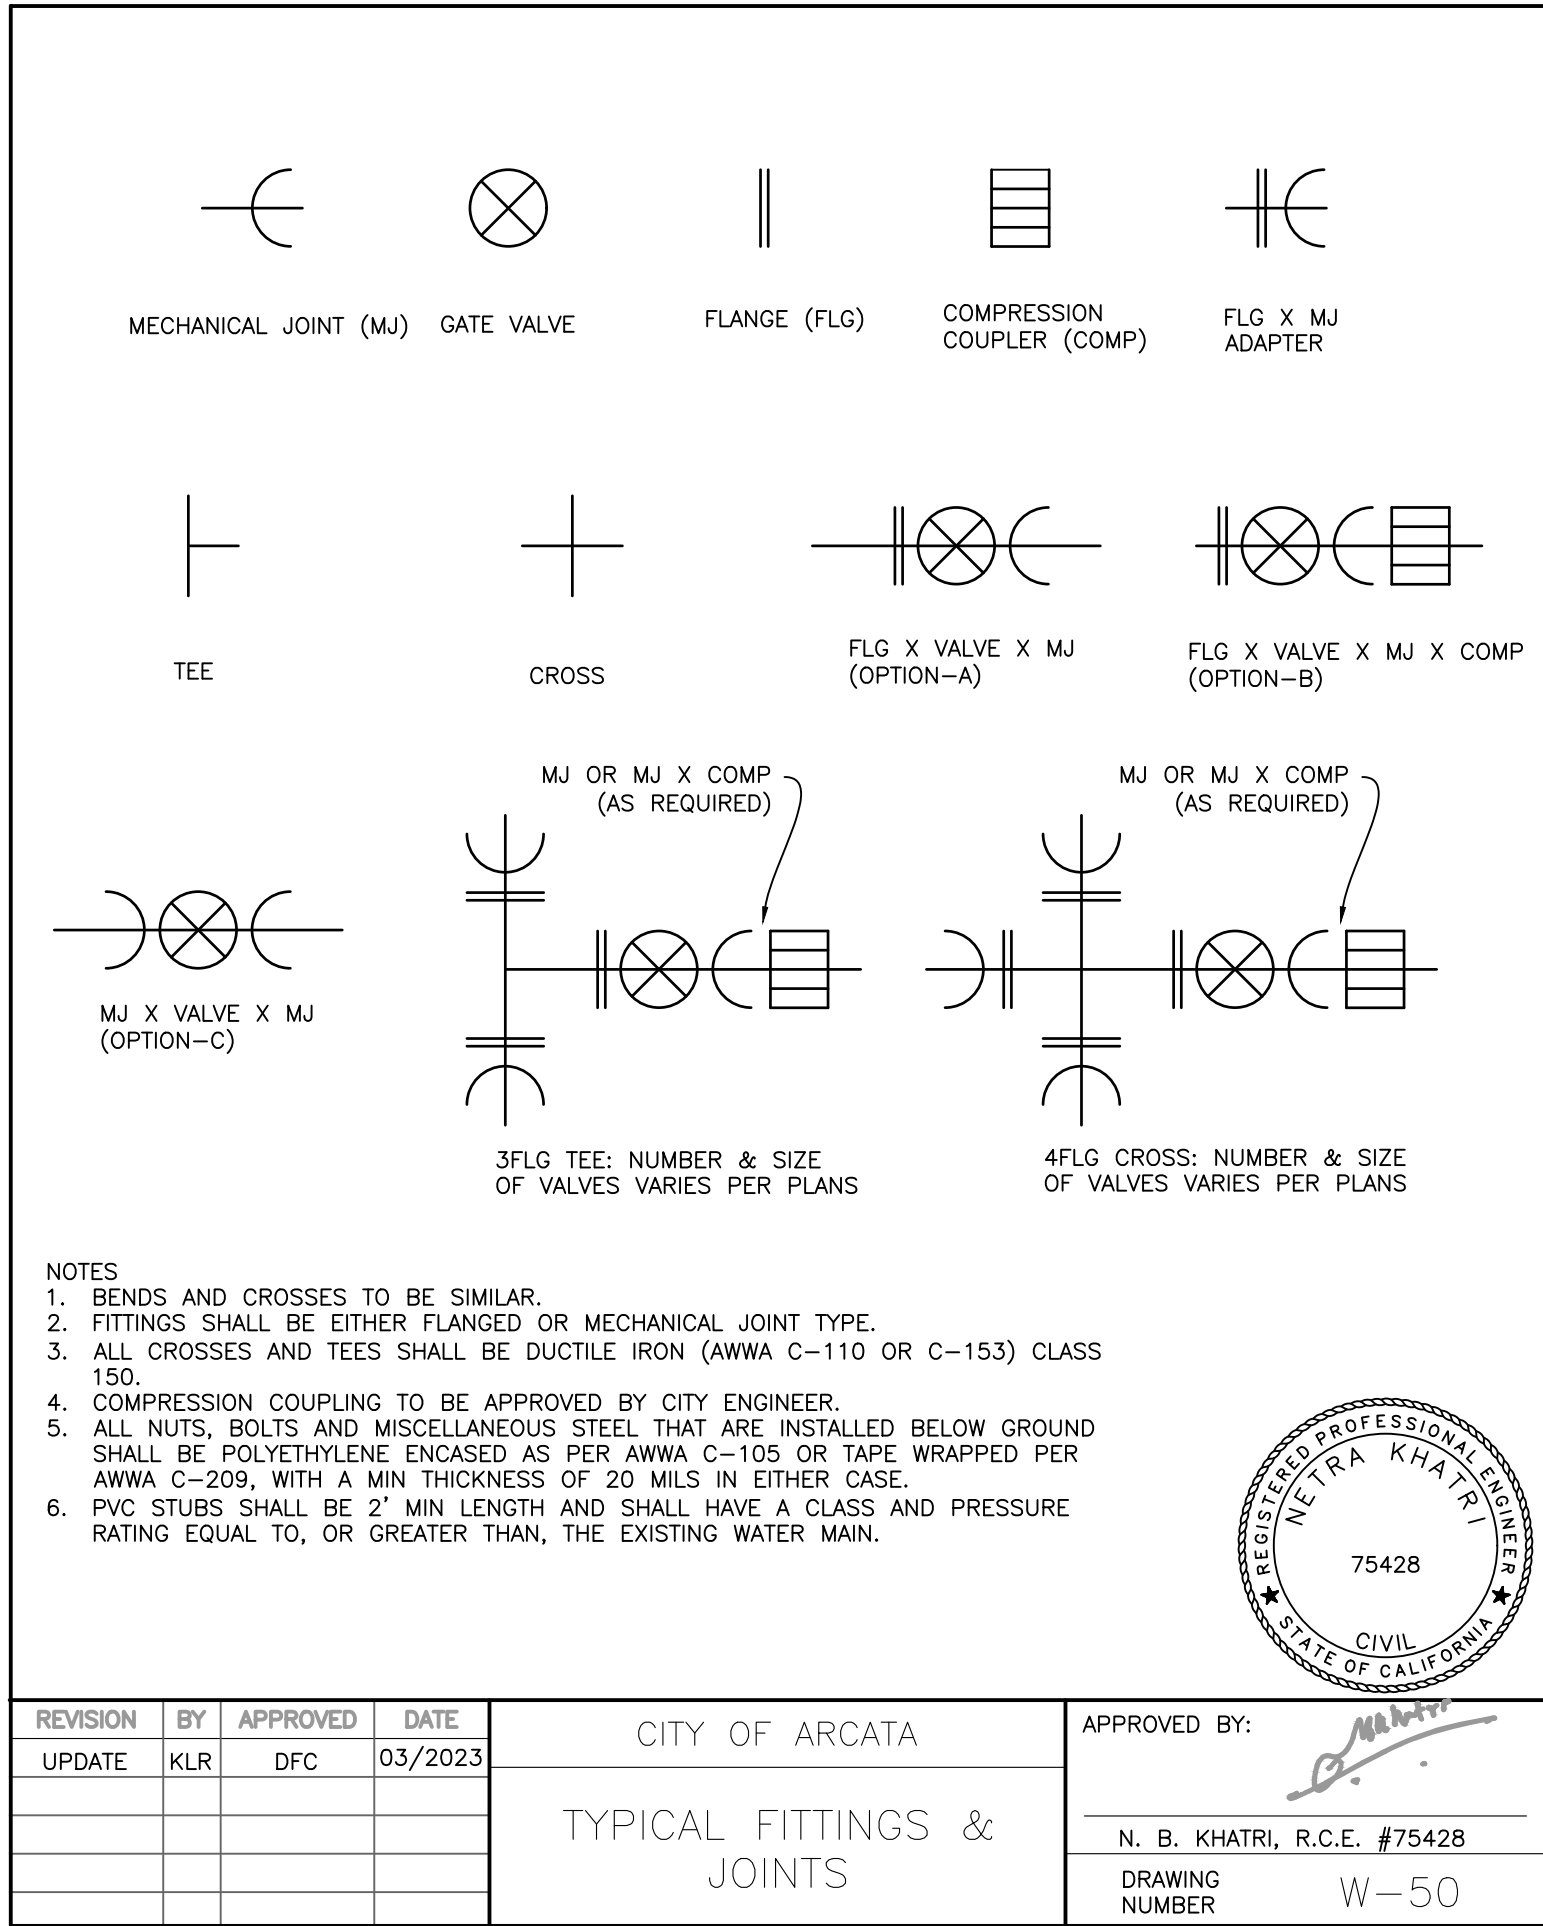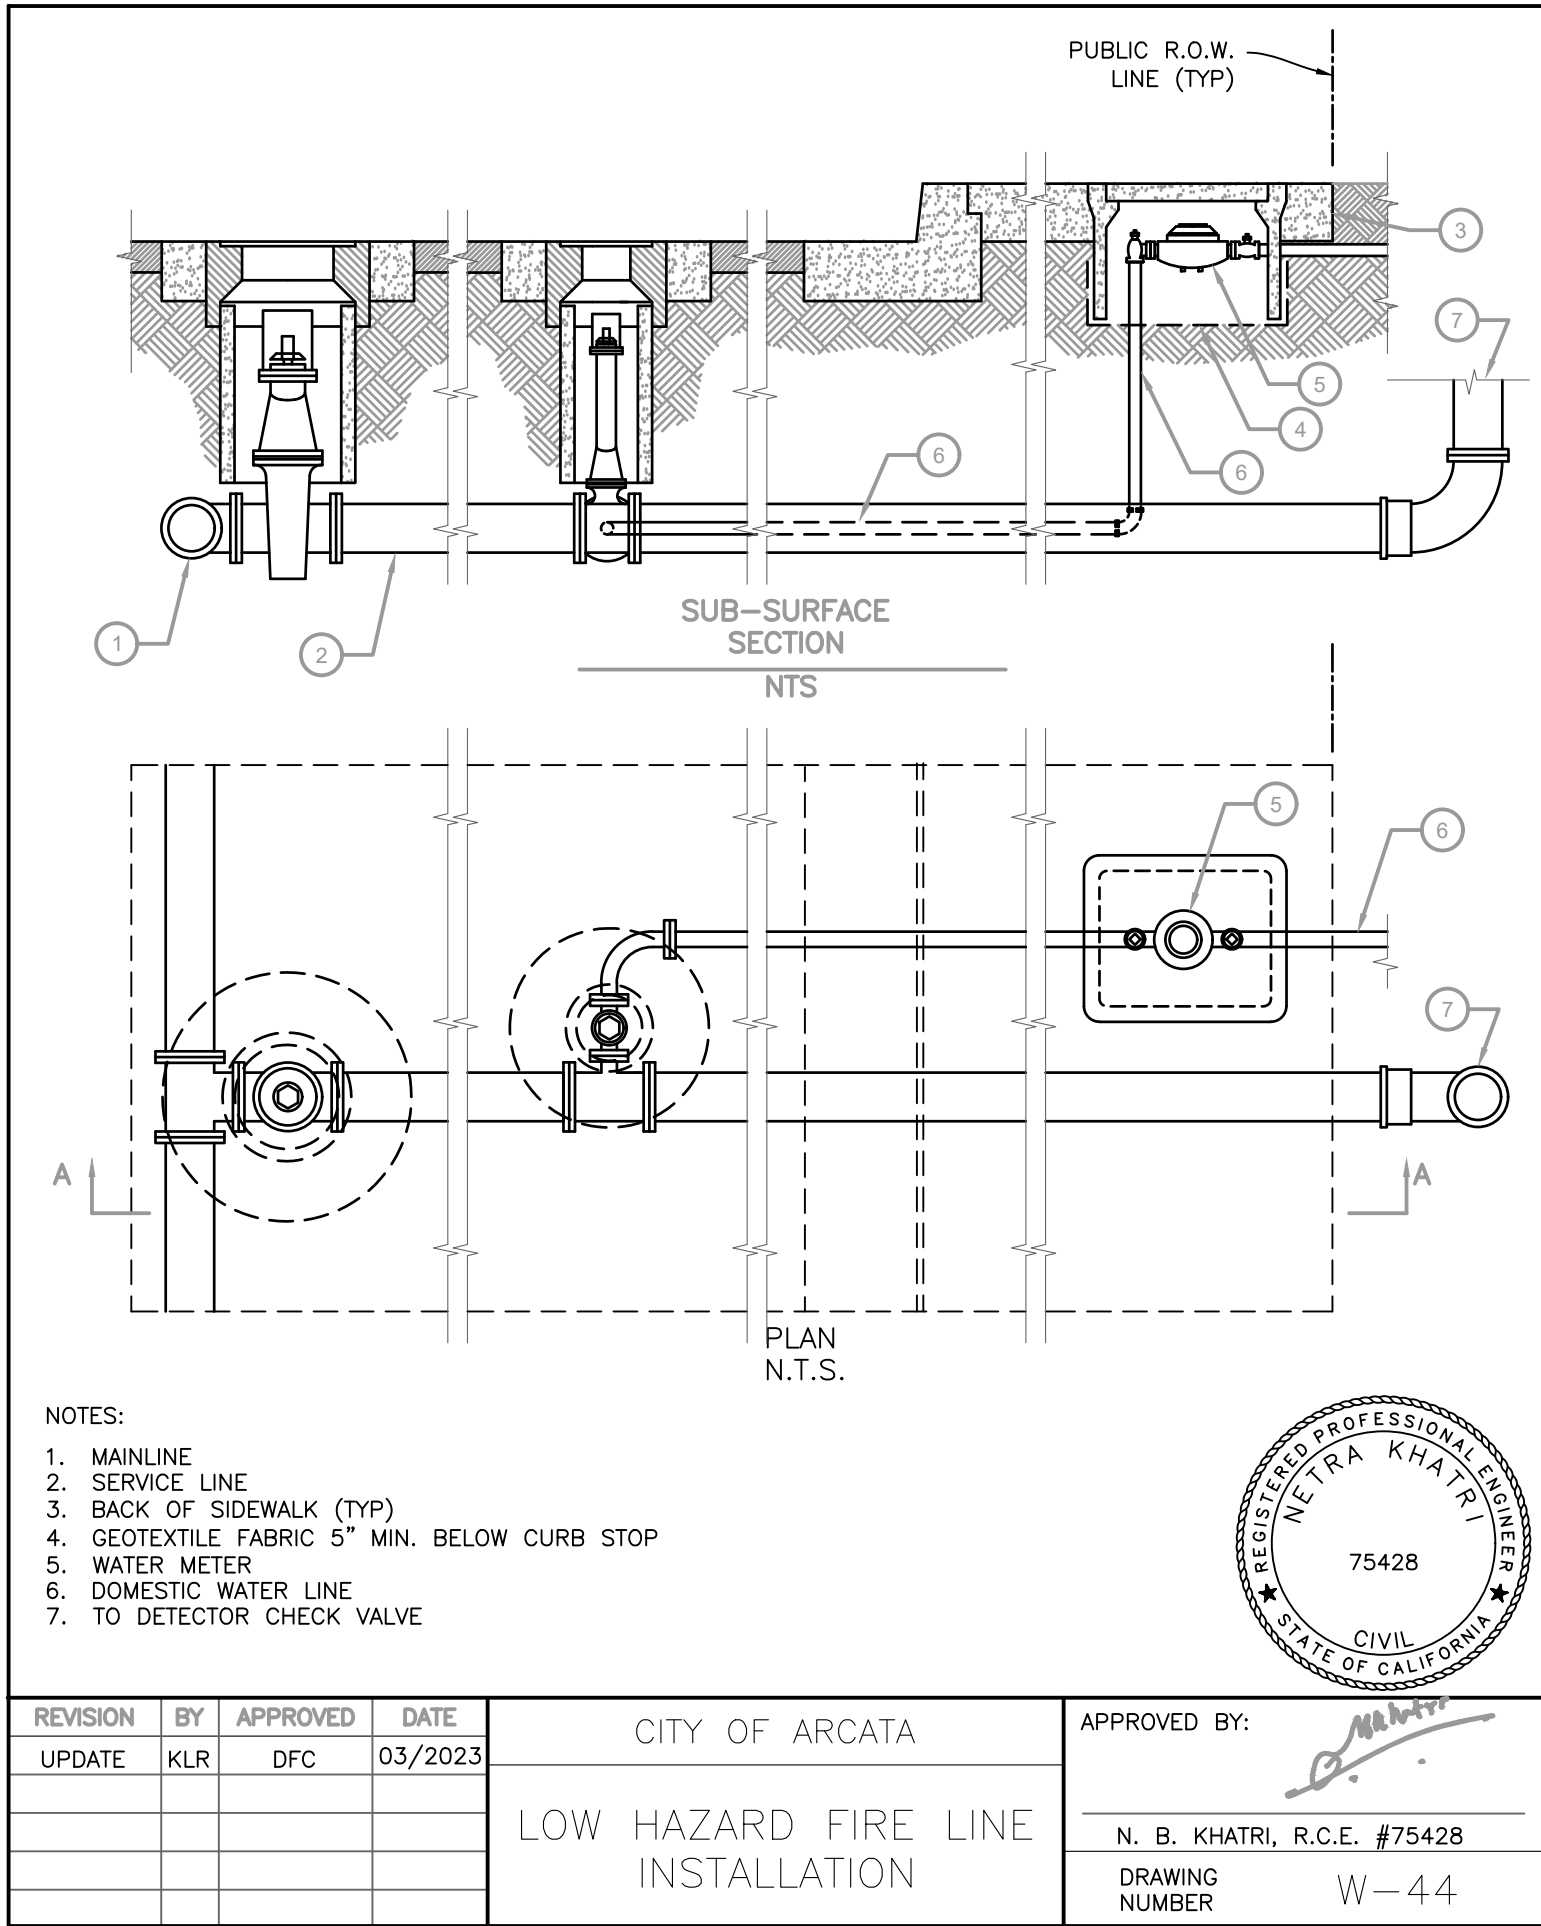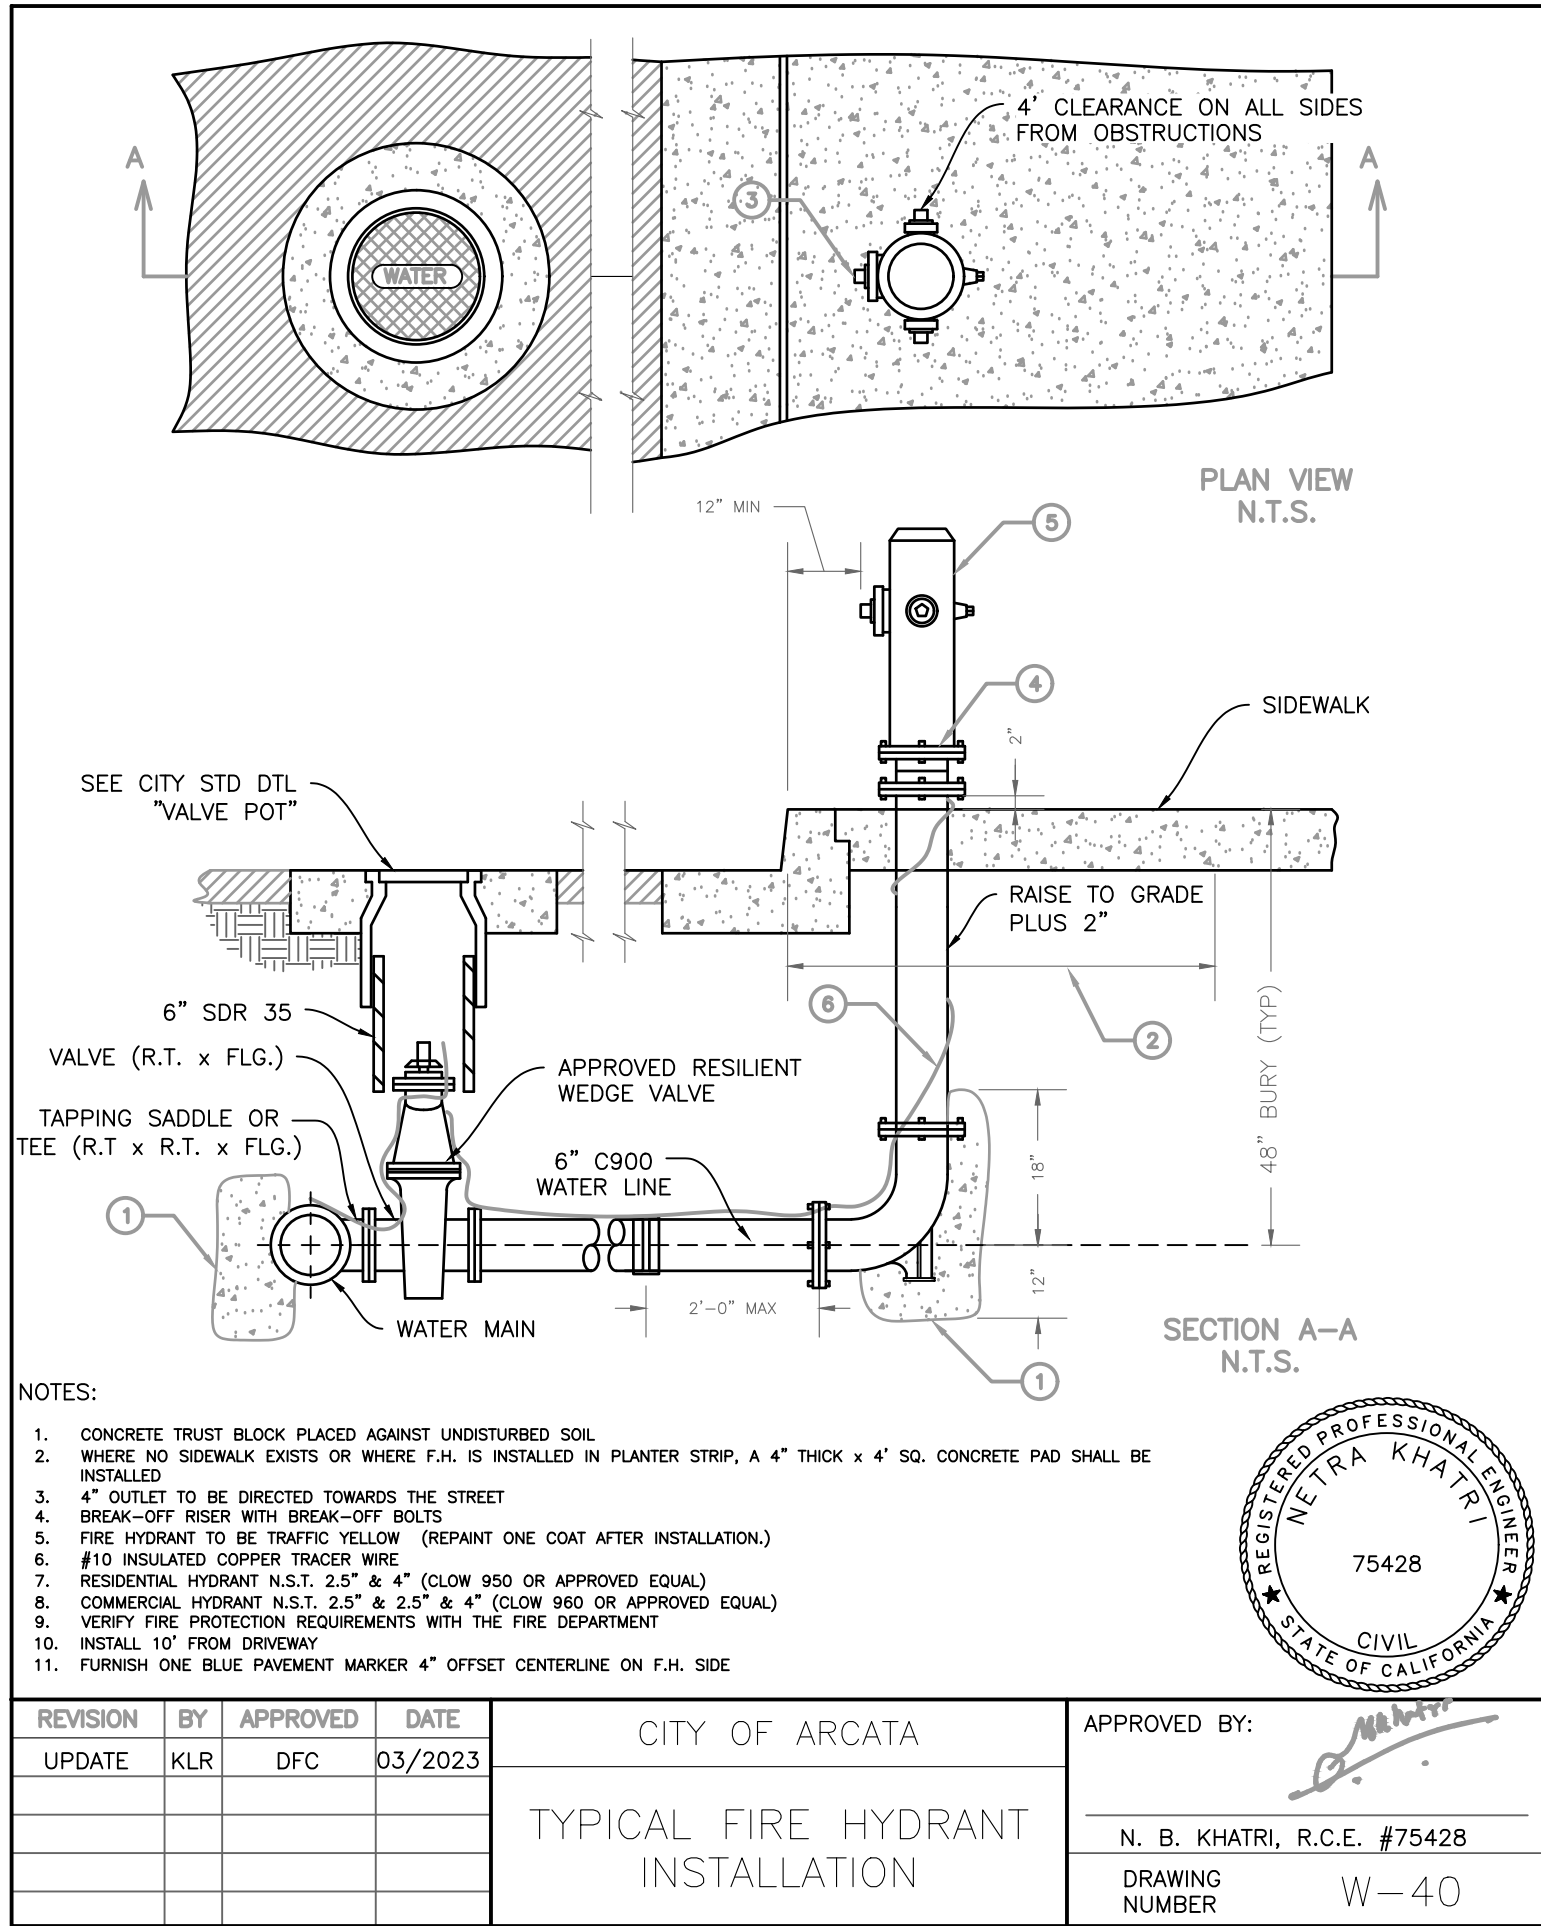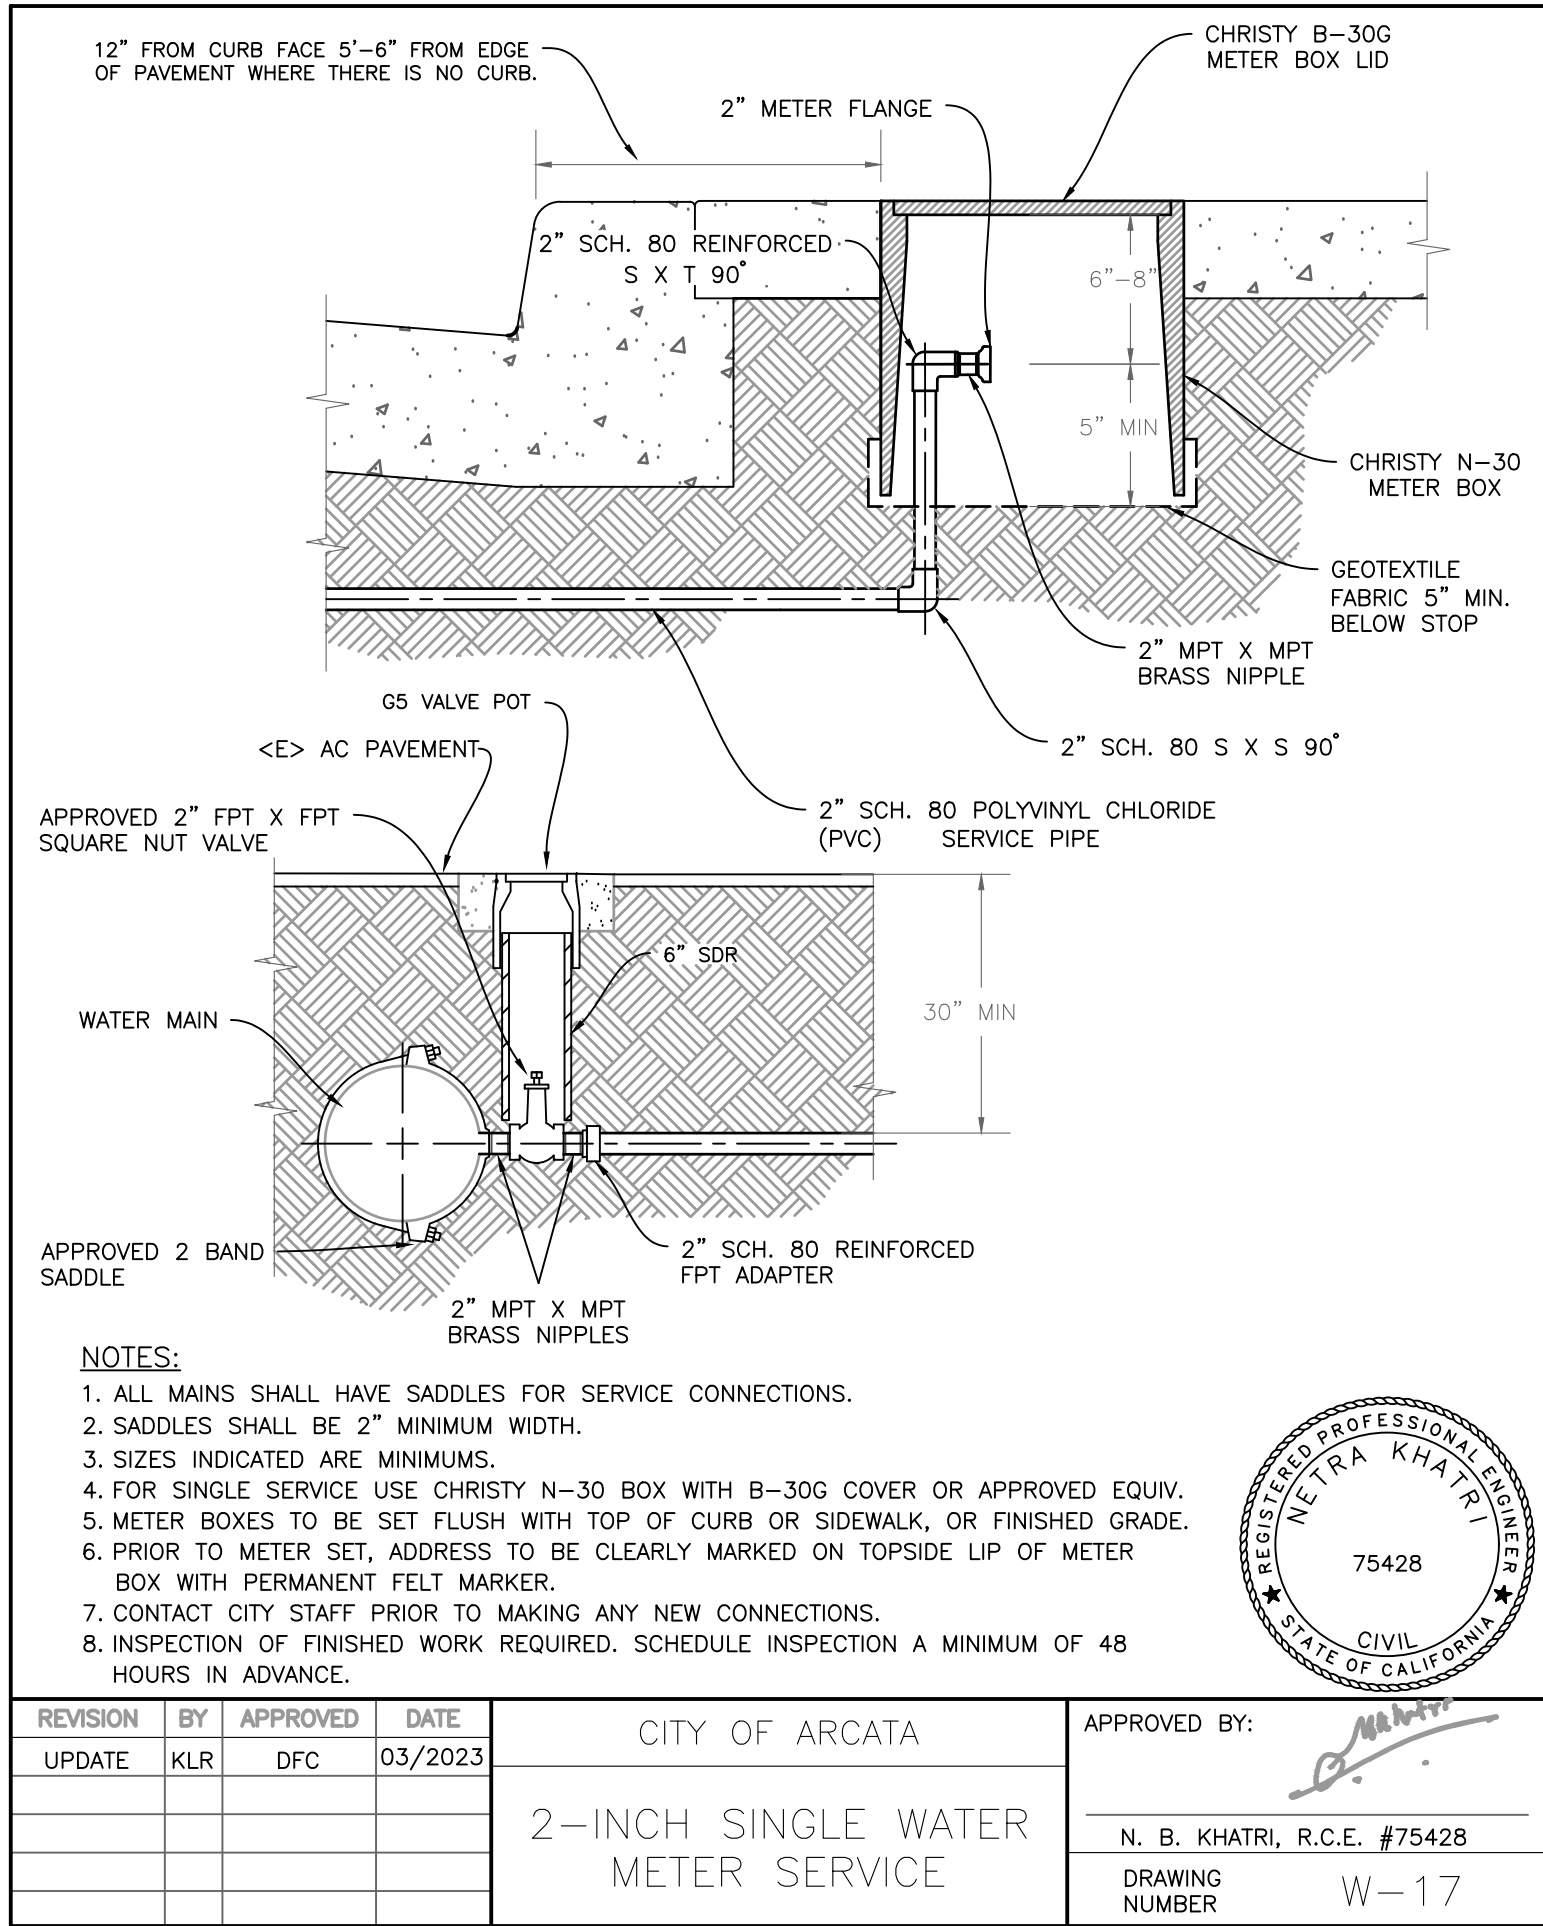

REGISTERED PROFESSIONAL ENGINEER
NETRA KHATRI
CIVIL
STATE OF CALIFORNIA
75428

City of
ARCATA

STANDARD DETAILS

Sheet Title

Project Address

VARIOUS LOCATIONS

Designed By
JONATHAN A. KIRCHUBEL

Drawn By
JONATHAN A. KIRCHUBEL

Checked By
DAVID CAISSE

Approved By
NETRA B. KHATRI

Date
JANUARY 2025








Sheet
C-503

Scale
N/A

Page
28

Project Name

STEEL WATERLINE REPLACEMENT PROJECT

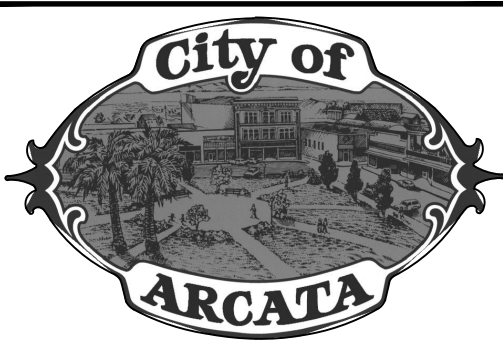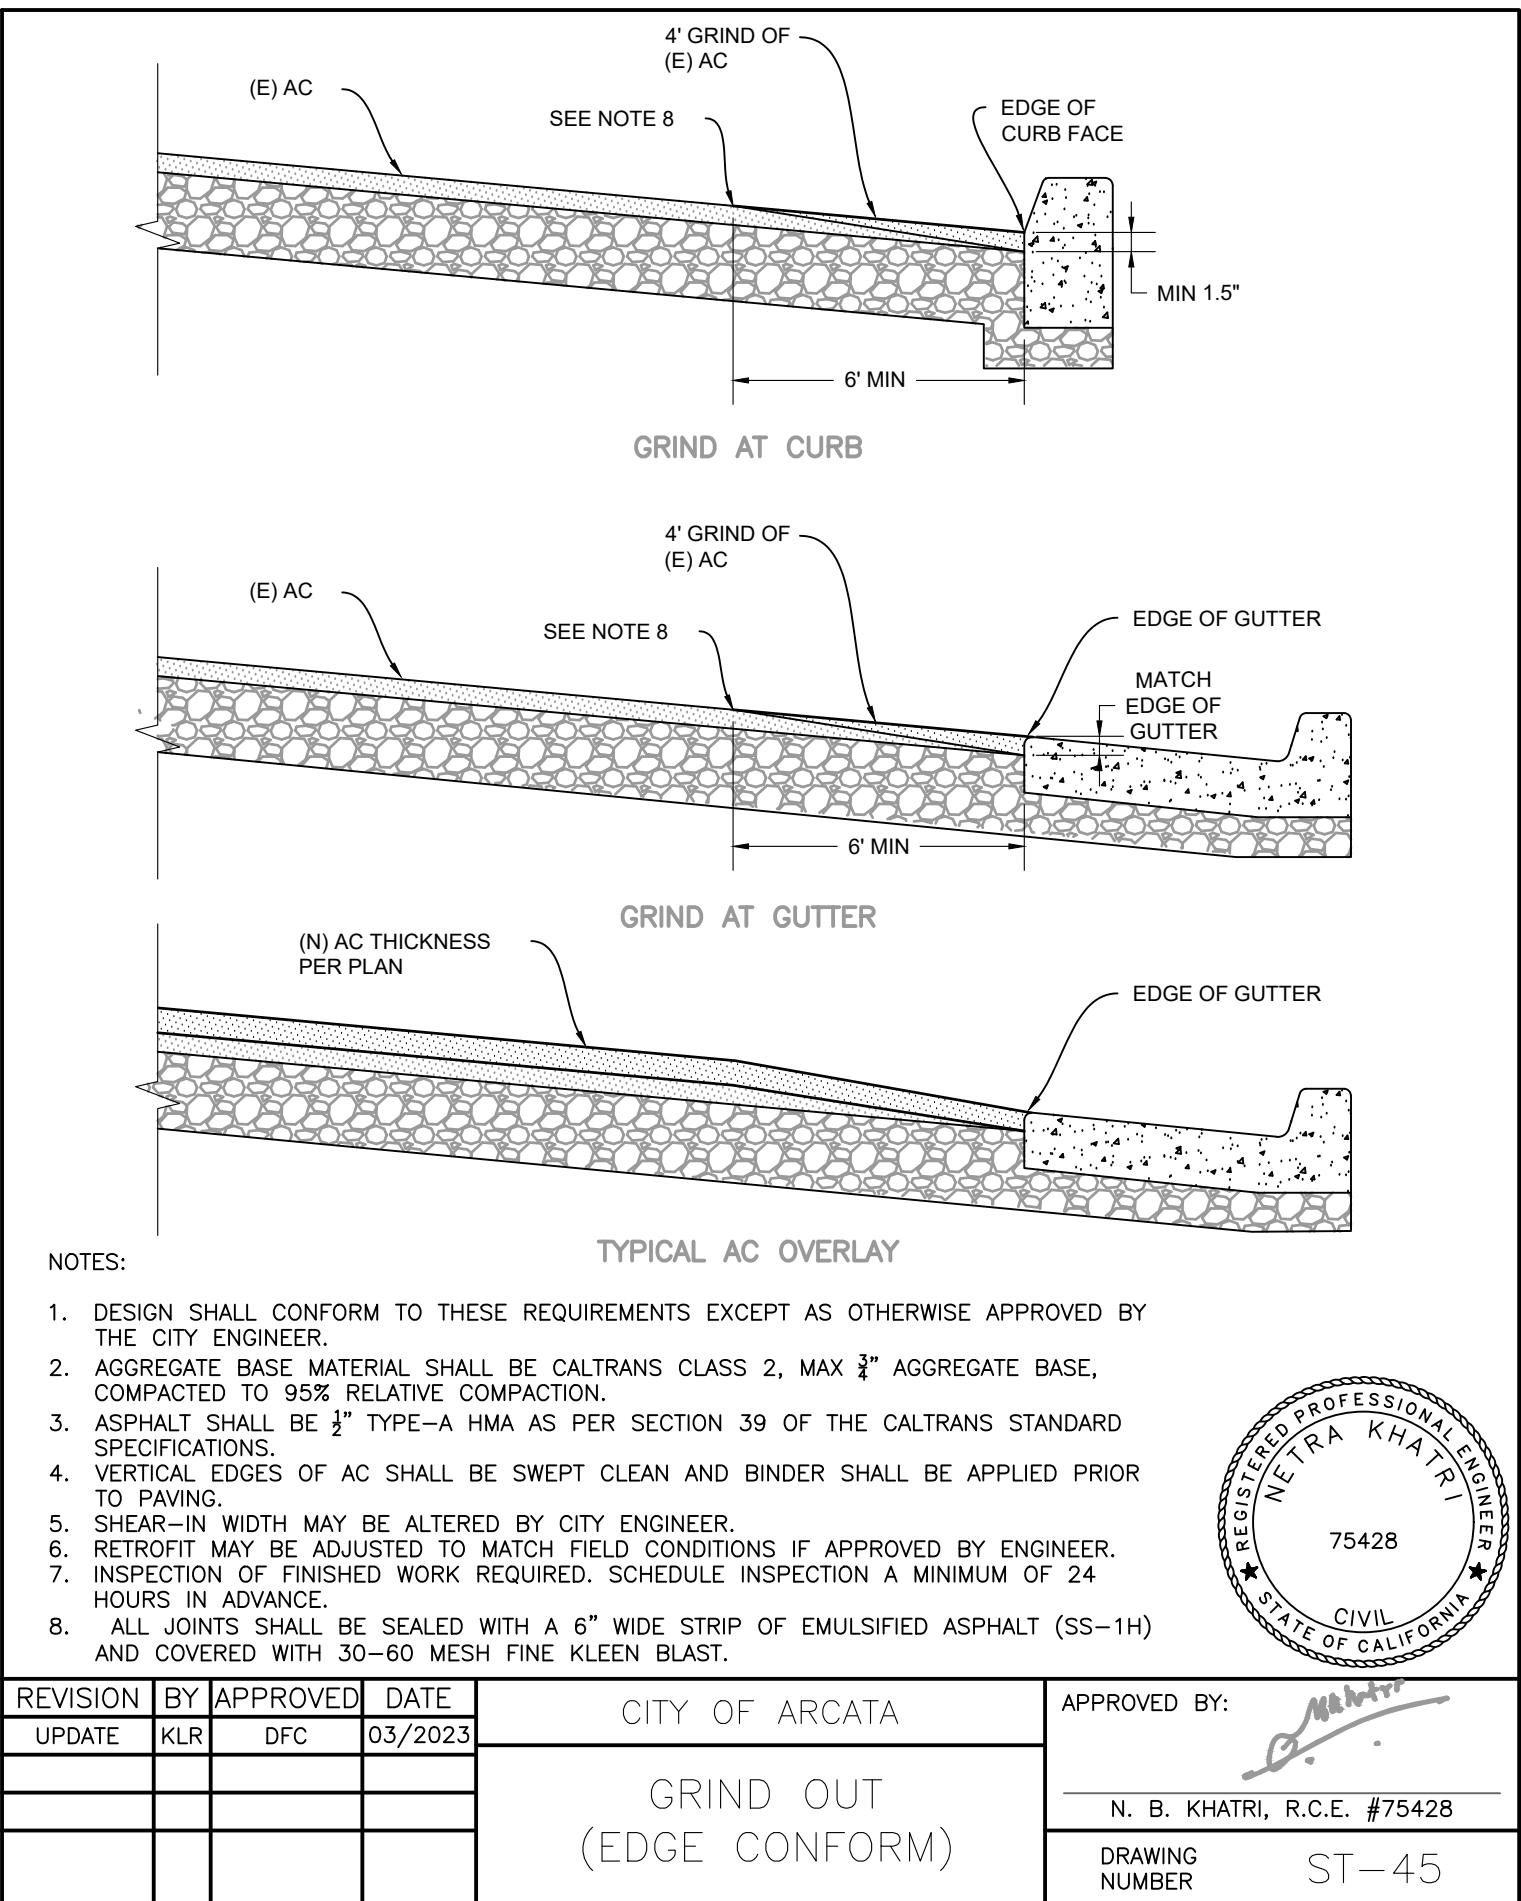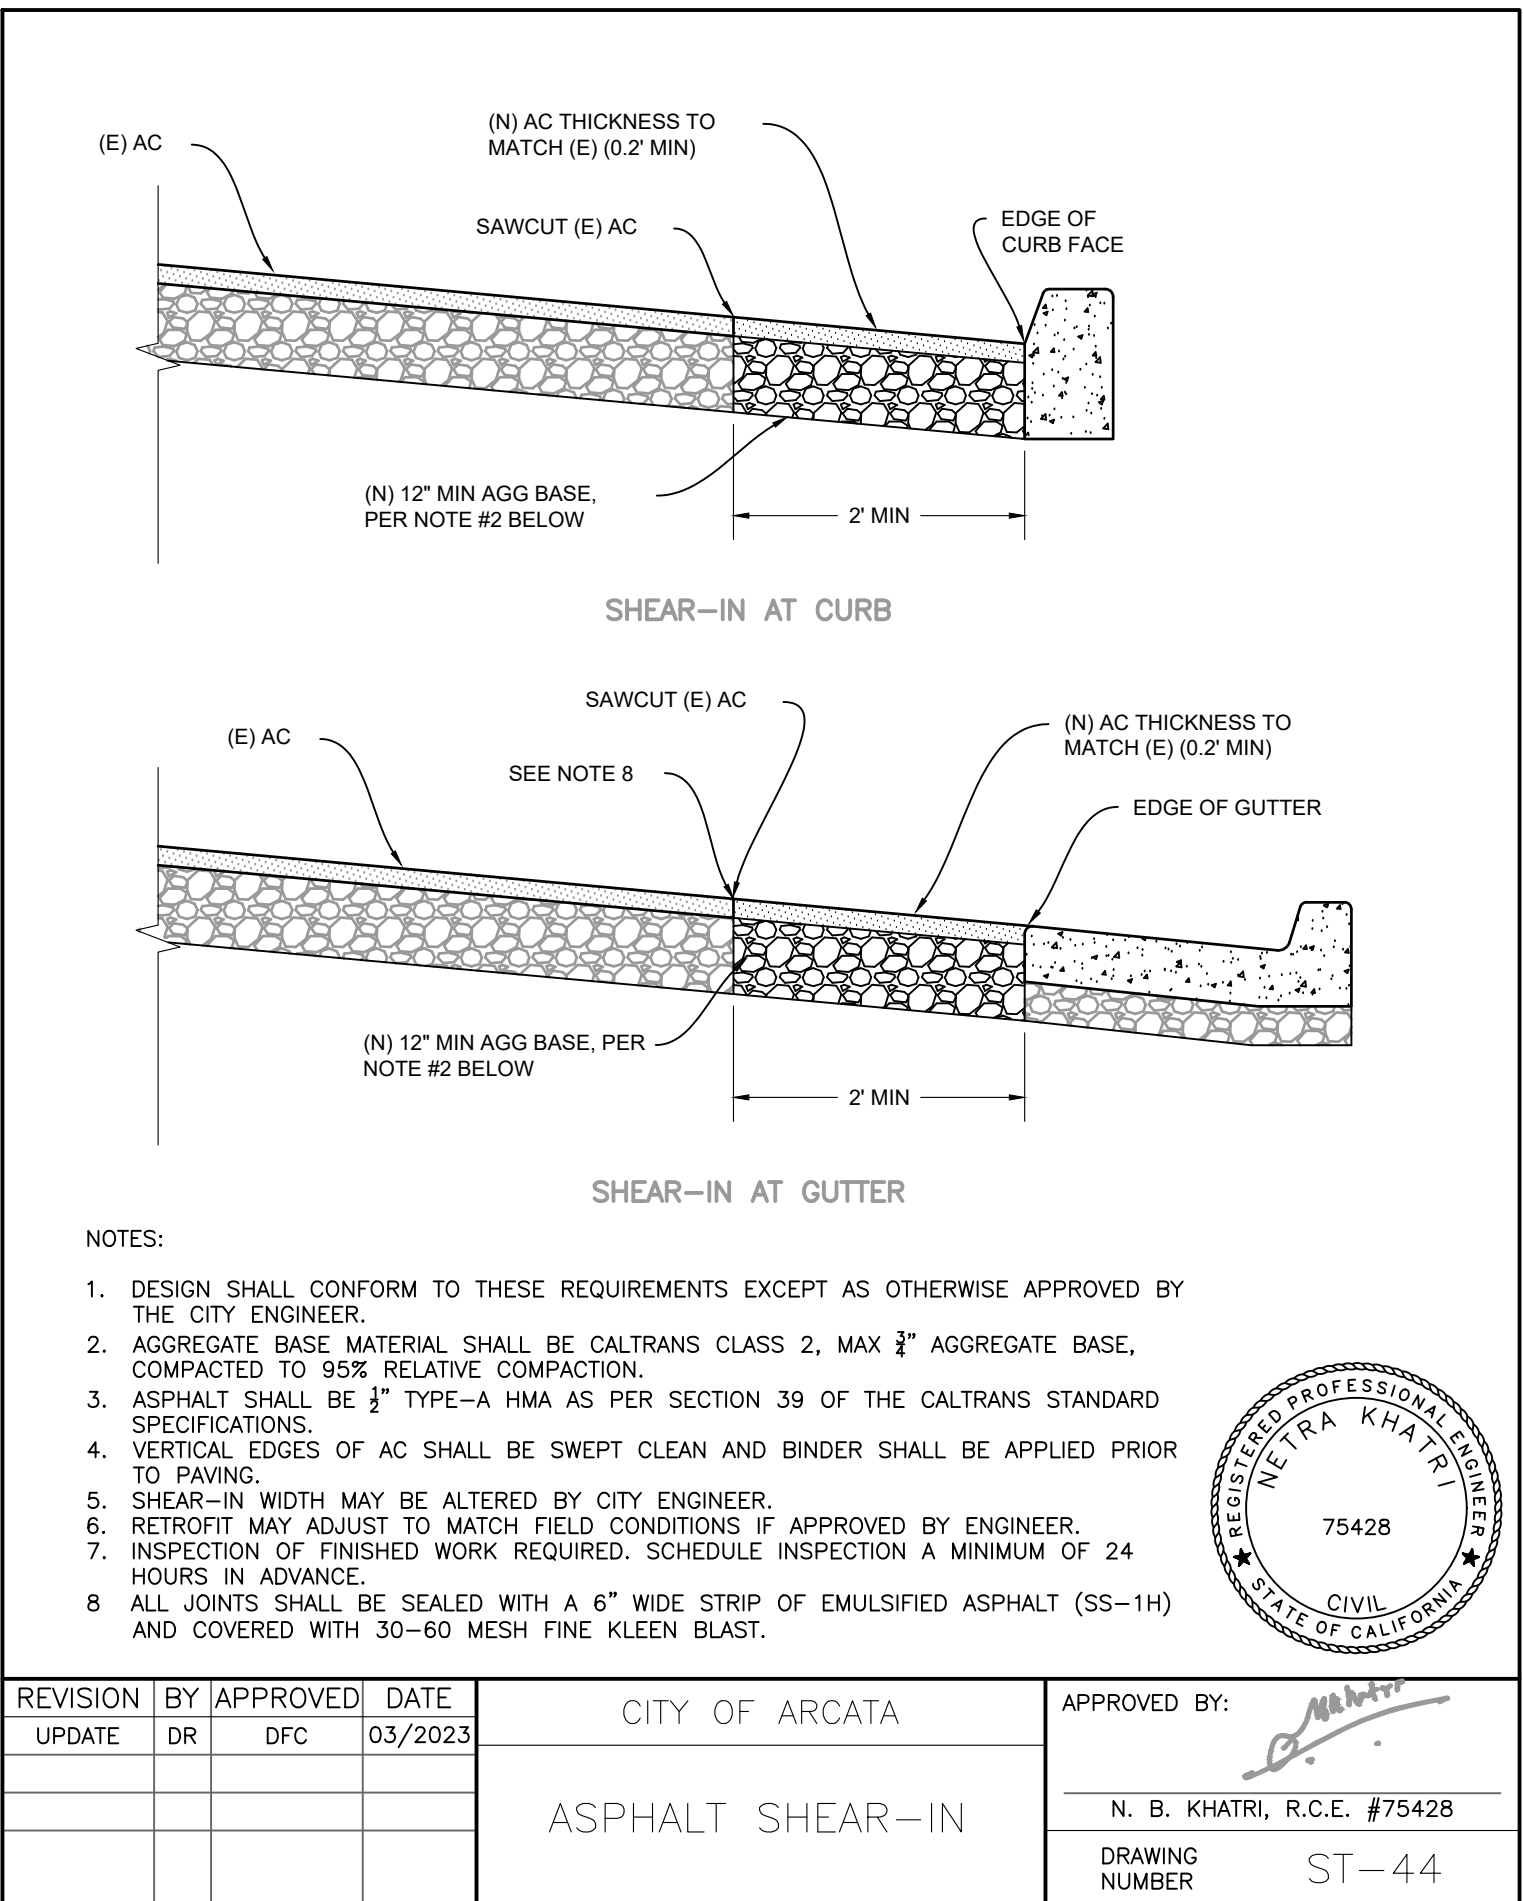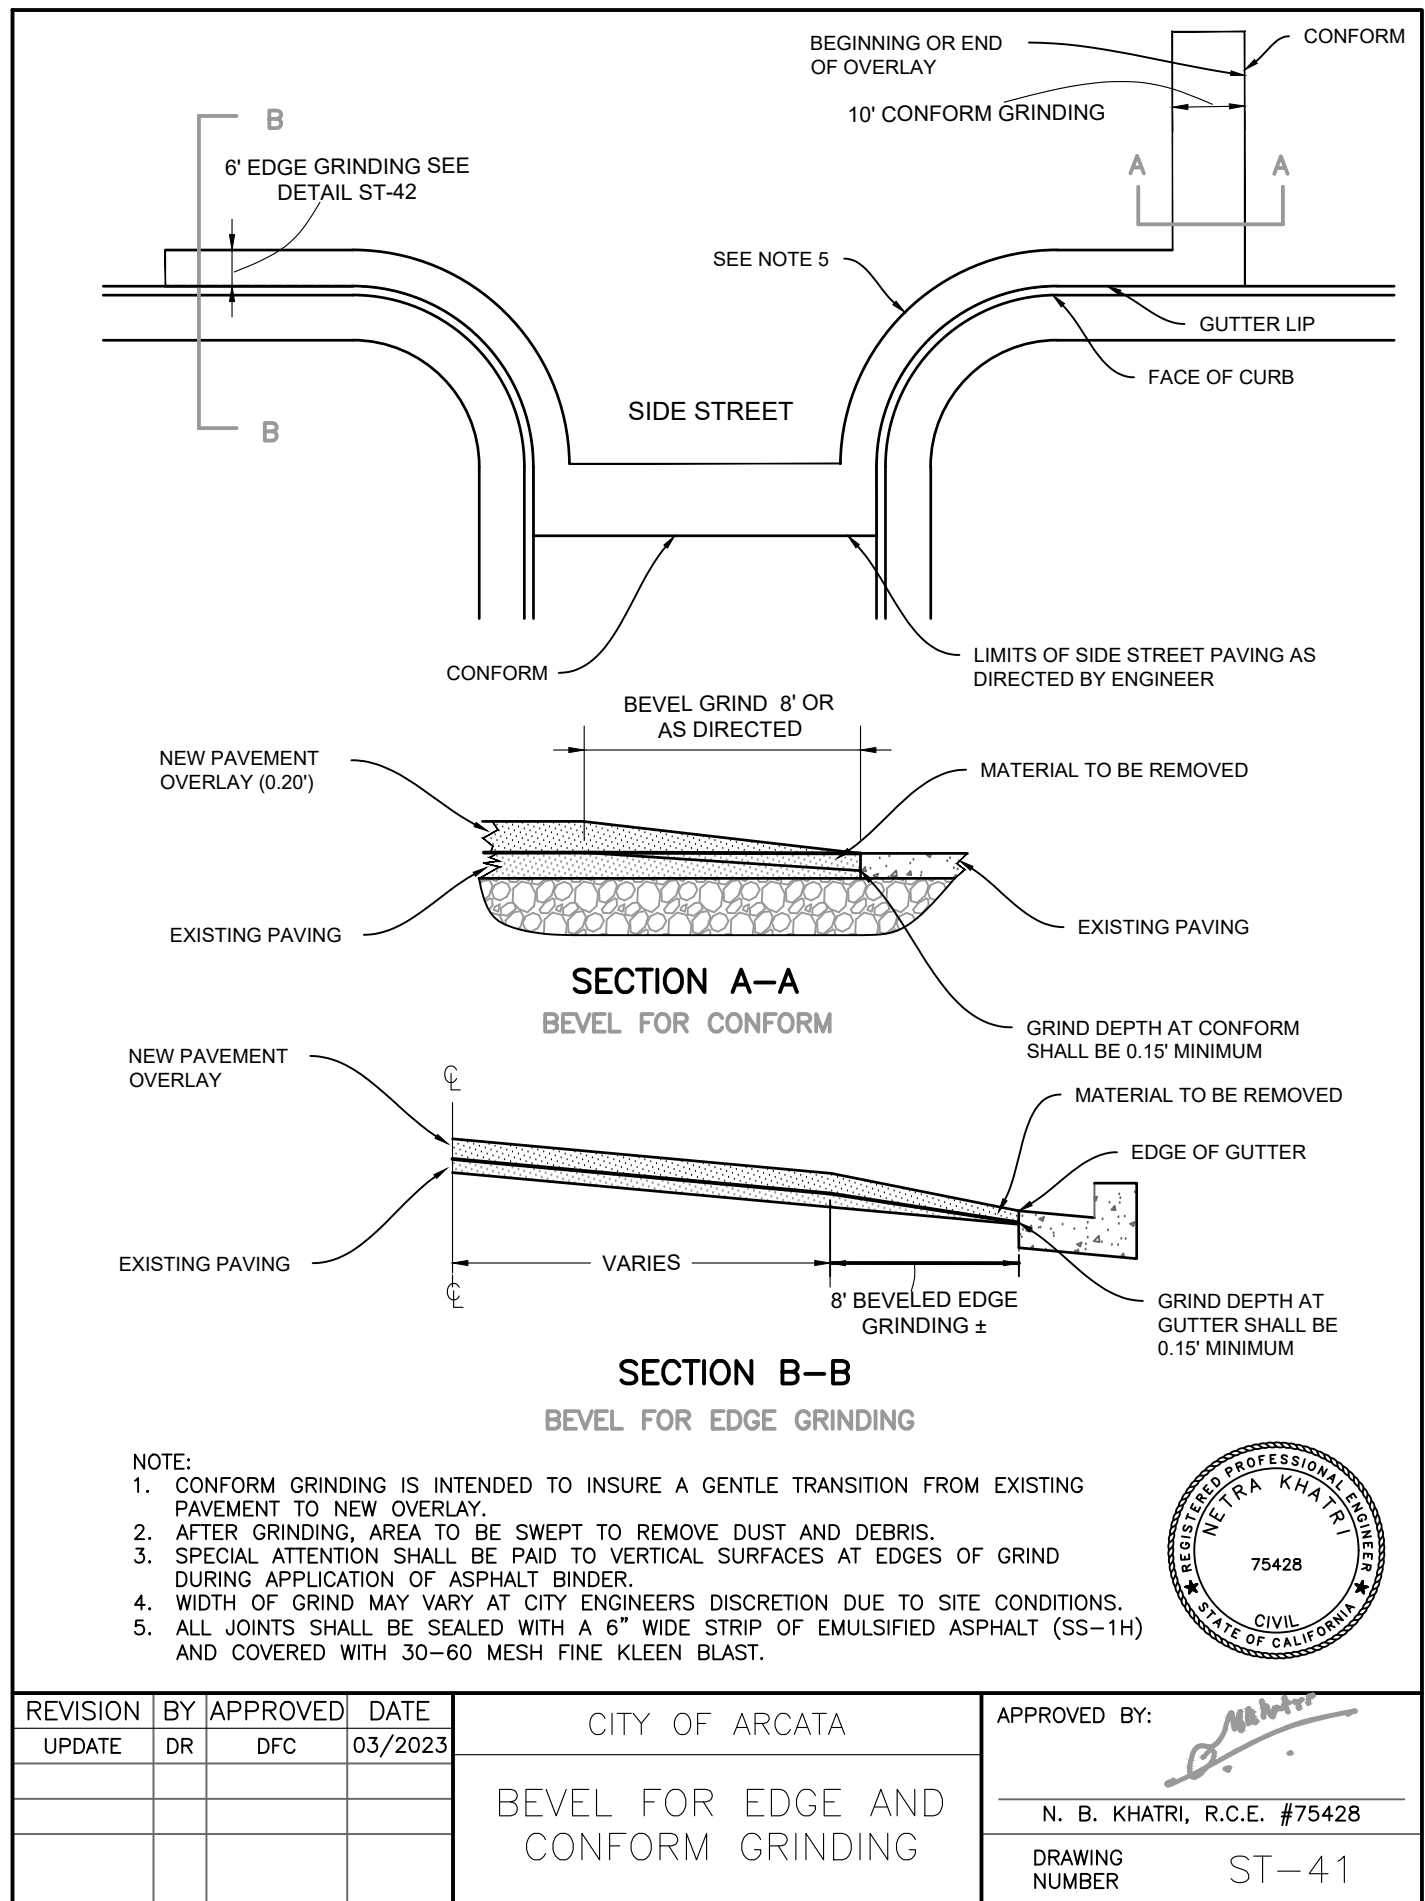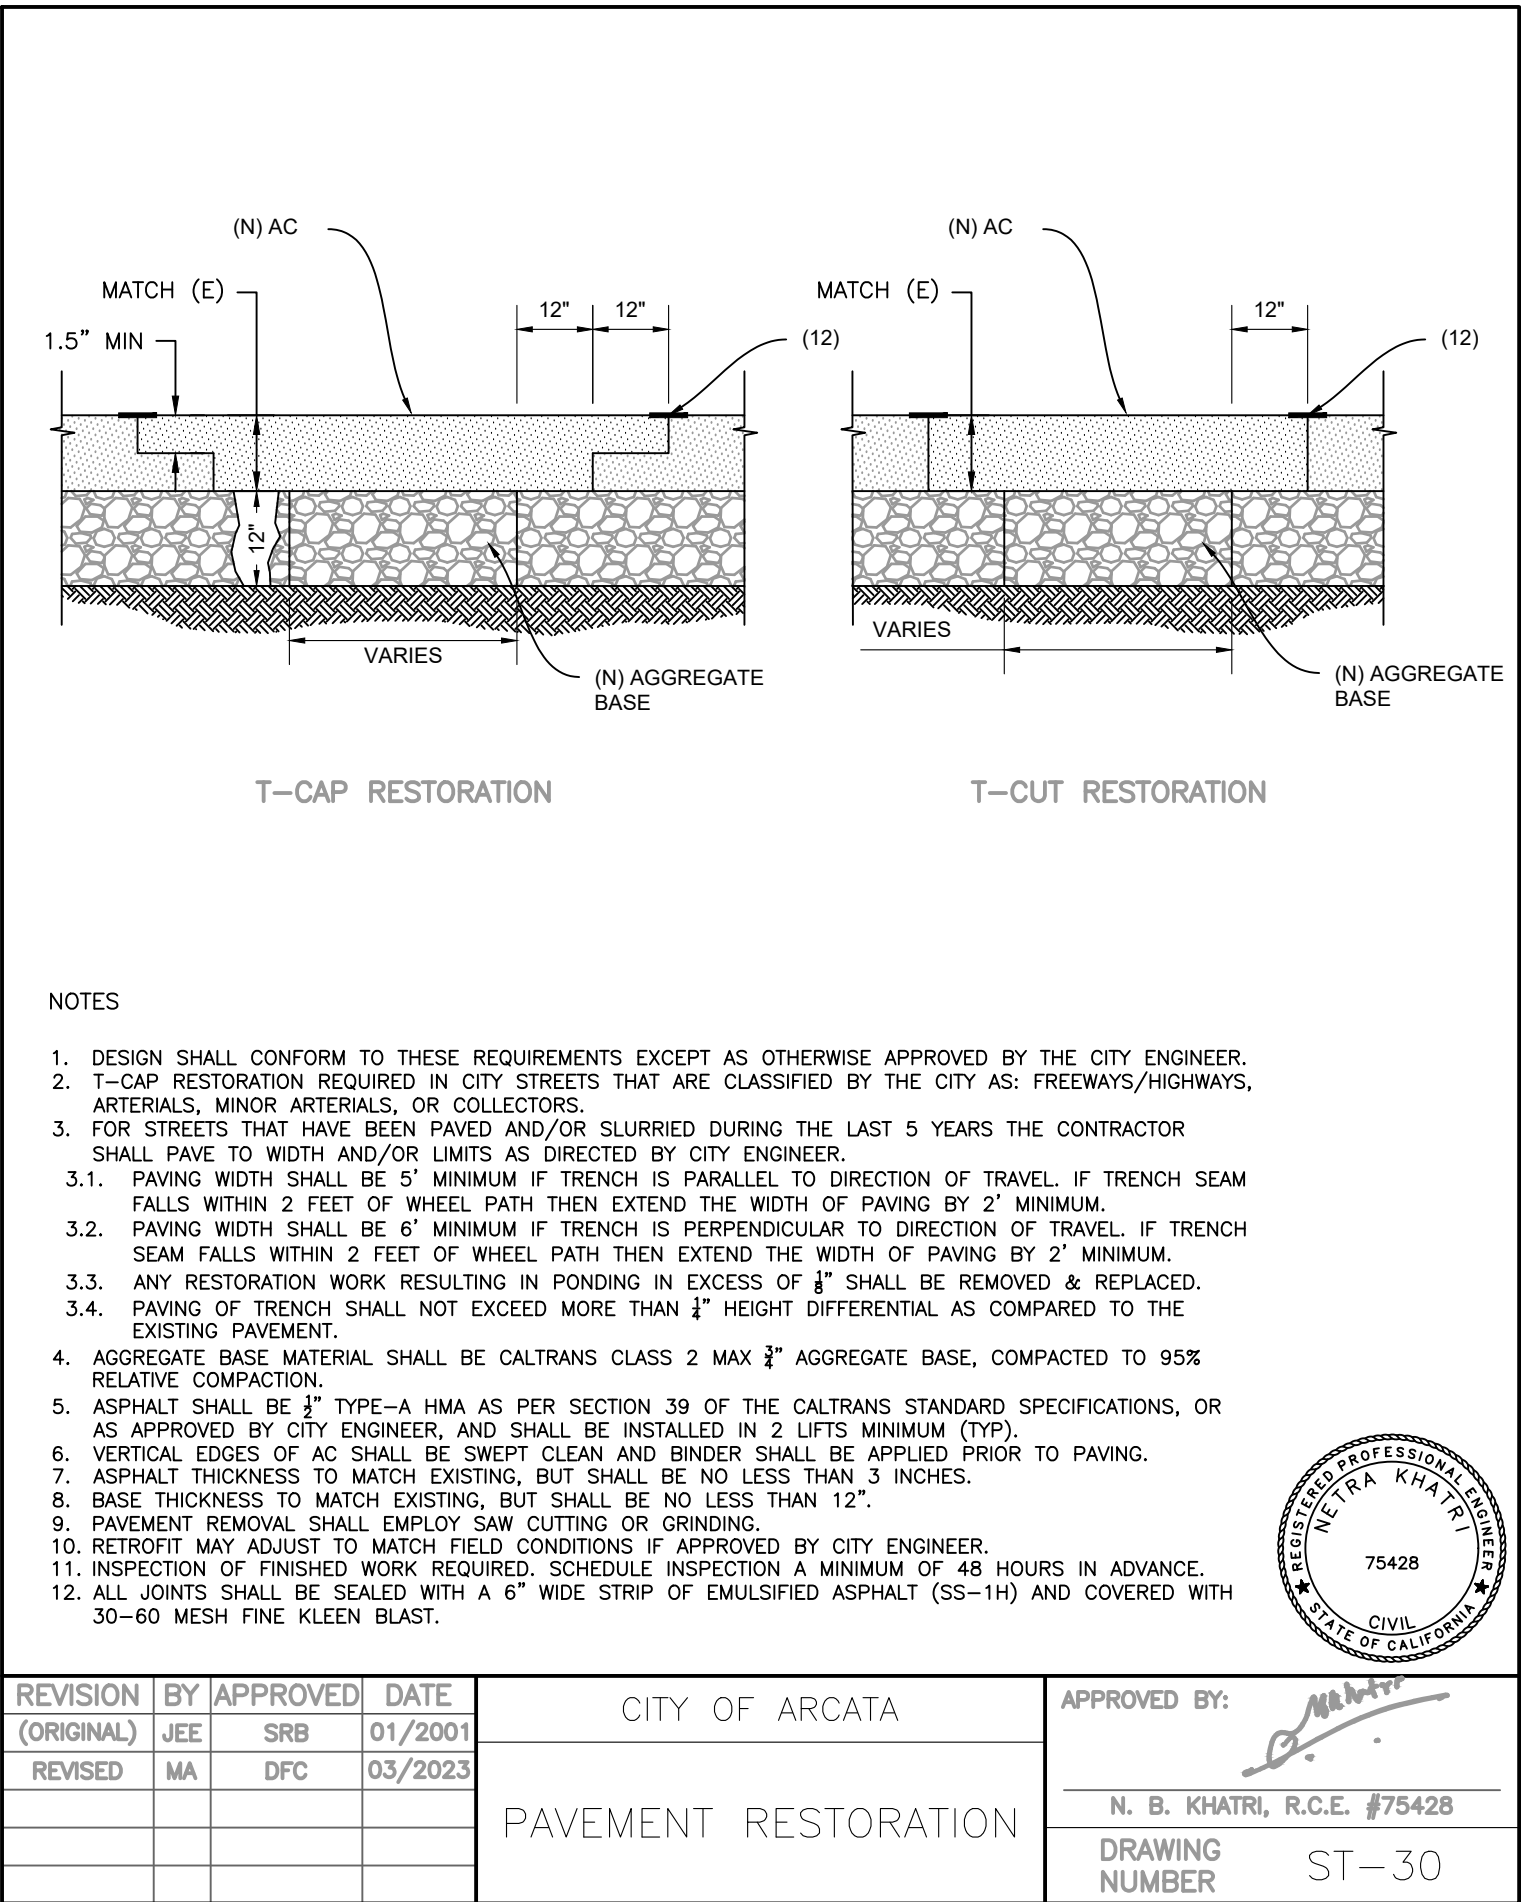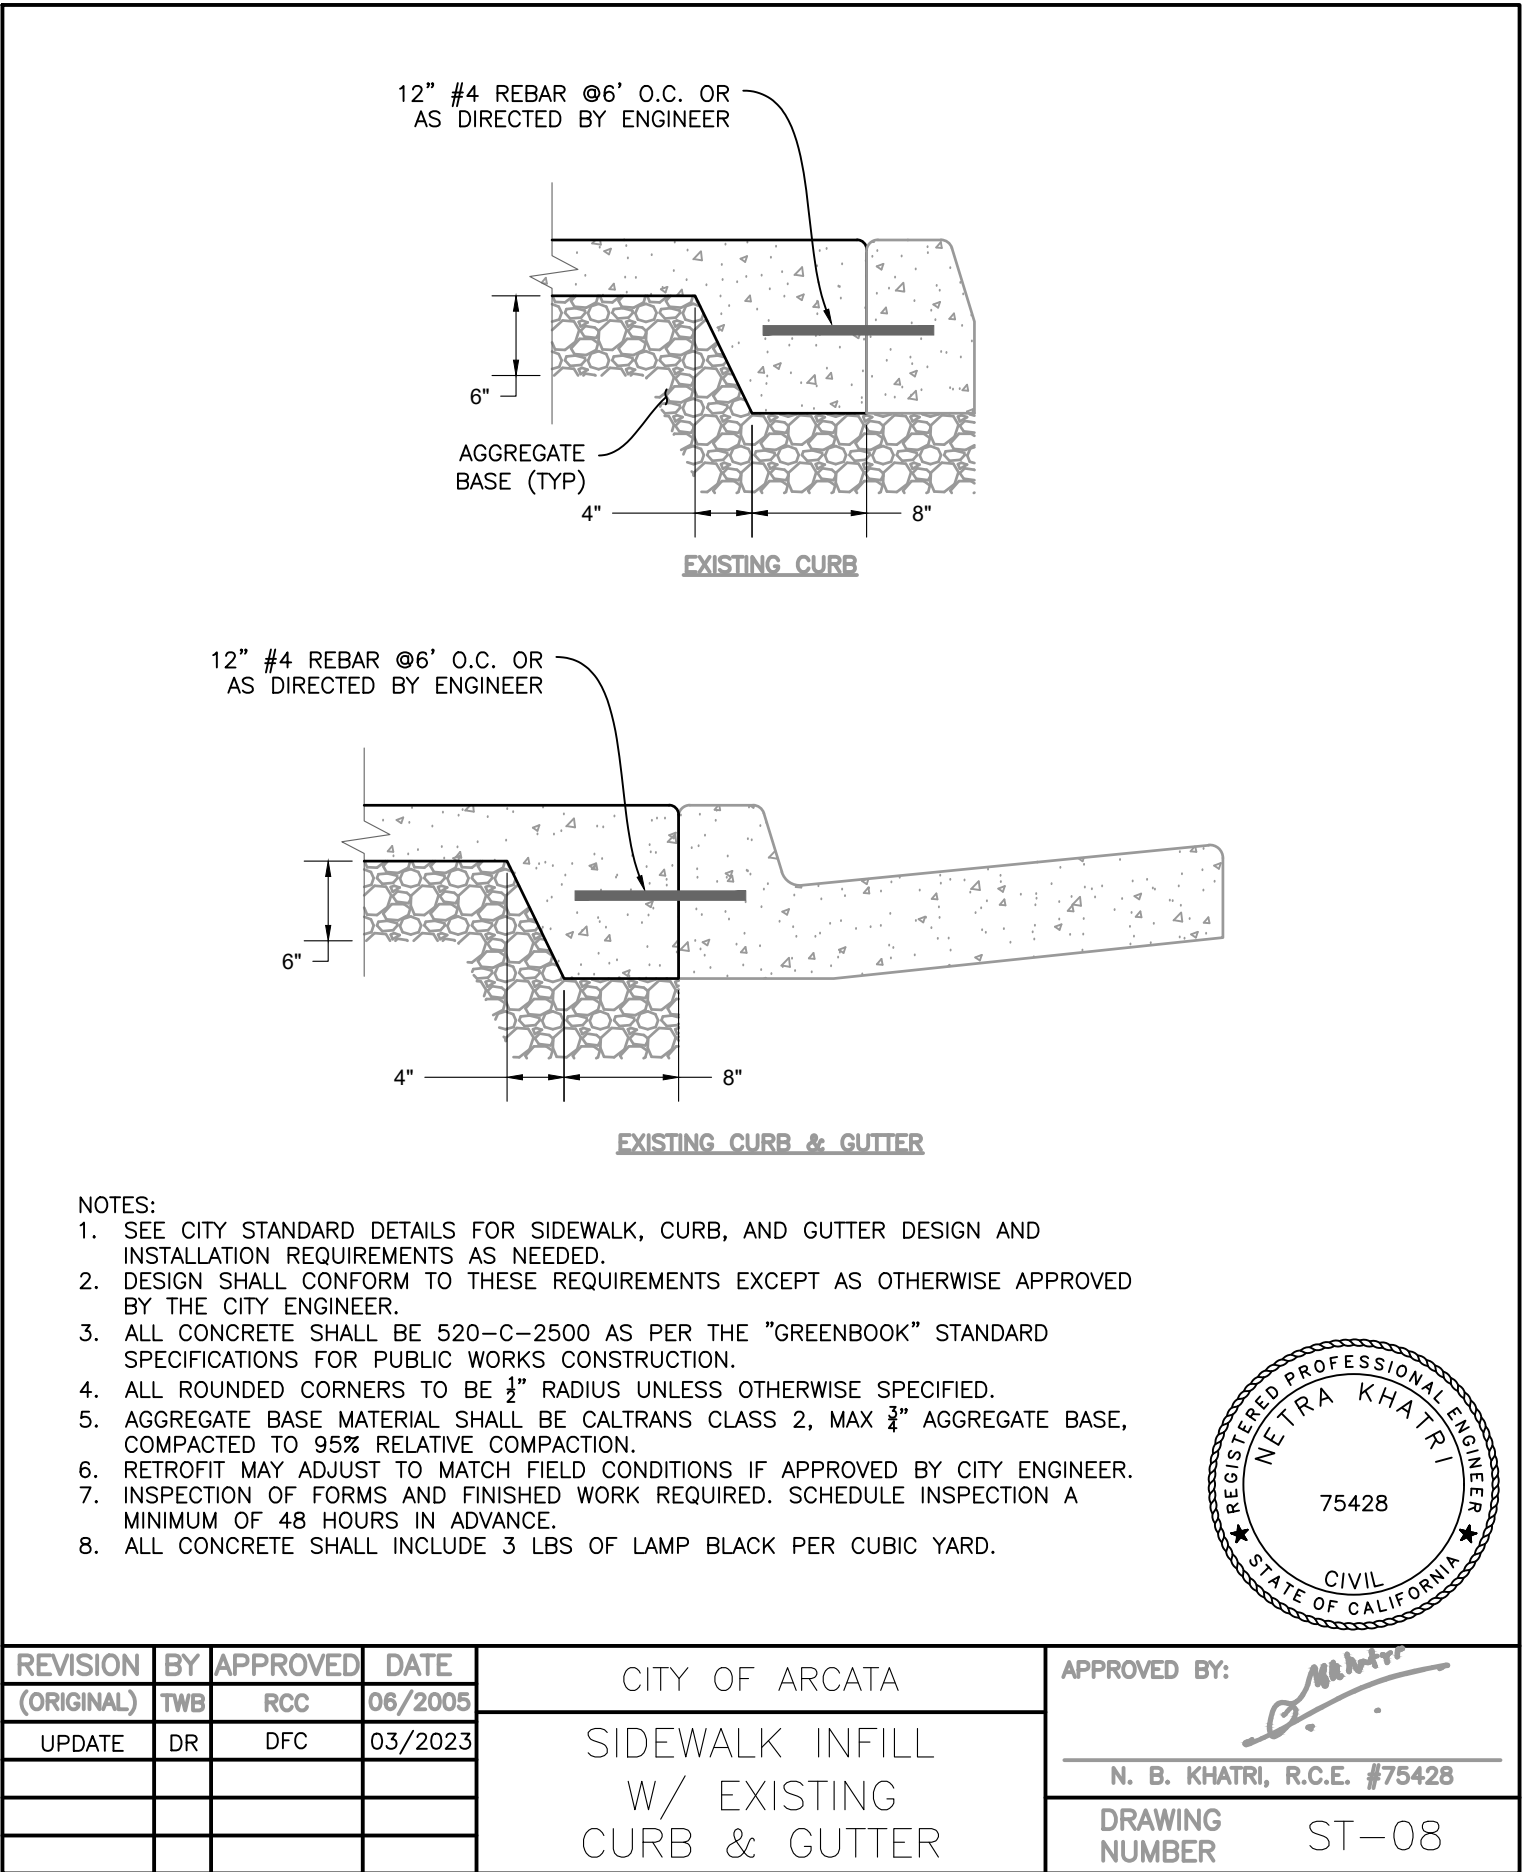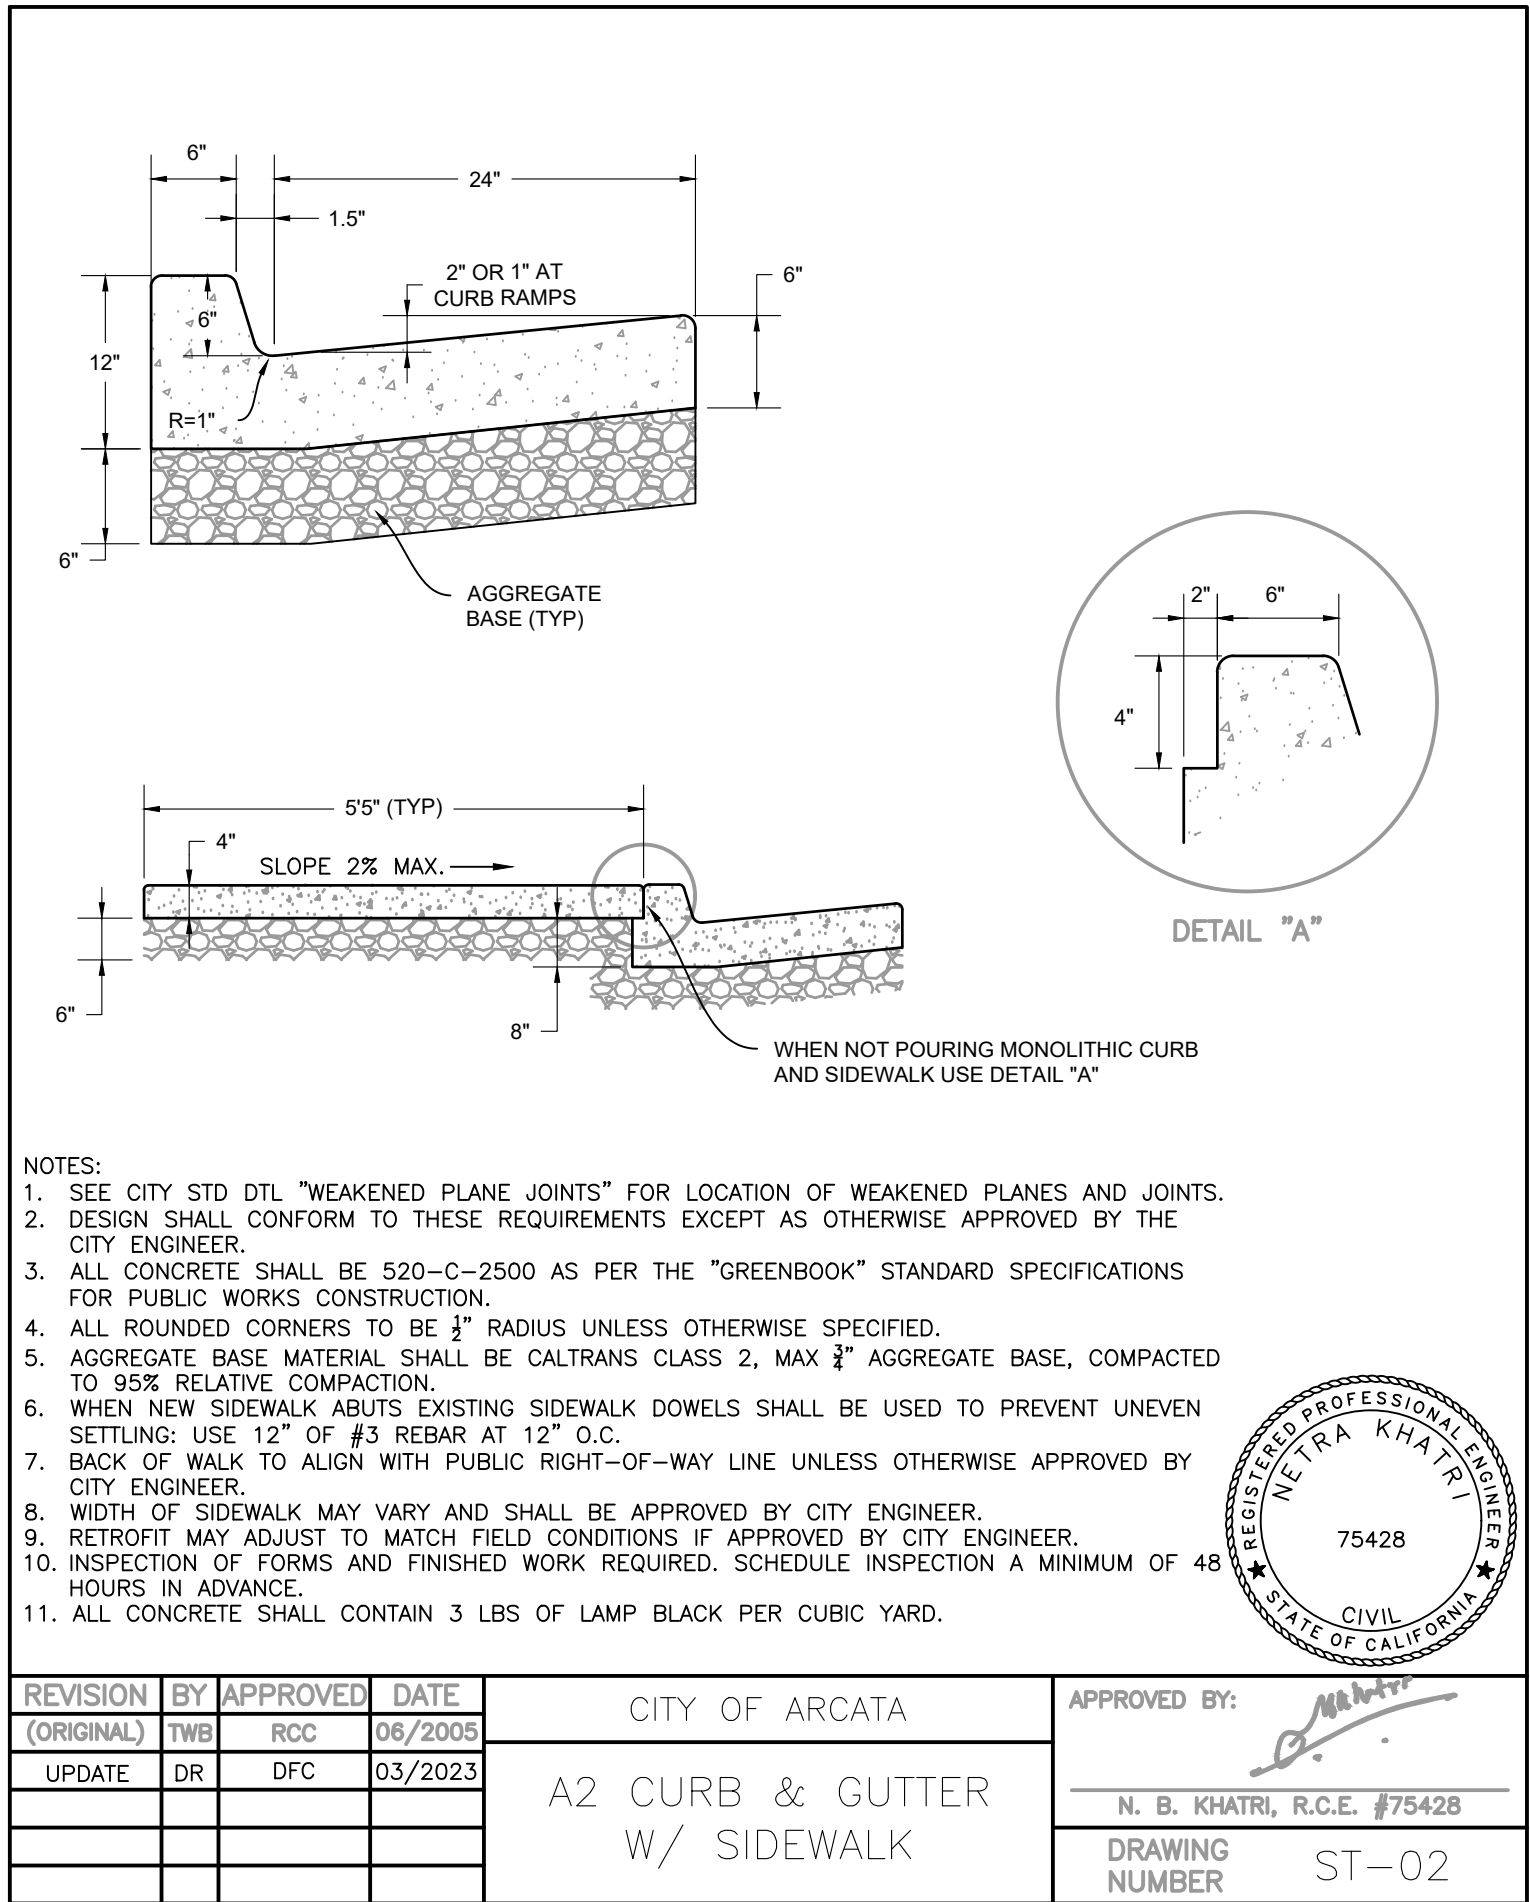


STANDARD DETAILS


STEEL WATERLINE REPLACEMENT PROJECT

Project Address	
VARIOUS LOCATIONS	
Designed By	JONATHAN A. KIRCHUBEL
Drawn By	JONATHAN A. KIRCHUBEL
Checked By	DAVID CAISSE
Approved By	NETRA B. KHATRI
Date	JANUARY 2025
Sheet	C-504
Scale	N/A
Page	29

DETAIL FOR PRESSURE REDUCING
VALVE VAULT ON SHIRLEY BLVD

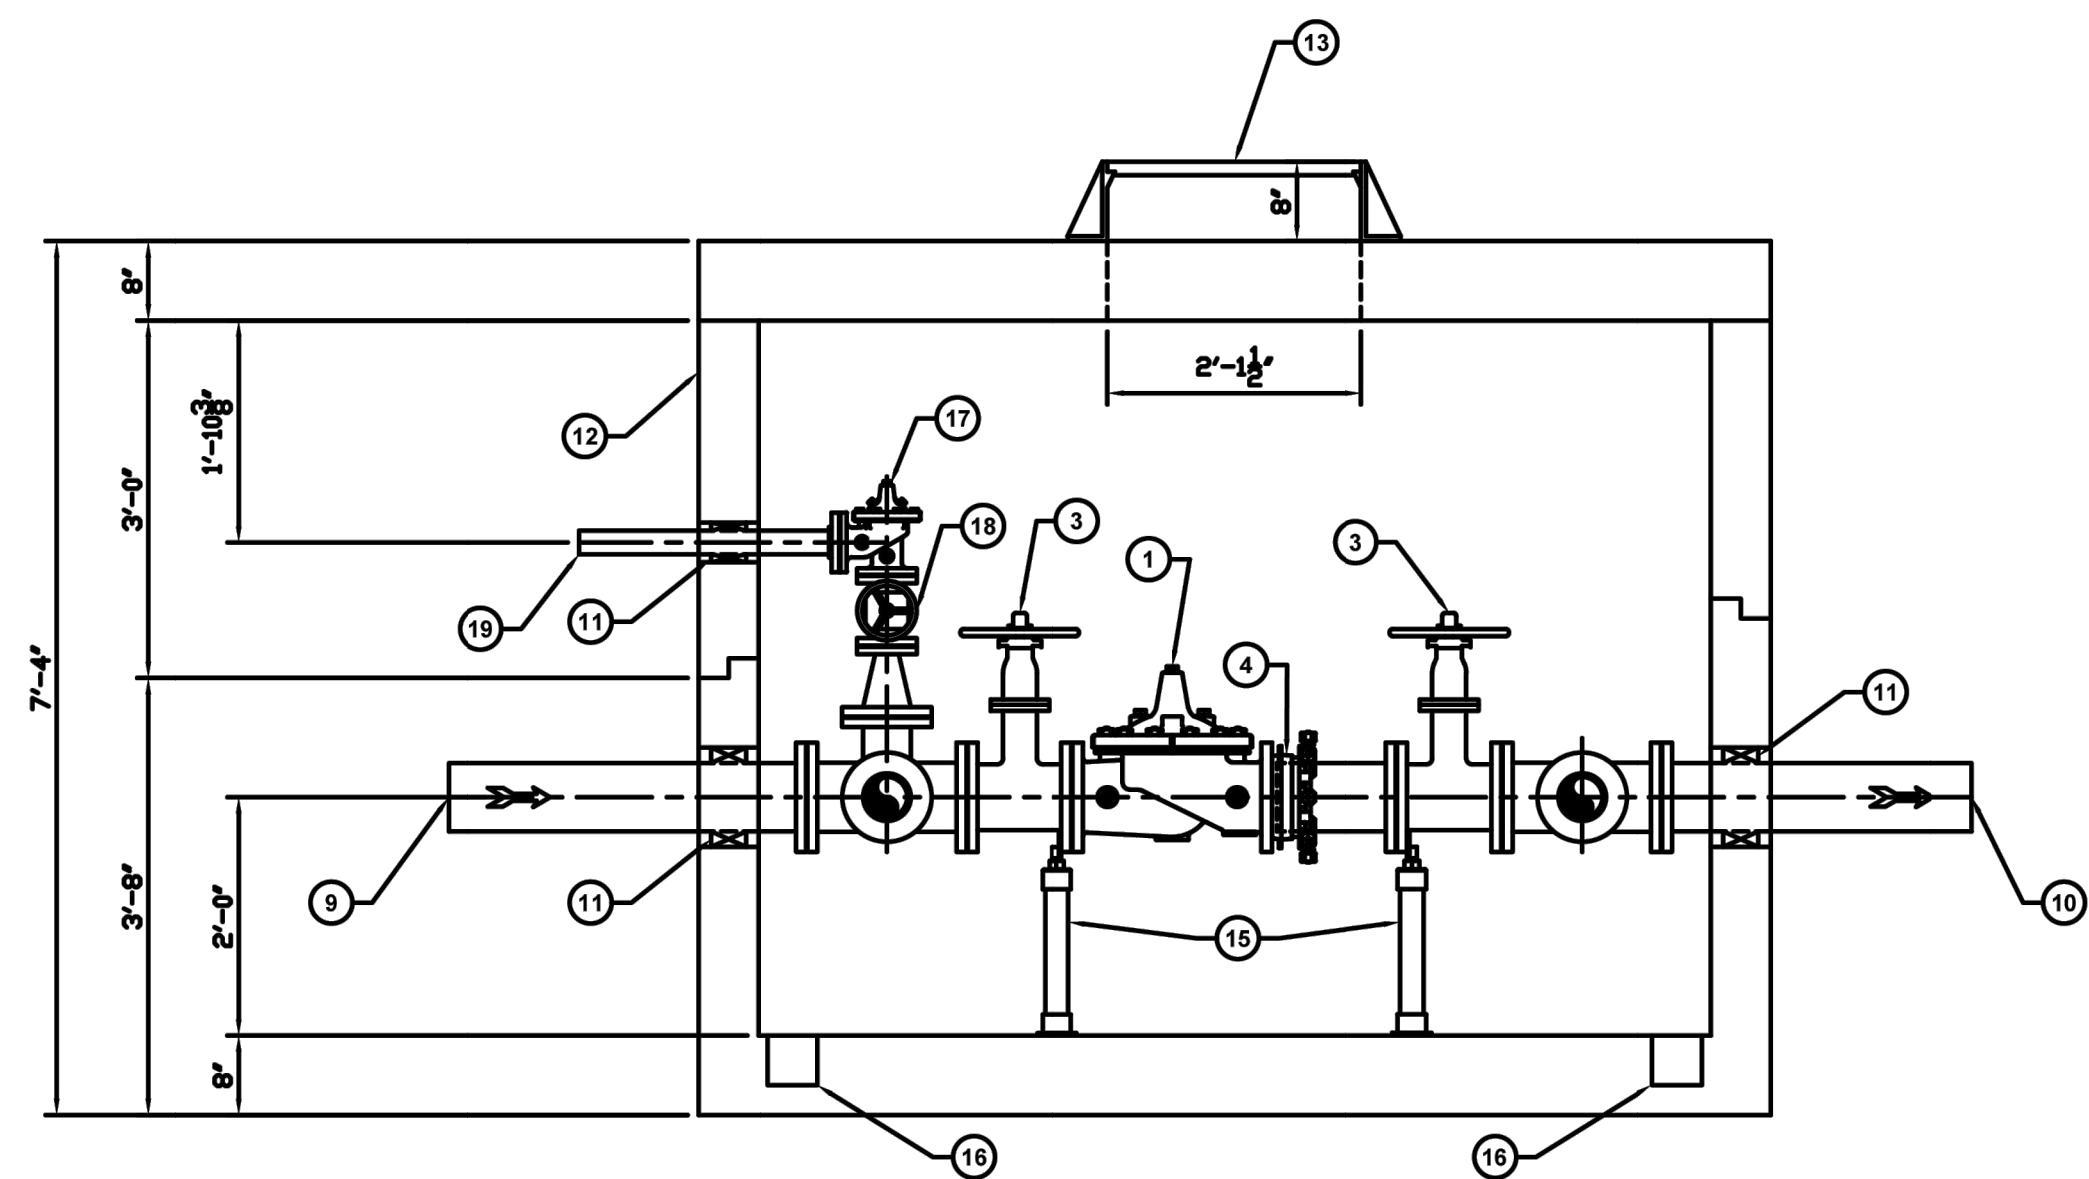

SECTION A-A

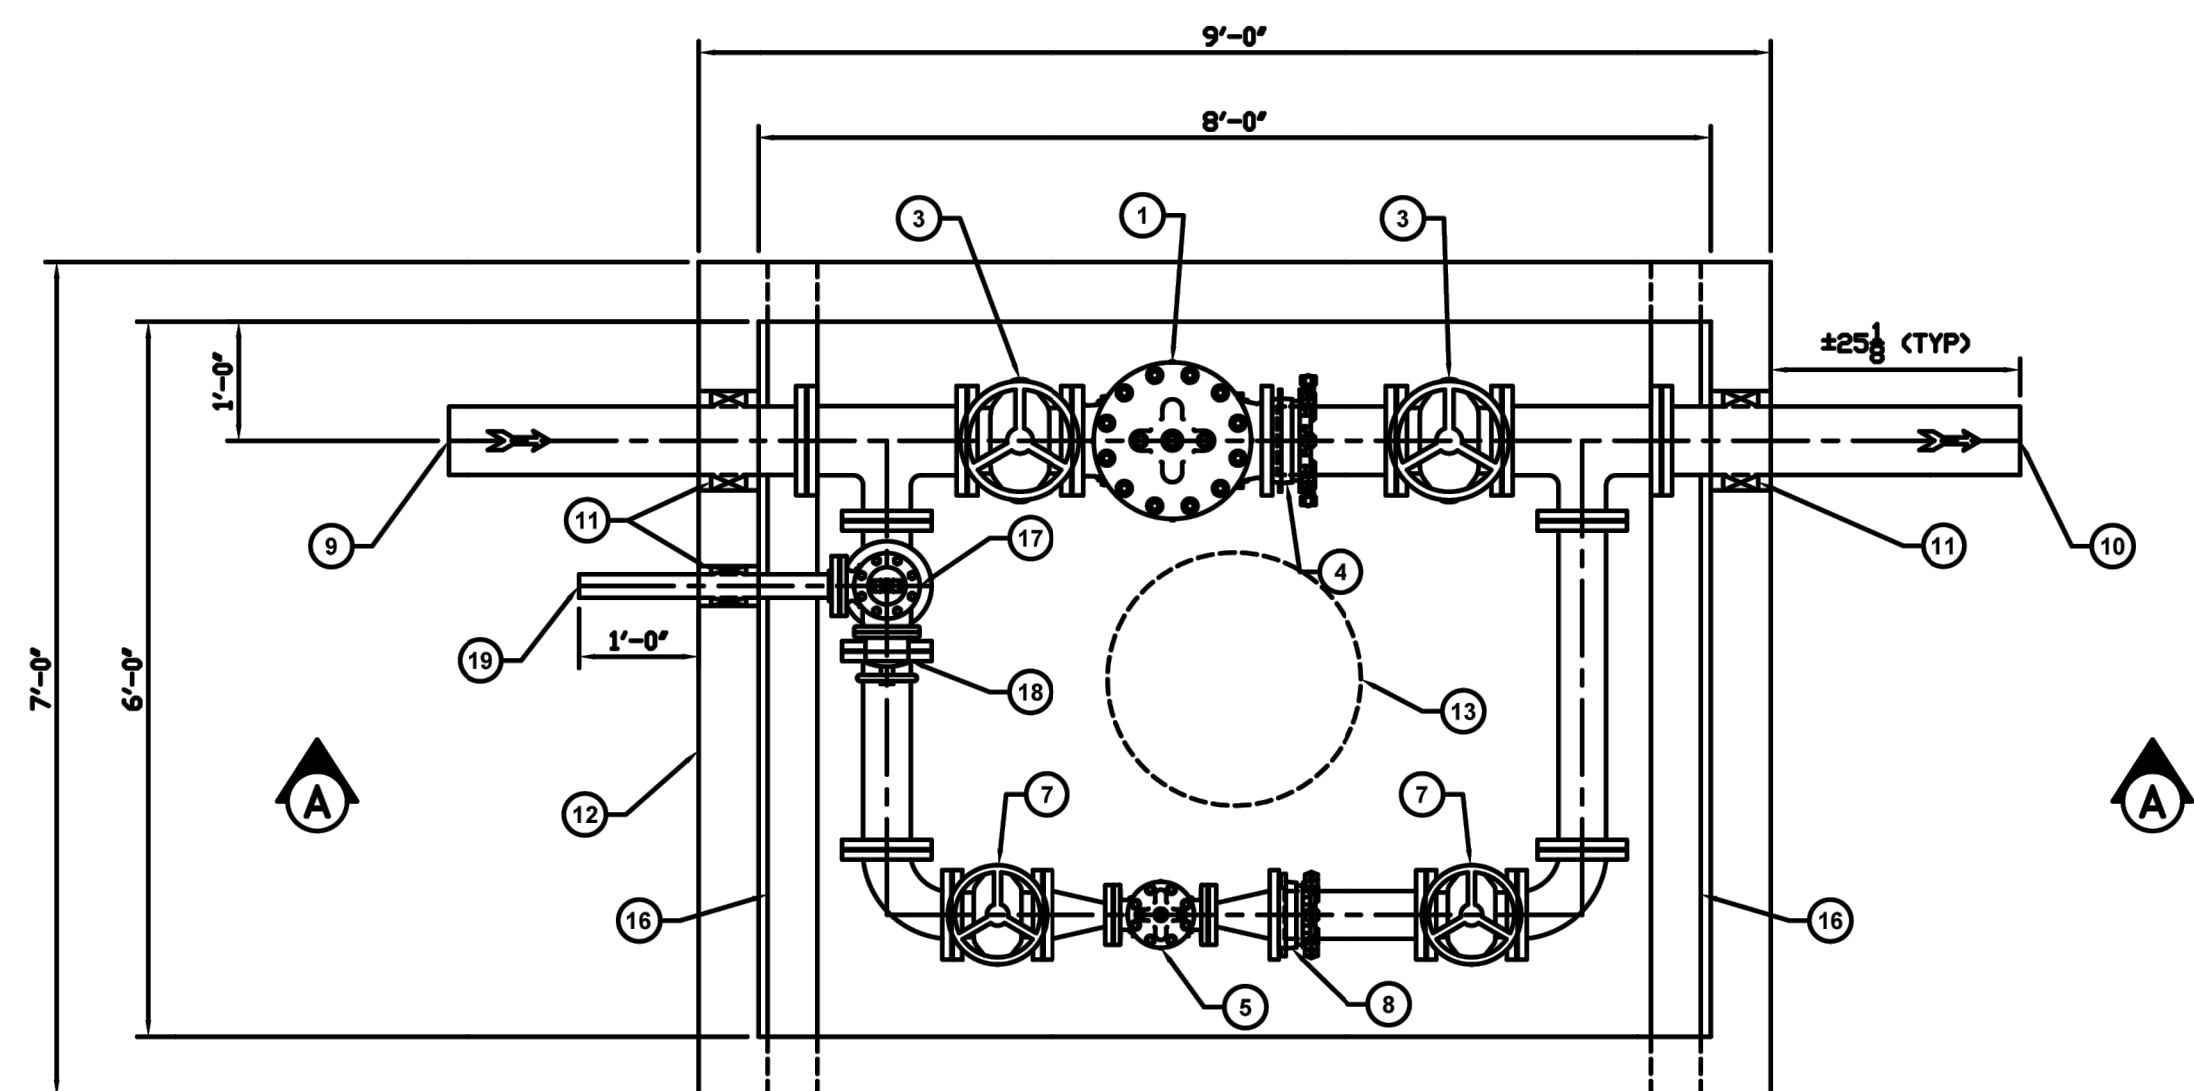

PLAN VIEW

BILL OF MATERIALS		
ITEM	QTY	DESCRIPTION
1	1	6" CLA-VAL 90 SERIES PRESSURE REDUCING VALVE
2		NOT USED
3	2	6" NRS GATE VALVE (OPEN LEFT)
4	1	6" RESTRAINED FLANGE ADAPTER
5	1	2" CLA-VAL 90 SERIES PRESSURE REDUCING VALVE
6	1	NOT USED
7	2	4" NRS GATE VALVE (OPEN LEFT)
8	1	4" RESTRAINED FLANGE ADAPTER
9	1	6" DUCTILE IRON PIPE INLET
10	1	6" DUCTILE IRON PIPE OUTLET
11	3	PIPE PENETRATION SEAL
12	1	PRECAST CONCRETE VAULT
13	1	MANHOLE COVER AND FRAME
14		NO USED
15	4	PIPE SUPPORTS
16	2	TRENCH DRAIN WITH GRATING AND 4" FEMALE SOCKET CONNECTION ON THE EXTERIOR OF BOTH SIDES
17	1	2" CLA-VAL MODEL 50-01 PRESSURE RELIEF VALVE
18	1	2" NRS GATE VALVE (OPEN LEFT)
19	1	2" STAINLESS STEEL PIPE RELIEF OUTLET

NOTES: FITTINGS ARE DUCTILE IRON IN ACCORDANCE WITH ANSI/AWWA C110/A21.10. FLANGES ARE ANSI CLASS 125, B16.1.

PIPE SPOOLS ARE CL53 DUCTILE IRON WITH FLANGES IN ACCORDANCE WITH ANSI/AWWA C115/A21.15. FLANGES ARE ANSI CLASS 125, B16.1.

2" AND SMALLER PIPE/FITTINGS ARE STAINLESS STEEL.

INTERIOR COATING MEETS THE REQUIREMENT OF NSF-61 STANDARD.

EXTERIOR COATING TO BE A 2-PART EPOXY.


THE VAULT WILL BE DELIVERED IN THREE (3) SECTIONS. OFF-LOADING AND SETTING OF EACH SECTION BY INSTALLING CONTRACTOR, NOT ESI FAB SYSTEMS. THE HEAVIEST LIFT WILL BE APPROXIMATELY 15,000 POUNDS.

JOINT SEALANT WILL BE SUPPLIED FOR INSTALLATION BY CONTRACTOR BETWEEN THE THREE (3) SECTIONS.

ESI FAB SYSTEMS
15410 S MAHAFFIE ST
OLATHE, KS 66062
PH: 816-468-9119 - www.esiwater.com

EPS07573 - REV: 1

PROJECT:
CITY OF ARCATA

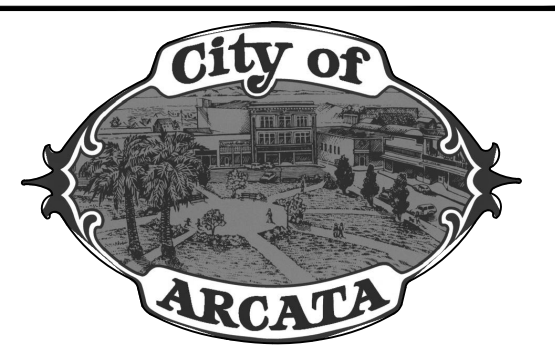

STANDARD DETAILS

STEEL WATERLINE REPLACEMENT PROJECT

Project Address

VARIOUS LOCATIONS

Designed By

JONATHAN A. KIRCHUBEL

Drawn By

JONATHAN A. KIRCHUBEL

Checked By

DAVID CAISSE

Approved By

NETRA B. KHATRI

Date

JANUARY 2025

Sheet

C-505





Scale

N/A

Page

30

STANDARD DETAILS ADDED THROUGH ADDENDA

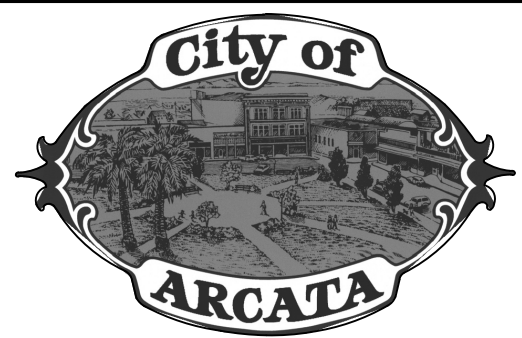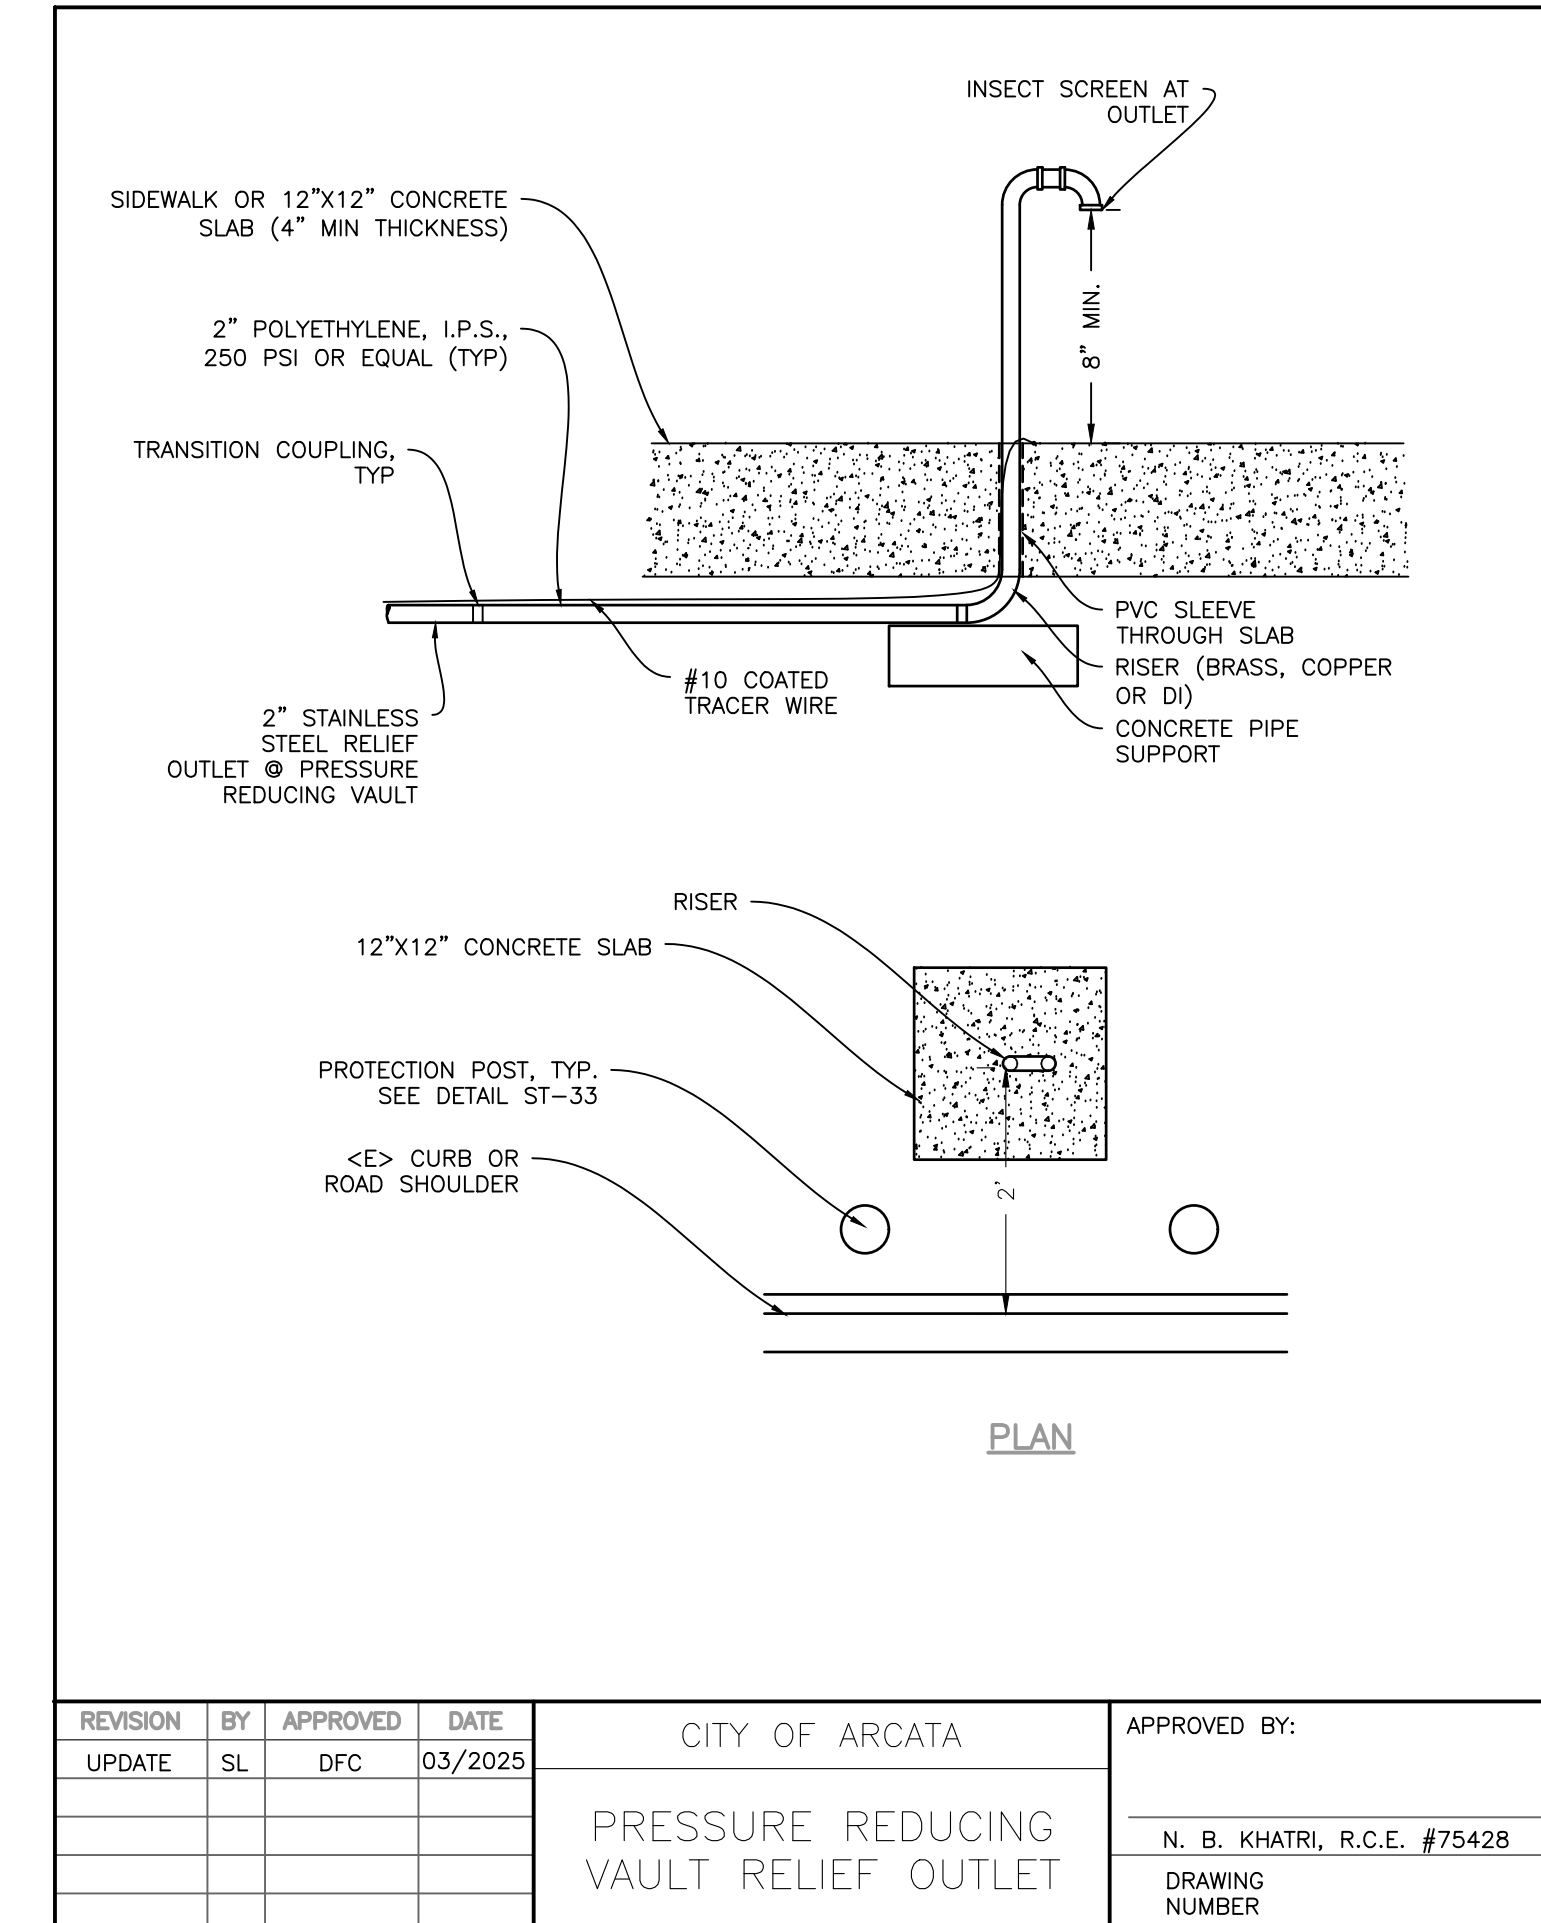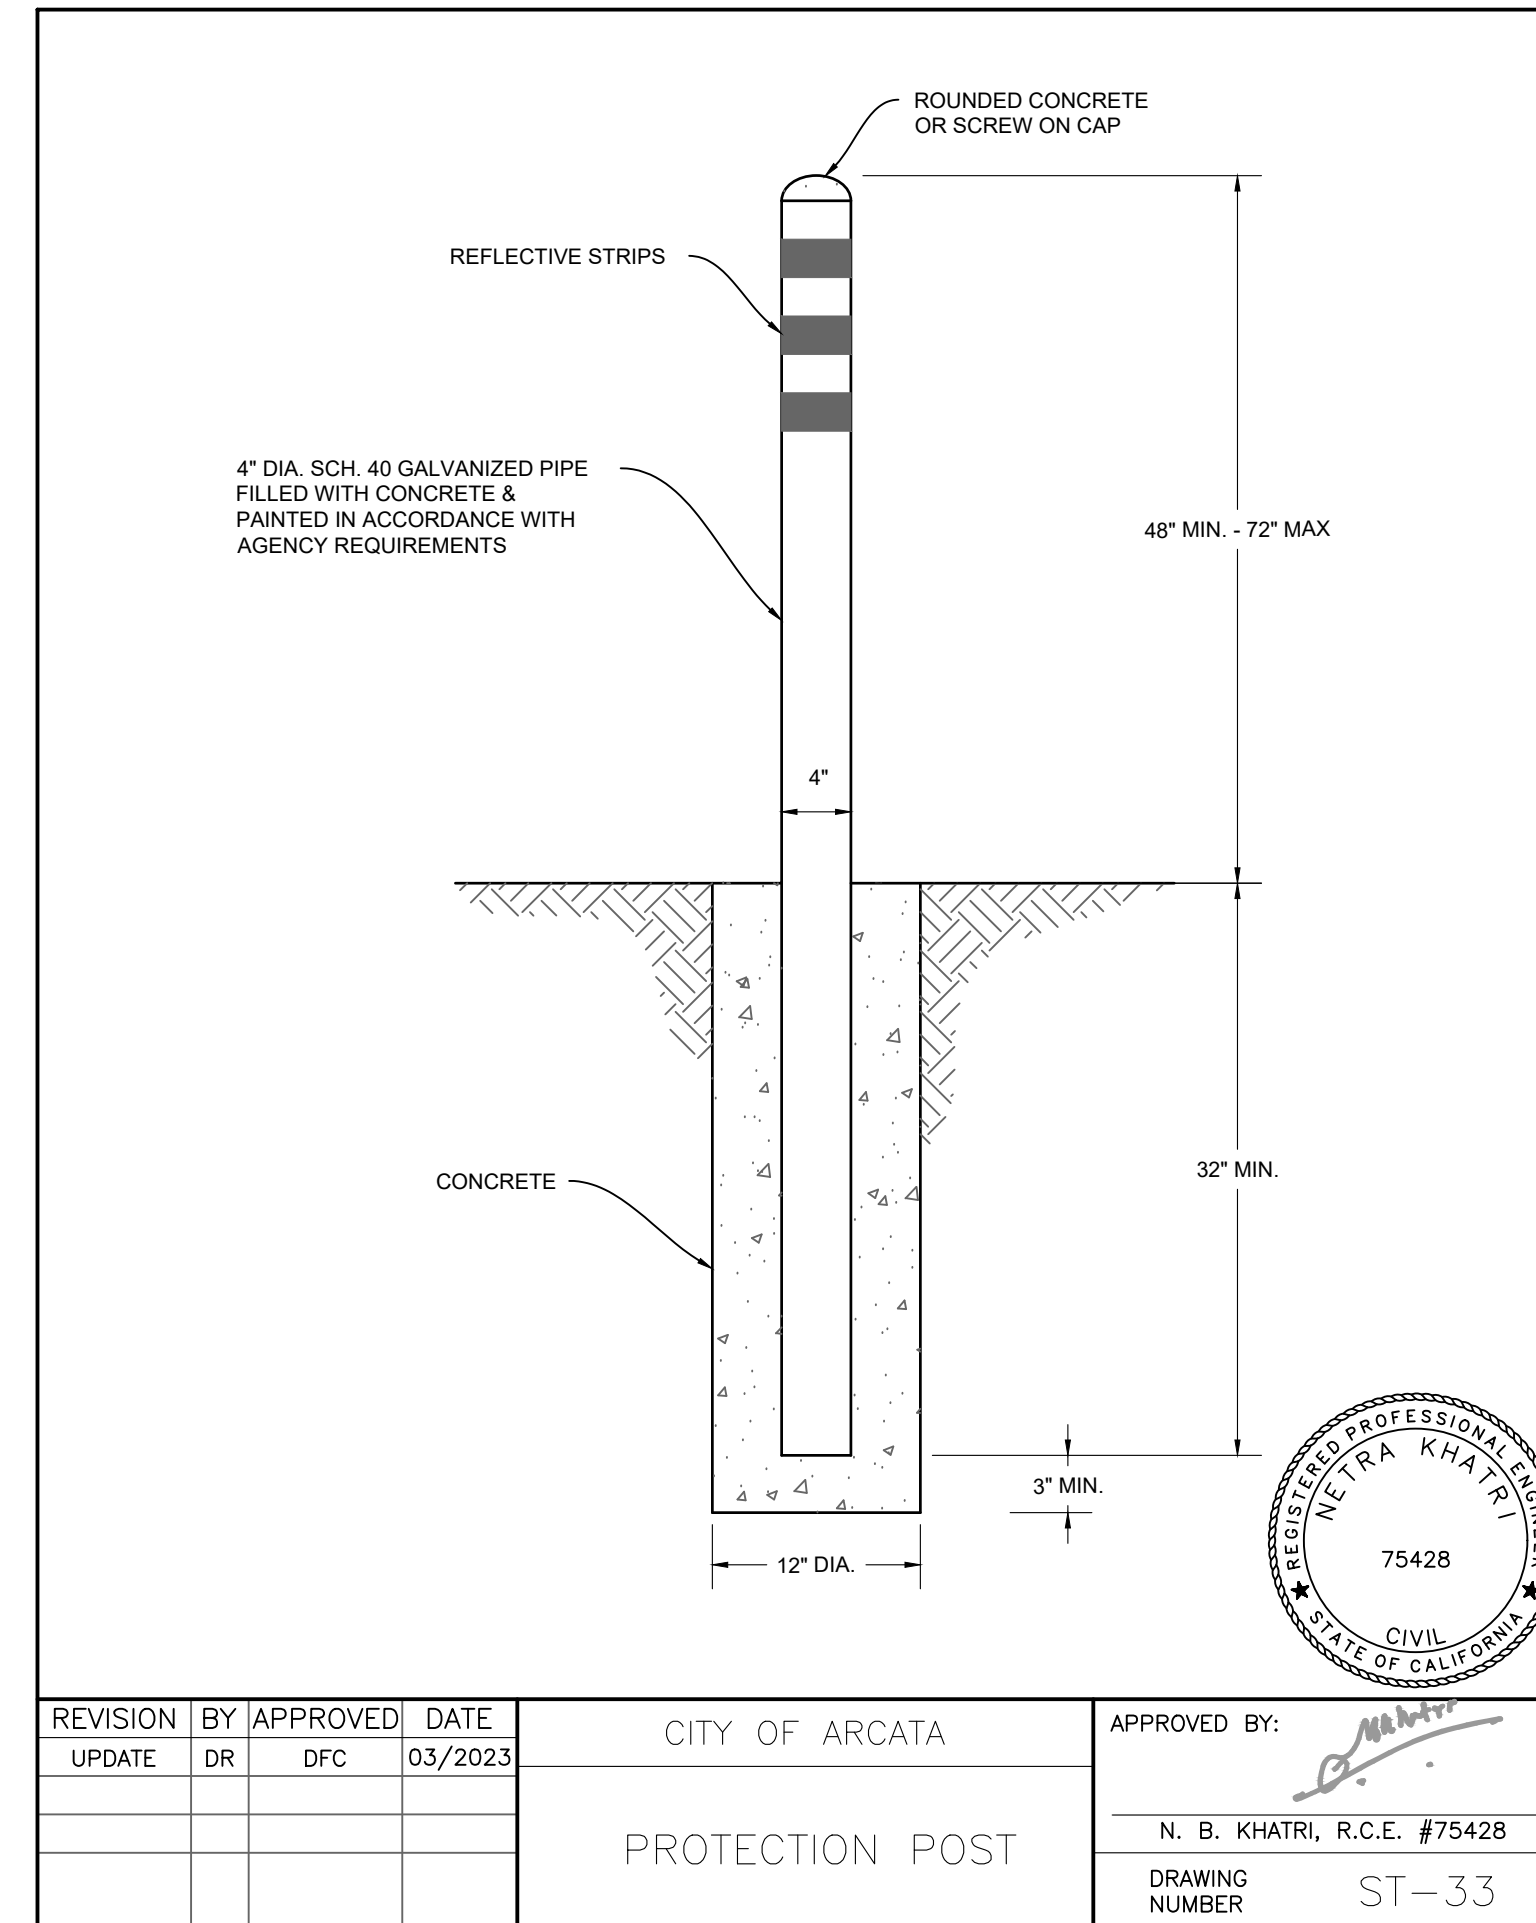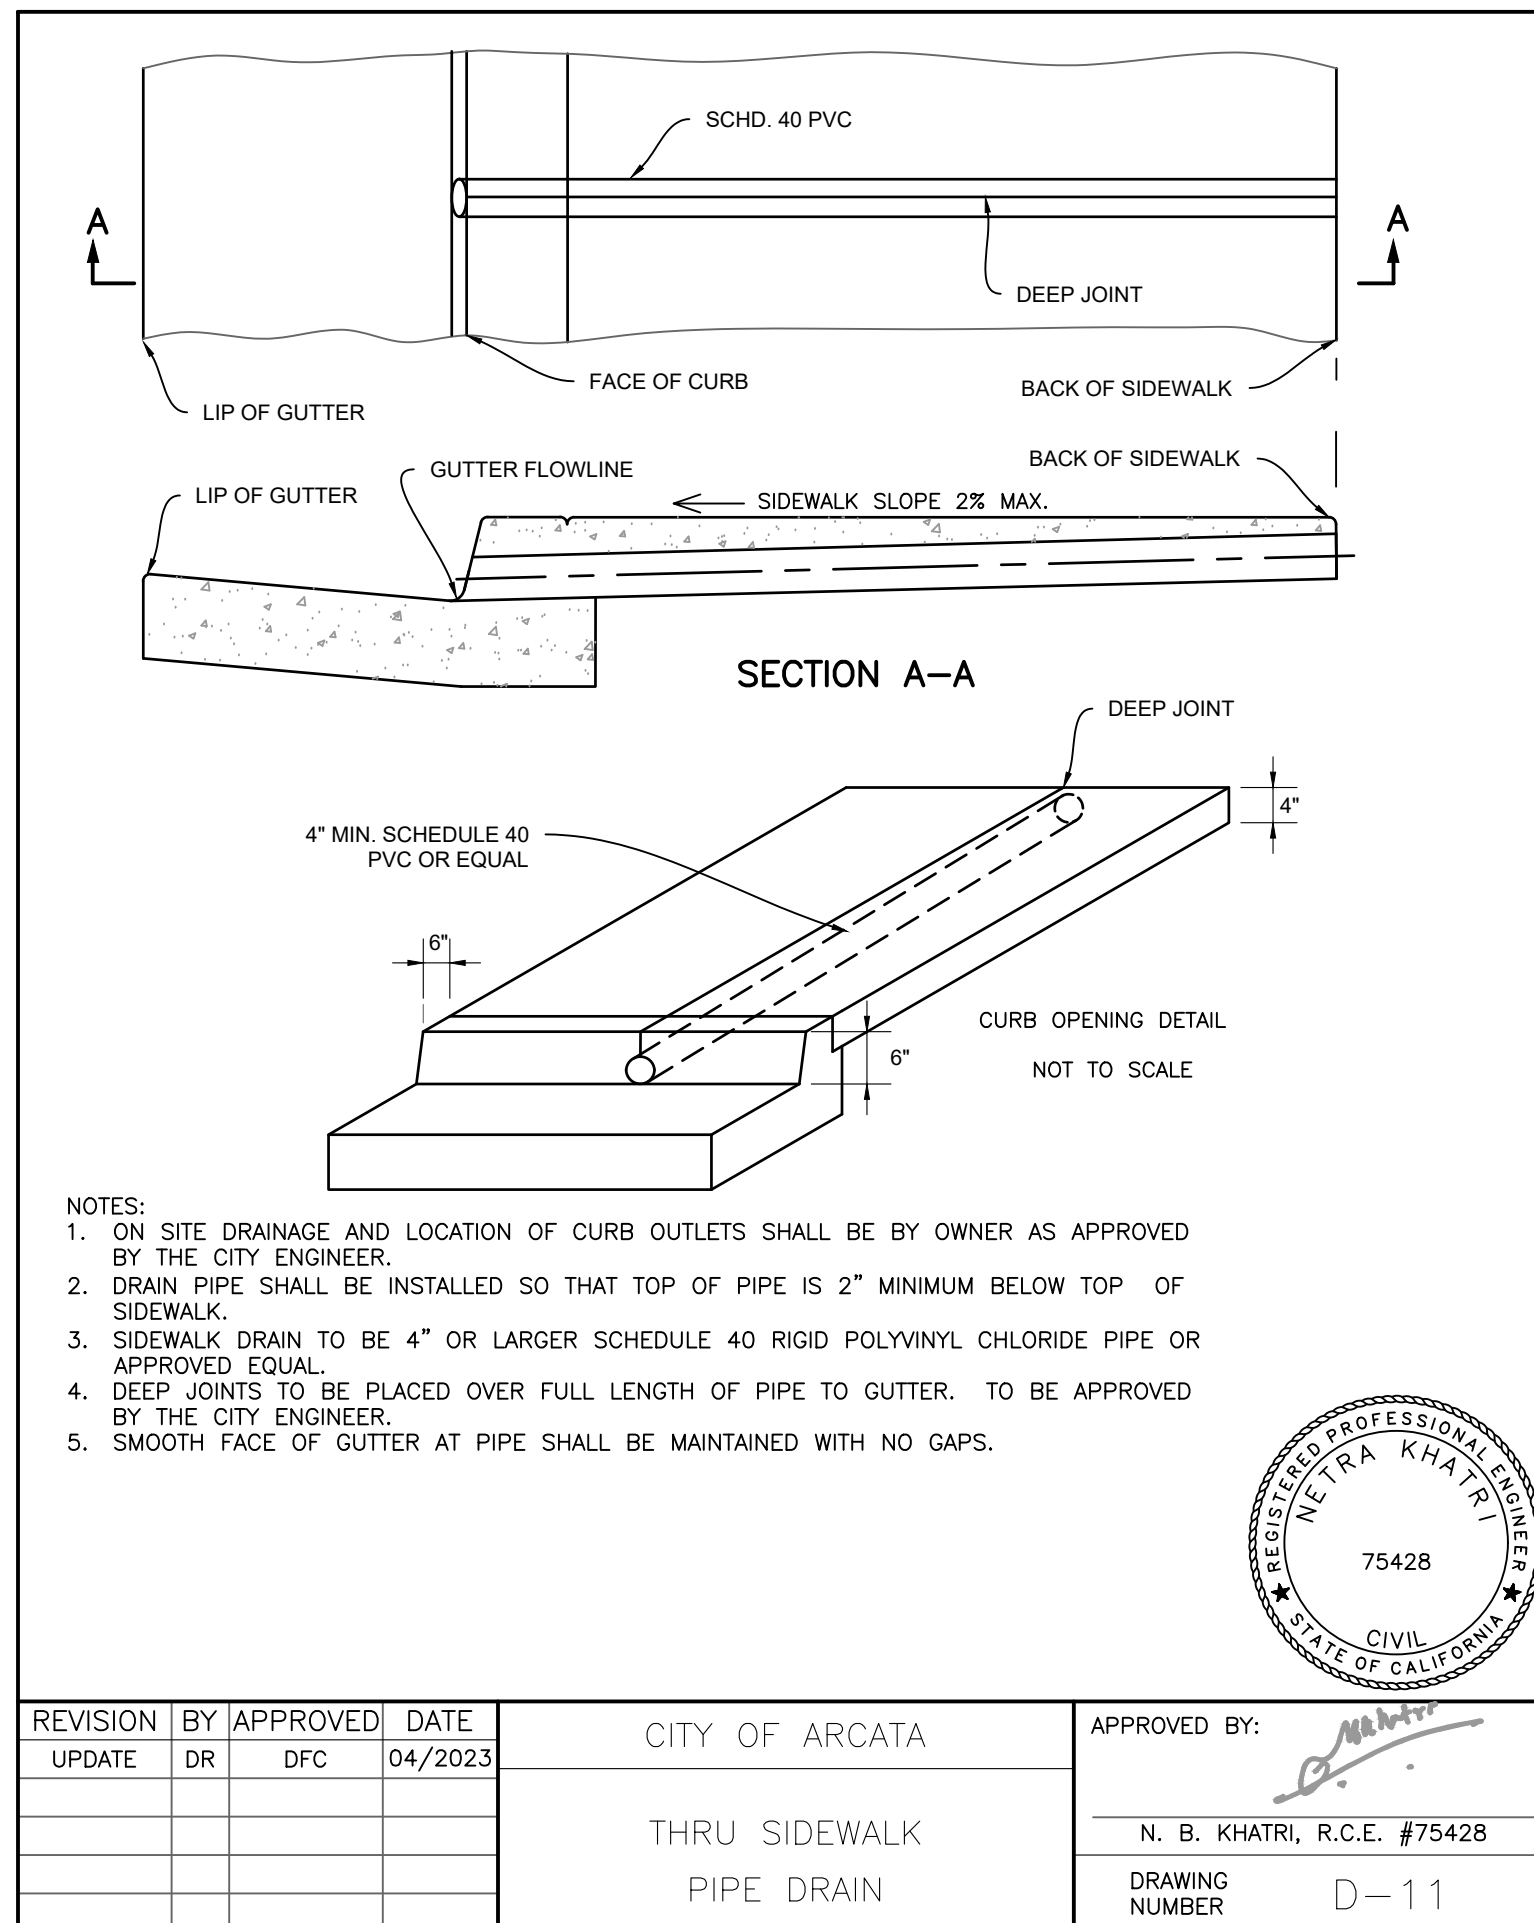

STANDARD DETAILS

STEEL WATERLINE REPLACEMENT PROJECT

Project Address

VARIOUS LOCATIONS

Designed By
JONATHAN A. KIRCHUBEL

Drawn By
JONATHAN A. KIRCHUBEL

Checked By DAVID CAISSE

Approved By NETRA B. KHATRI

Date	Sheet
JANUARY 2025	C-505

Scale	Page
N/A	30